
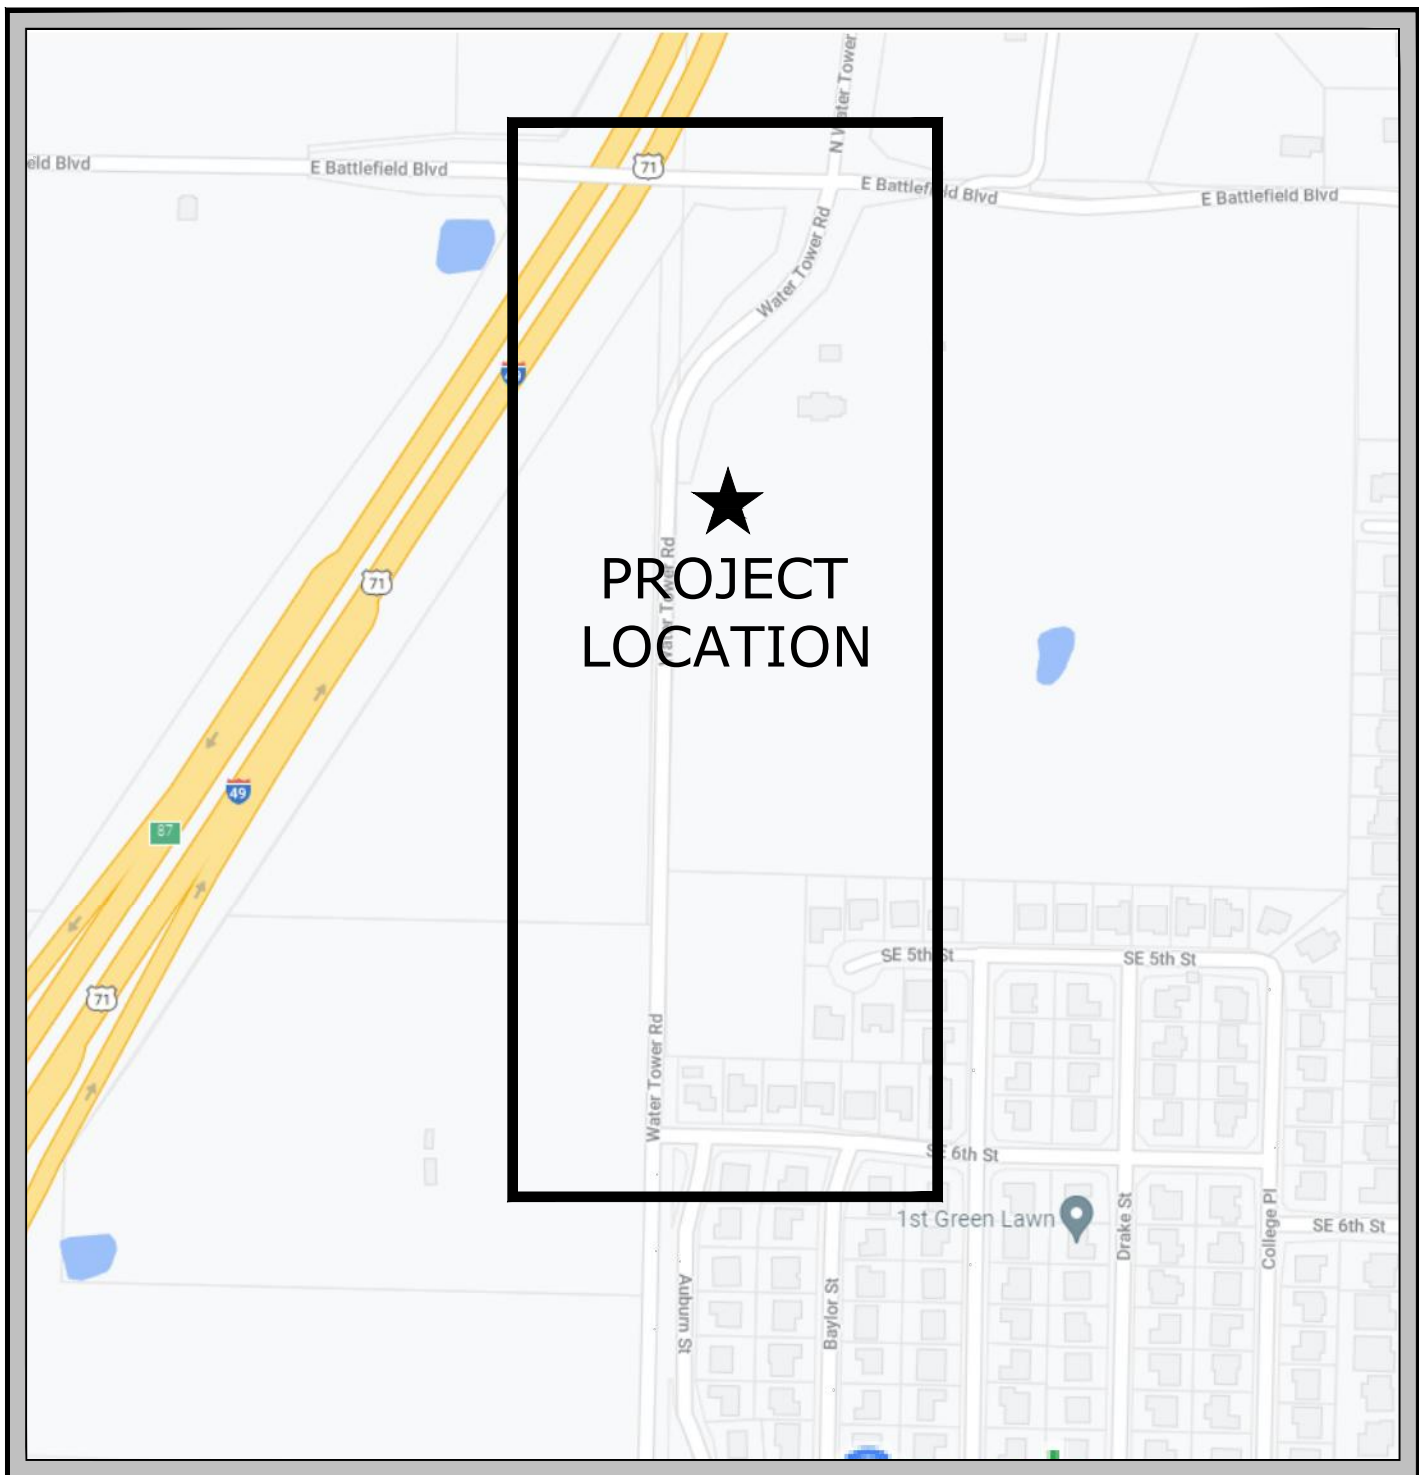


WATER TOWER RD. PH.3

SE. 6TH ST. TO BATTLEFIELD BLVD.

BENTONVILLE, AR
30% SUBMITTAL

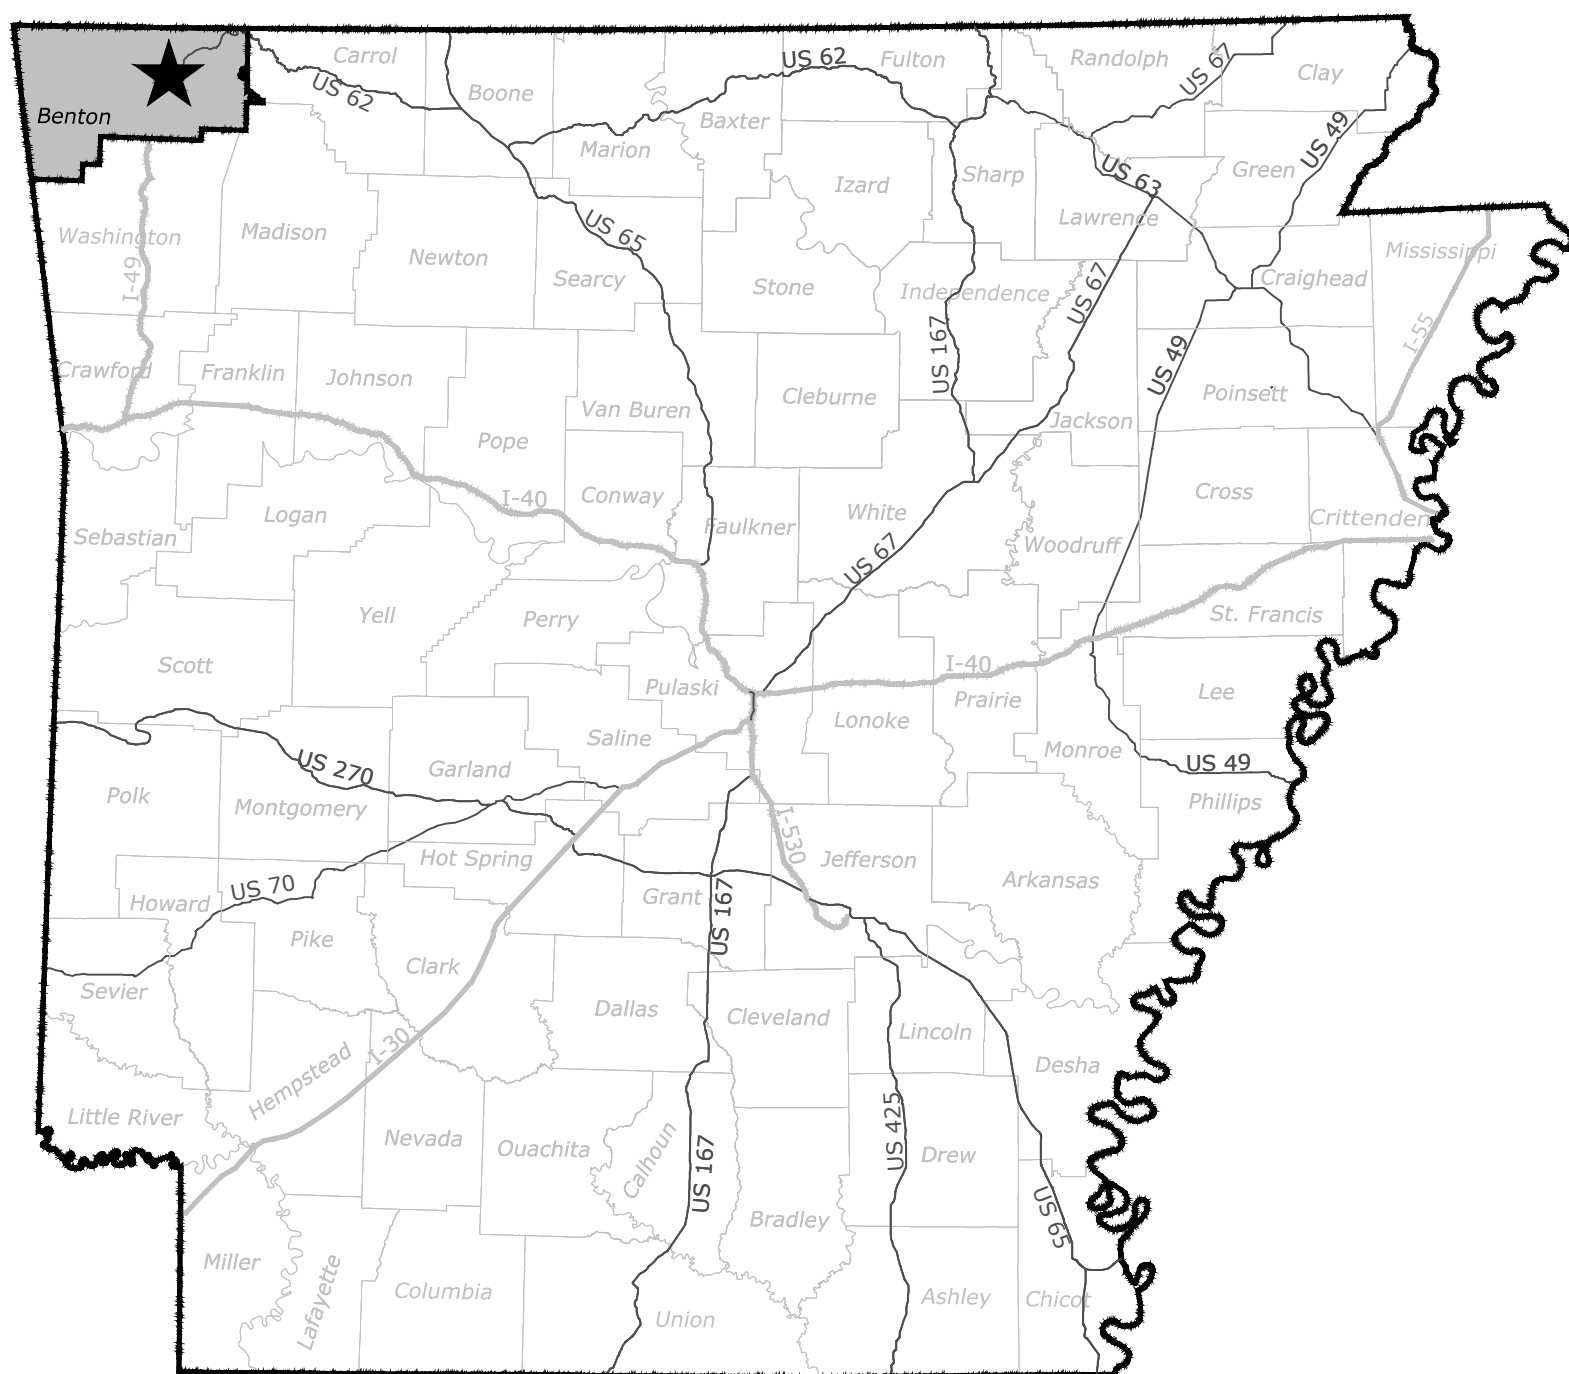

VICINITY MAP



CONTACTS

CITY ENGINEER
CITY OF BENTONVILLE
3200 SW MUNICIPAL DRIVE
BENTONVILLE, AR 72712
ANDREA JOBE- STAFF ENGINEER
479-254-2026
AJOBE@BENTONVILLEAR.COM

WATER AND SEWER
CITY OF BENTONVILLE
3200 SW MUNICIPAL DRIVE
BENTONVILLE, AR 72712
BEAU THOMPSON- ASST. MANAGER- TECH. SERVICES
479-271-3140
BTHOMPSON@BENTONVILLEAR.COM

NATURAL GAS
BLACK HILLS ENERGY
STREET
CITY, STATE ZIP
JOSH KNIGHT-
479-721-4543
JOSHUA.KNIGHT@BLACKHILLSCORP.COM

TELEPHONE
ATTN:
1133 EAST HAROLD STREET
FAYETTEVILLE, AR 72703
BRENT BALDWIN- MANAGER OF OUTSIDE PLANNING & DESIGN
479-571-6609
BB6585@ATT.COM


ELECTRIC
BENTONVILLE ELECTRIC
3200 SW MUNICIPAL DRIVE
BENTONVILLE, AR 72712
TRAVIS MATLOCK- ENGINEERING DIRECTOR
479-271-5941
TMATLOCK@BENTONVILLEAR.COM

INTERNET
COX COMMUNICATIONS
STREET
CITY, STATE ZIP
KIP SMITH-
479-717-3796
KIP.SMITH@COX.COM

CIVIL ENGINEERING CONSULTANT
McCLELLAND CONSULTING ENGINEERS, INC
1580 EAST STEARNS STREET
FAYETTEVILLE, AR 72703
ERIC ANDERSON- PROJECT ENGINEER
479-443-2377
EANDERSON@MCE.US.COM



January 2022
MCE PROJECT NUMBER 21-2147

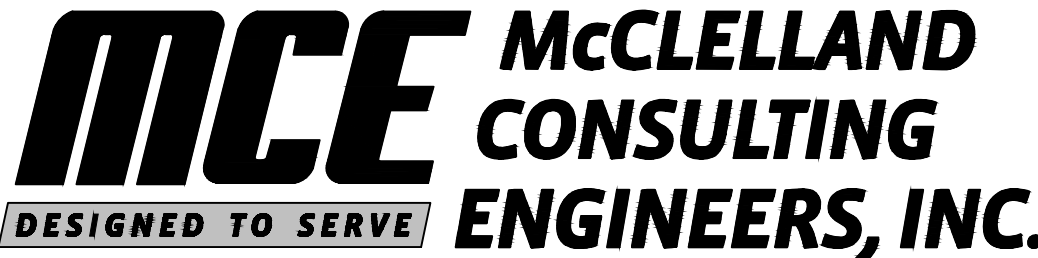

<http://www.mce.us.com>
1580 E. STEARNS ST.
FAYETTEVILLE, ARKANSAS 72703
(479) 443-2377



PRELIMINARY
NOT FOR
CONSTRUCTION

ORIGINAL SIGNATURE ON FILE

LITTLE ROCK, AR • FAYETTEVILLE, AR • FORT SMITH, AR • TULSA, OK

1	COVER
2	INDEX OF SHEETS
TSU-1	TOPOGRAPHIC & UTILITY SURVEY- STA. 1+00 TO STA. 9+00
TSU-2	TOPOGRAPHIC & UTILITY SURVEY- STA. 9+00 TO STA. 18+00
TSU-3	TOPOGRAPHIC & UTILITY SURVEY- STA. 18+00 TO STA. 27+08
TSU-4	TOPO. & UTIL. SURV. BATTLEFIELD BLVD- STA. 100+00 TO STA. 106+73
TS-1	TYPICAL SECTIONS- WATER TOWER ROAD
PP-1	PLAN AND PROFILE WATER TOWER RD.- STA. 1+00 TO STA. 5+25
PP-2	PLAN AND PROFILE WATER TOWER RD.- STA. 5+25 TO STA. 9+00
PP-3	PLAN AND PROFILE WATER TOWER RD.- STA. 9+00 TO STA. 13+75
PP-4	PLAN AND PROFILE WATER TOWER RD.- STA. 13+75 TO STA. 18+00
PP-5	PLAN AND PROFILE WATER TOWER RD.- STA. 18+00 TO STA. 22+50
PP-6	PLAN AND PROFILE WATER TOWER RD.- STA. 22+50 TO STA. 27+08
PP-7	PLAN AND PROFILE SE. 8TH ST. CONNECT.- STA. 50+00 TO STA. 53+50
PP-8	PLAN AND PROFILE SE. 8TH ST. CONNECT.- STA. 53+50 TO STA. 56+44
PP-9	PLAN AND PROFILE BATTLEFIELD BLVD.- STA. 100+00 TO STA. 103+50
PP-10	PLAN AND PROFILE BATTLEFIELD BLVD.- STA. 103+50 TO STA. 106+73
XS-1	CROSS SECTIONS SE. 8TH ST. BYPASS- STA. 50+00 TO STA. 54+00
XS-2	CROSS SECTION BYPASS STA. 55+75 TO WATER TOWER RD. STA. 5+00
XS-3	CROSS SECTIONS WATER TOWER RD.- STA. 6+50 TO STA. 10+50
XS-4	CROSS SECTIONS WATER TOWER RD.- STA. 11+00 TO STA. 15+00
XS-5	CROSS SECTIONS WATER TOWER RD.- STA. 15+50 TO STA. 19+50
XS-6	CROSS SECTIONS WATER TOWER RD.- STA. 20+00 TO STA. 23+00
PM-1	PAVEMENT MARKING AND SIGNAGE PLAN- STA. 1+00 TO STA. 9+00
PM-2	PAVEMENT MARKING AND SIGNAGE PLAN- STA. 9+00 TO STA. 18+00
PM-3	PAVEMENT MARKING AND SIGNAGE PLAN- STA. 18+00 TO STA. 22+50
PM-4	PAVEMENT MARKING AND SIGNAGE PLAN- ROUNDABOUT
PM-5	PVMT. MARKING AND SIGNAGE PLAN- SE. 8TH ST. CONNECTION
DMP-1	DRAINAGE AREA MAP



MCE **McCLELLAND
CONSULTING
ENGINEERS, INC.**
DESIGNED TO SERVE
1580 E. STEARNS ST.
FAYETTEVILLE, ARKANSAS 72703
(479) 443-2377
[HTTP://WWW.MCE.US.COM](http://www.mce.us.com)

PRELIMINARY
NOT FOR
CONSTRUCTION

ORIGINAL SIGNATURE ON FILE


WATER TOWER RD. PH.3
SE. 6TH ST. TO BATTLEFIELD BLVD.
BENTONVILLE, AR

[illegible]

INDEX OF SHEETS


DESIGNED BY: ELA	DRAWN BY : WAS
DATE: 1/24/2022	REVISION: 30%
SCALE: 1" = 20'	JOB NUMBER: 21-2147

W:\2021\21-2147 - Water Tower Road Phase III. 8th St. To E. Battlefield Blvd\Design Drawings\Sheets\21-2147- Topo & Utility.dwg, PRINTED ON: January 24, 2022 @ 5:14 PM

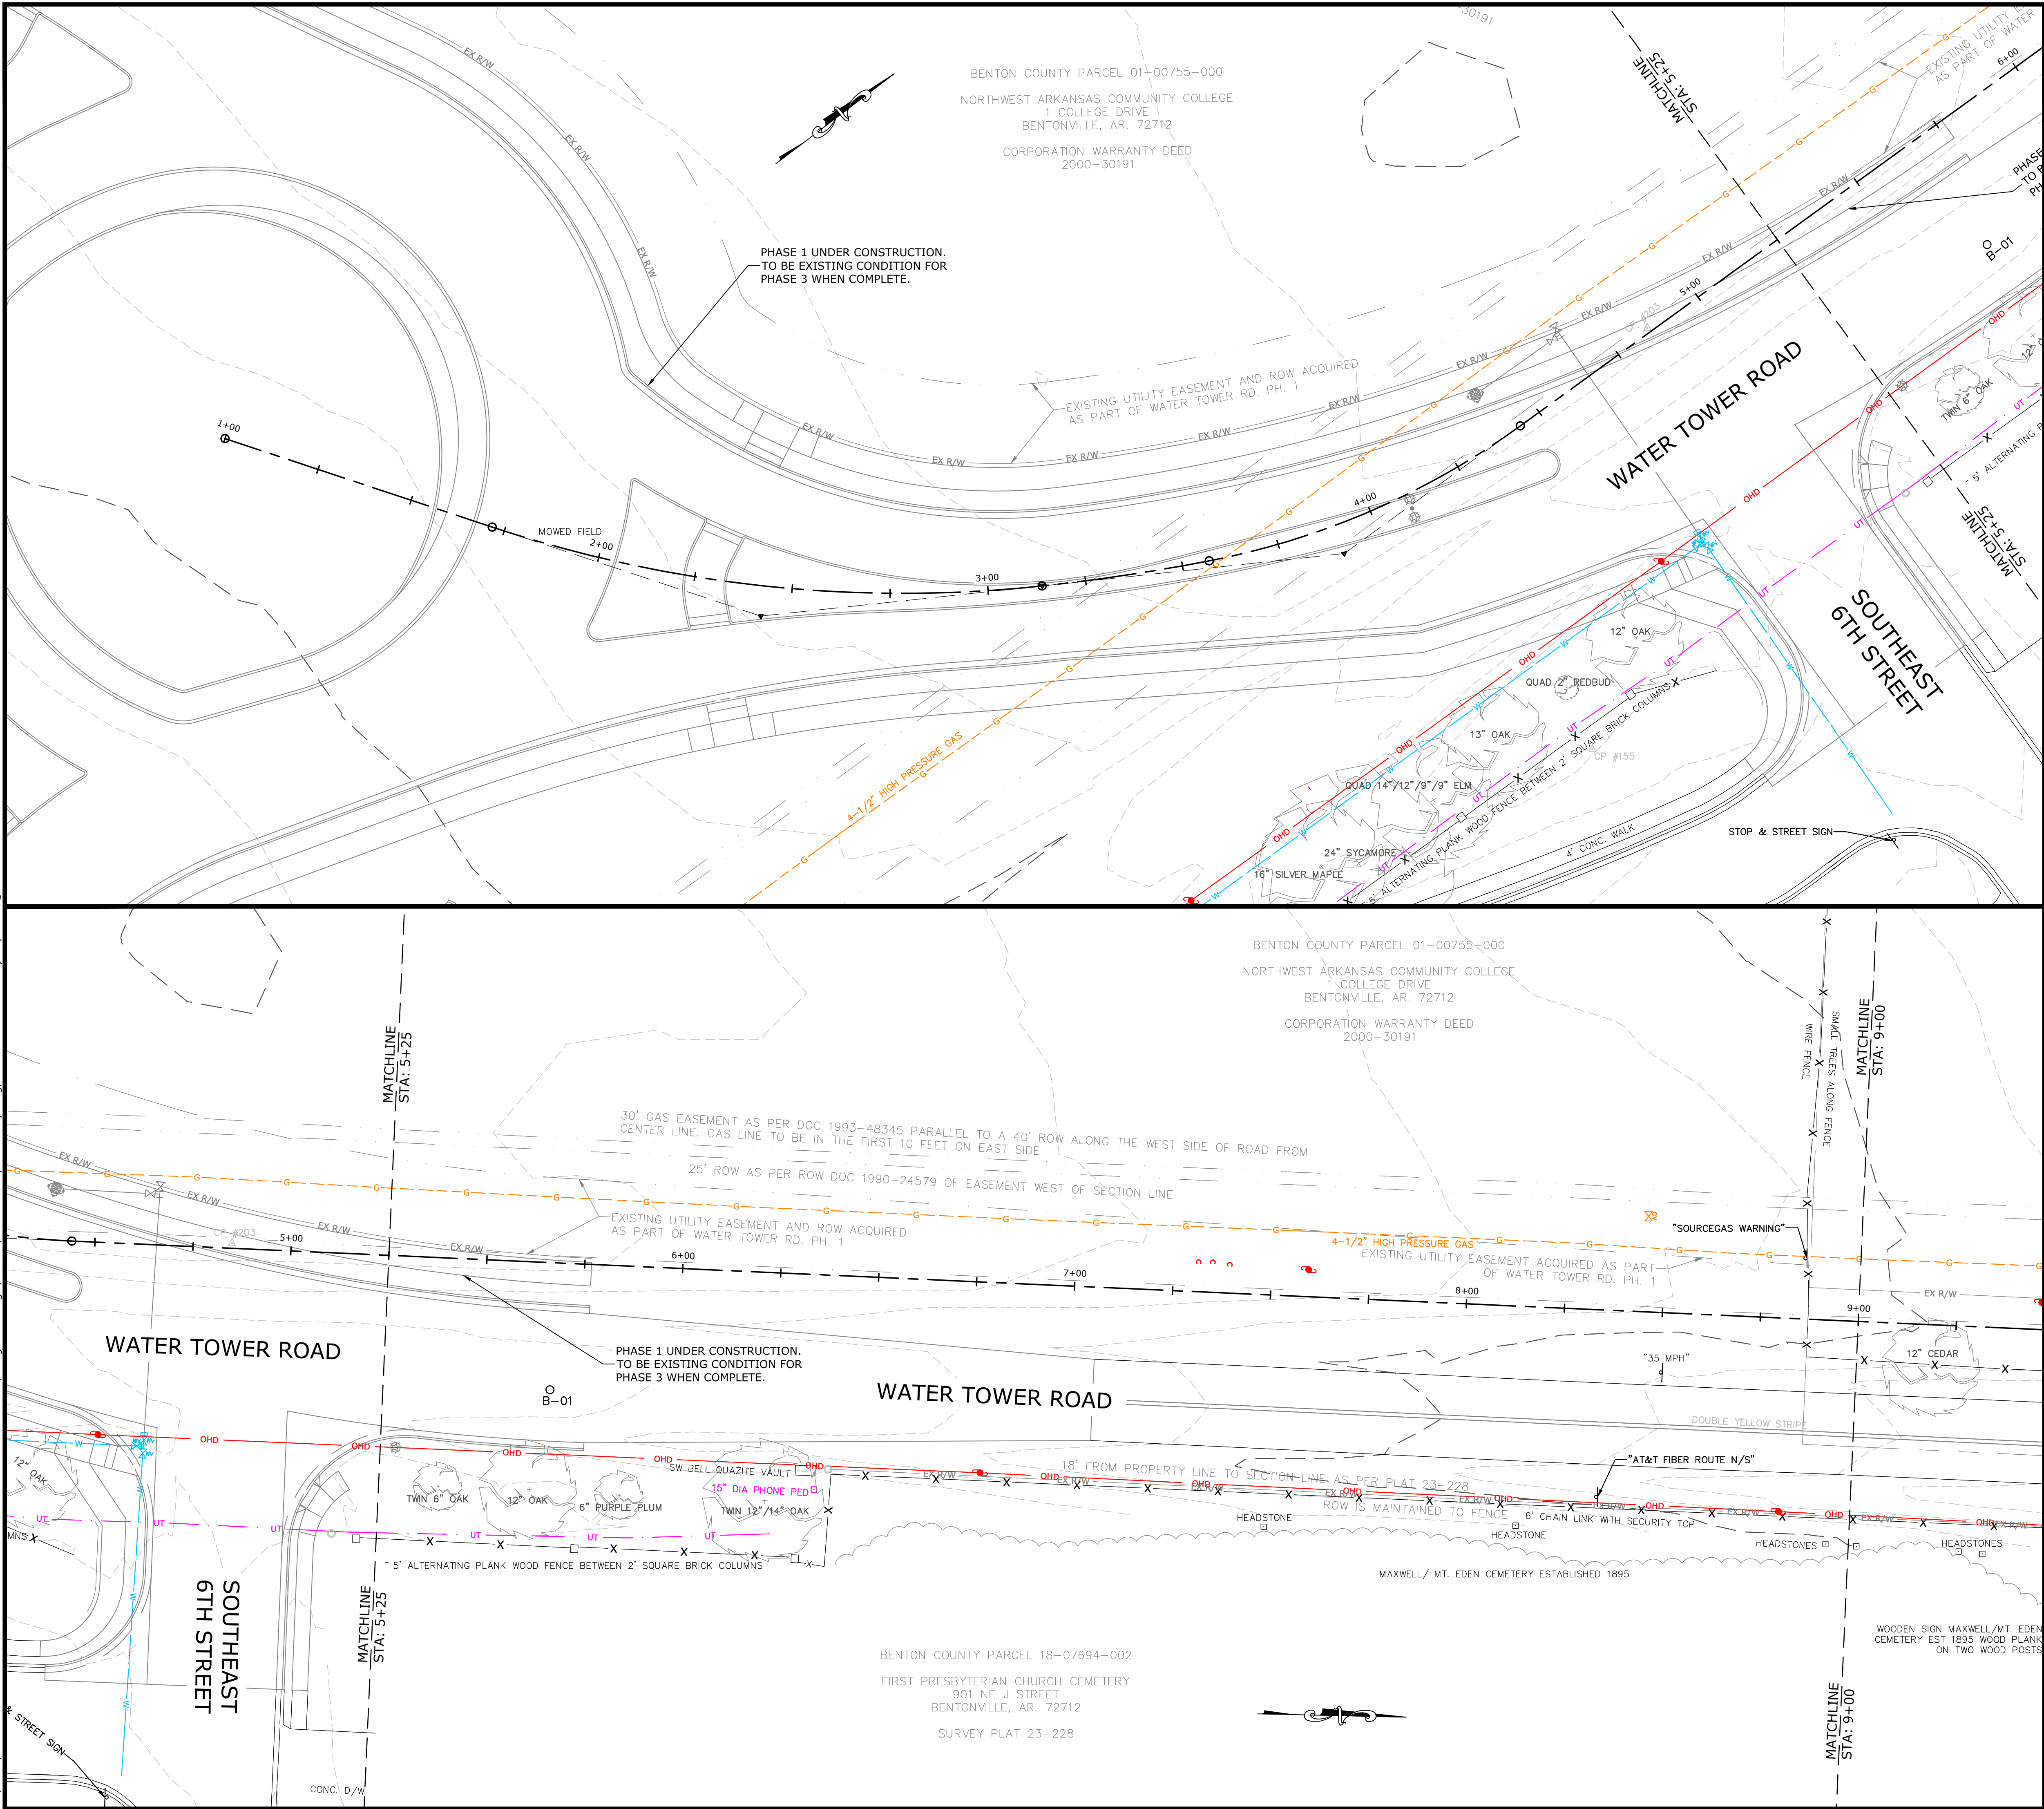

EXISTING LEGEND

- W WATER LINE
- G GAS LINE
- UT UNDERGROUND TELEPHONE
- UFO UNDERGROUND FIBER
- OHE OVERHEAD ELECTRIC
- OHD OVERHEAD UTILITY
- SDP STORM DRAINAGE PIPE
- X X FENCE
- 23+00 ROAD CENTERLINE
- DITCH FLOWLINE
- EX R/W RIGHT OF WAY
- EASEMENT
- FIRE HYDRANT
- WATER METER
- WATER VALVE
- GAS VALVE
- PHONE MANHOLE
- WATER FAUCET
- POWER POLE
- GUY WIRE w/ ANCHOR
- GAS METER
- TELEPHONE PEDESTAL
- CABLE TV PEDESTAL
- SIGN (AS NOTED)
- POST (AS NOTED)
- CONTROL POINT
- BUSH
- TREE (TO REMAIN)
- TREE (TO BE REMOVED)

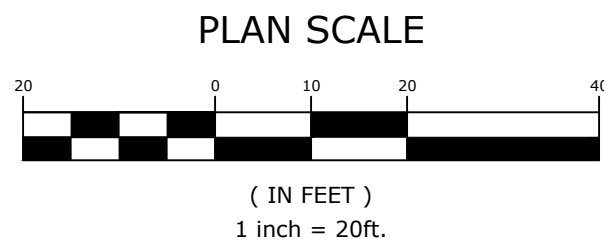

MCE McClelland
CONSULTING, INC.
1580 E. STEARNS ST.
FAYETTEVILLE, ARKANSAS 72703
(479) 443-2377
HTTP://WWW.MCE.US.COM

PRELIMINARY
NOT FOR
CONSTRUCTION

ORIGINAL SIGNATURE ON FILE

WATER TOWER RD. PH.3
SE. 6TH ST. TO BATTLEFIELD BLVD.
BENTONVILLE, AR

BENTONVILLE
B
ENGINEERING

811
Know what's below.
Call before you dig.


REVISIONS	
REV	DESCRIPTION

TOPOGRAPHIC
& UTILITY
SURVEY- STA.
1+00 TO STA.
9+00

DESIGNED BY: ELA	DRAWN BY: WAS
DATE: 1/24/2022	REVISION: 30%
SCALE: 1" = 20'	JOB NUMBER: 21-2147


TSU-1

W:\2021\21-2147 - Water Tower Road Phase III. 8th St. To E. Battiefield Blvd Design Drawings\Sheets\21-2147- Topo & Utility.dwg, PRINTED ON: January 24, 2022 @ 5:14 PM

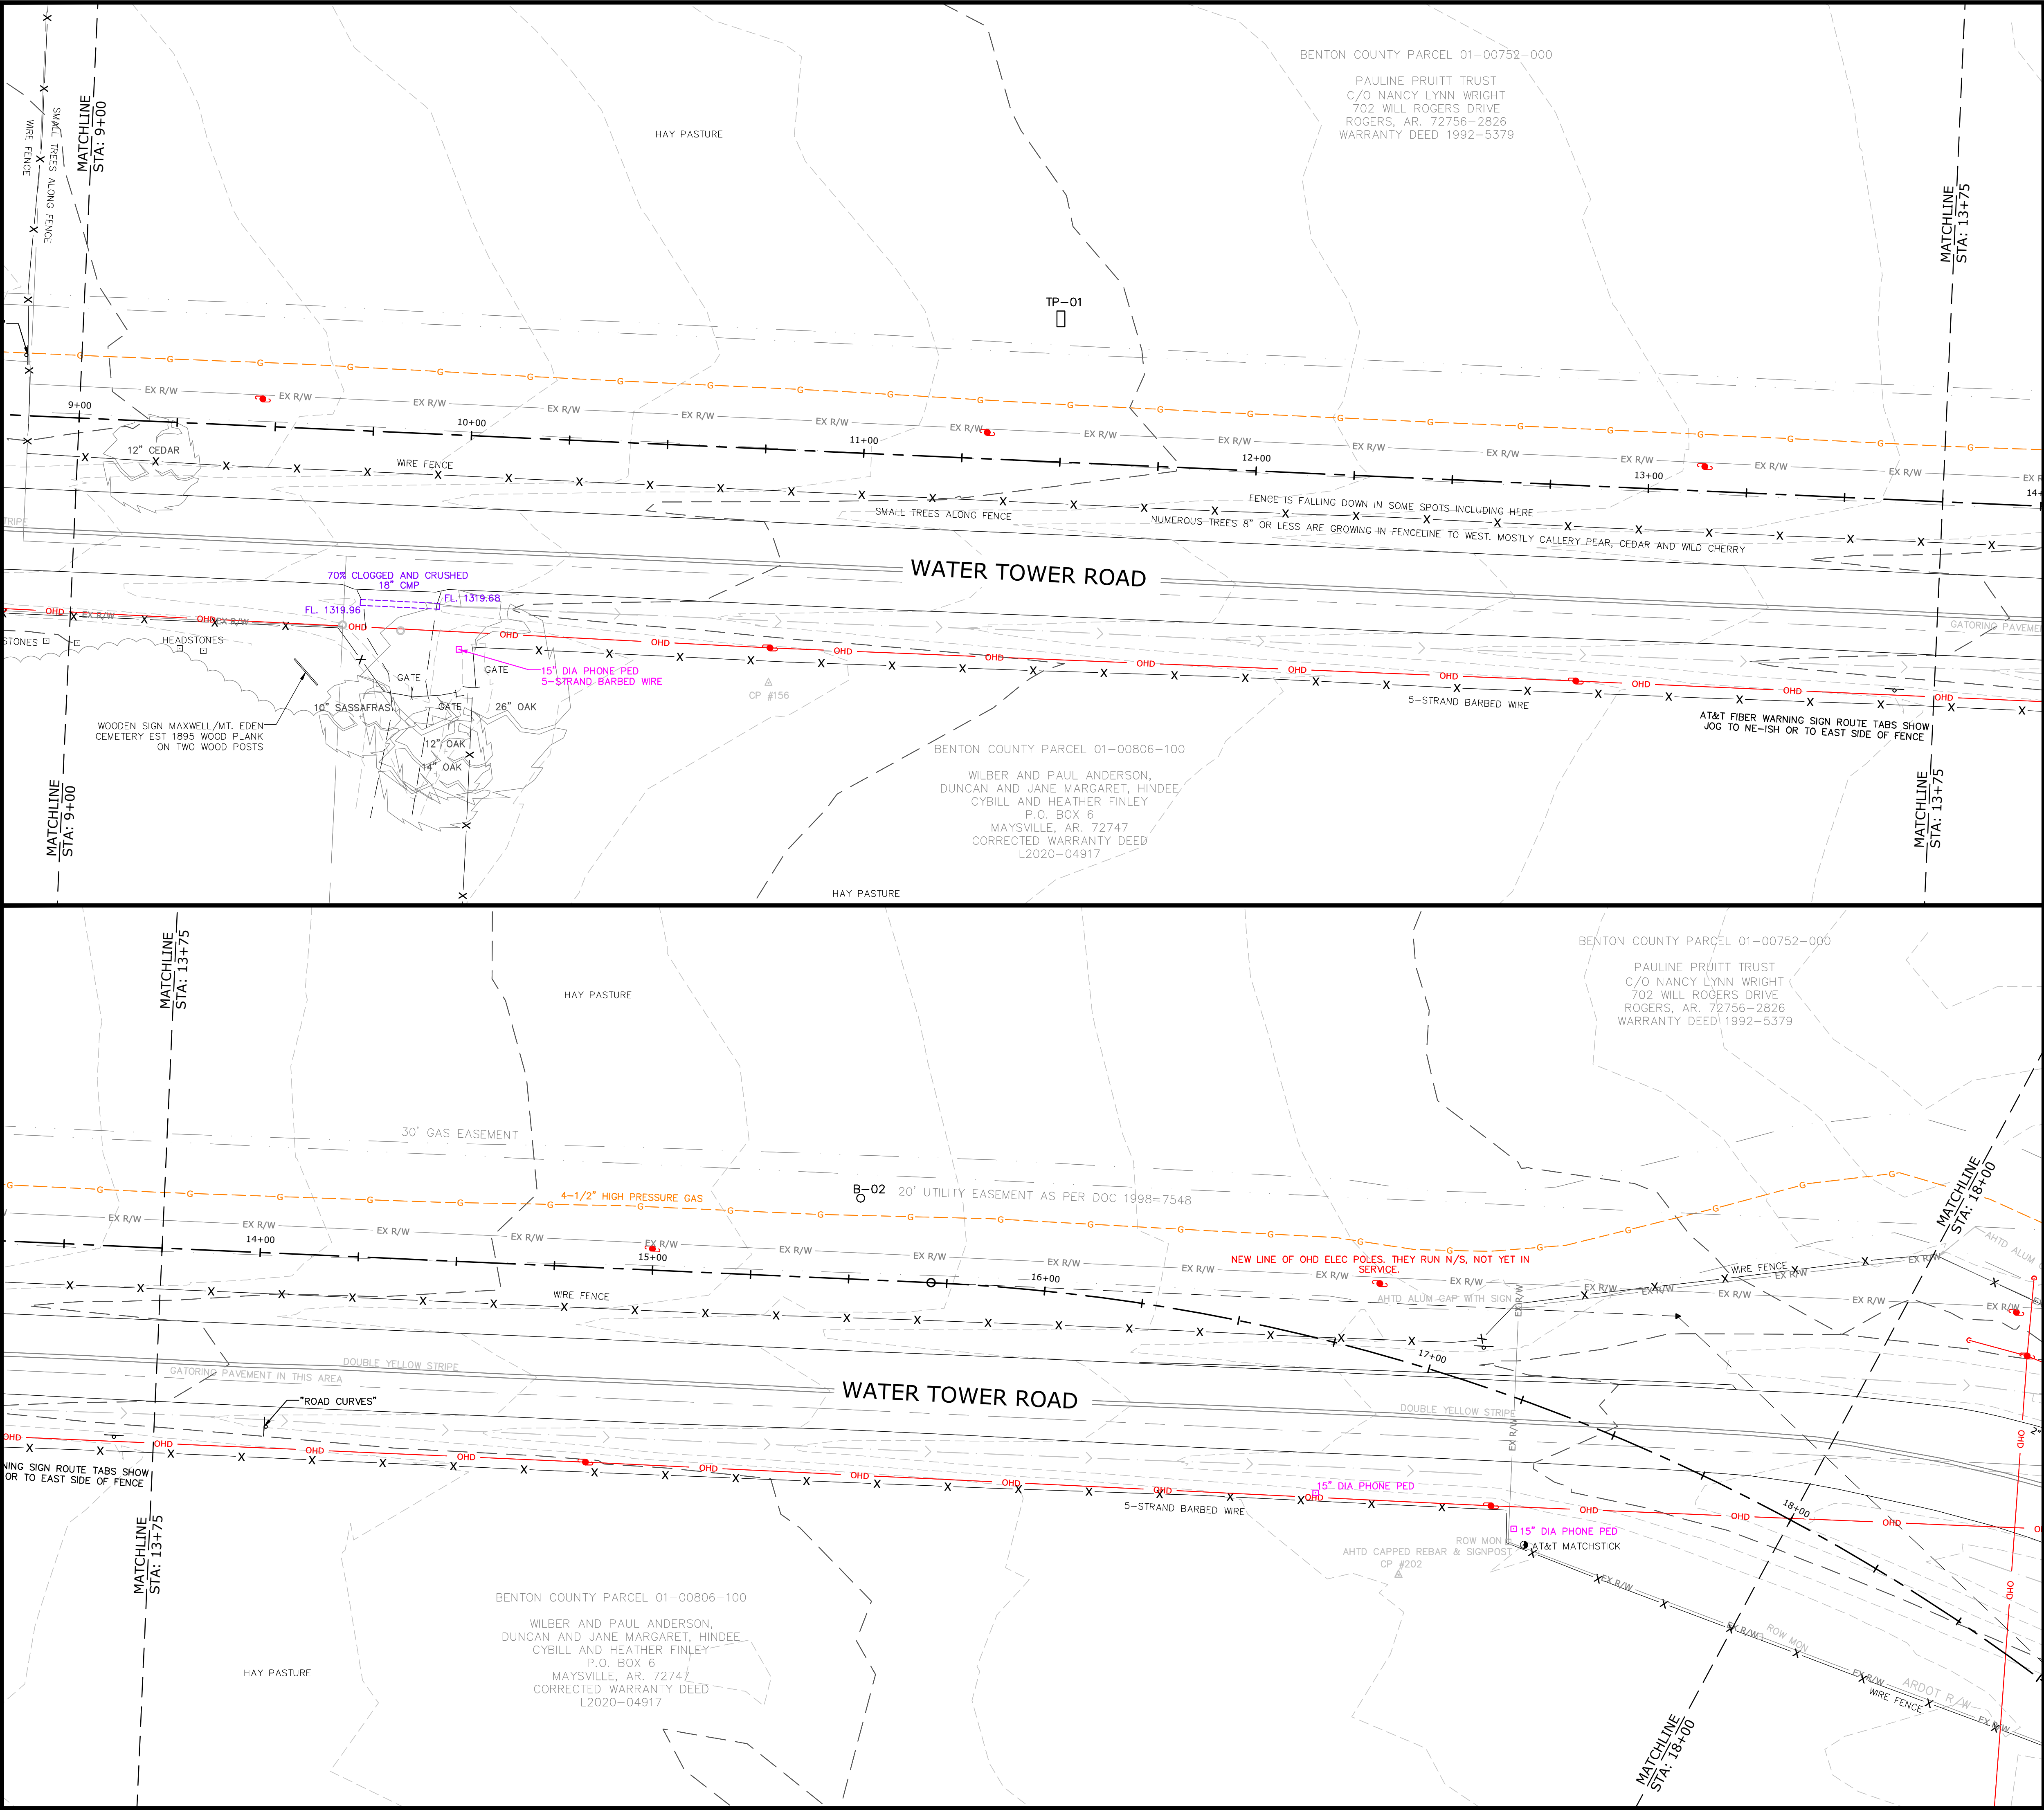

EXISTING LEGEND

- W WATER LINE
- G GAS LINE
- UT UNDERGROUND TELEPHONE
- UFO UNDERGROUND FIBER
- OHE OVERHEAD ELECTRIC
- OHD OVERHEAD UTILITY
- SD STORM DRAINAGE PIPE
- X FENCE
- 23+00 ROAD CENTERLINE
- DITCH FLOWLINE
- EX R/W RIGHT OF WAY
- EASEMENT
- FIRE HYDRANT
- WATER METER
- WATER VALVE
- GAS VALVE
- PHONE MANHOLE
- WATER FAUCET
- POWER POLE
- GUY WIRE w/ ANCHOR
- GAS METER
- TELEPHONE PEDESTAL
- CABLE TV PEDESTAL
- SIGN (AS NOTED)
- POST (AS NOTED)
- CONTROL POINT
- BUSH
- TREE (TO REMAIN)
- TREE (TO BE REMOVED)

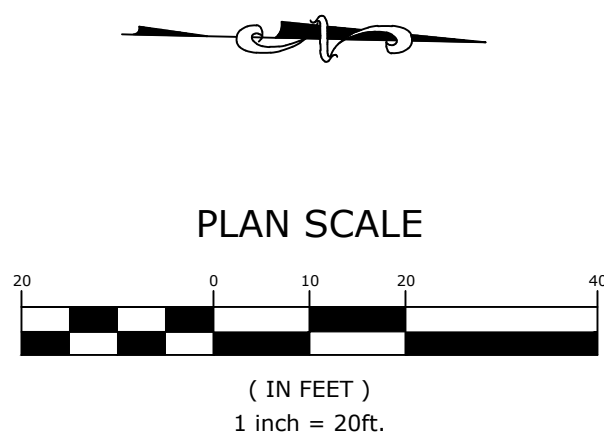

MCE **McCLELLAND**
DESIGNED TO SERVE **CONSULTING, INC.**
1580 E. STEARNS ST.
FAYETTEVILLE, ARKANSAS 72703
(479) 443-2377
HTTP://WWW.MCE.US.COM

PRELIMINARY
NOT FOR
CONSTRUCTION

ORIGINAL SIGNATURE ON FILE

WATER TOWER RD. PH.3
SE. 6TH ST. TO BATTLEFIELD BLVD
BENTONVILLE, AR

BENTONVILLE
B
ENGINEERING

811
Know what's below.
Call before you dig.

REVISIONS	
REV	DESCRIPTION

TOPOGRAPHIC
& UTILITY
SURVEY- STA.
9+00 TO STA.
18+00

DESIGNED BY:
ELA

DRAWN BY:
WAS

DATE:
1/24/2022


REVISION:
30%

SCALE:
1" = 20'

JOB NUMBER:
21-2147


TSU-2

W:\2021\21-2147 - Water Tower Road Phase III, 8th St. To E. Battlefield Blvd\Design Drawings\Sheets\21-2147- Topo & Utility.dwg, PRINTED ON: January 24, 2022 @ 5:15 PM

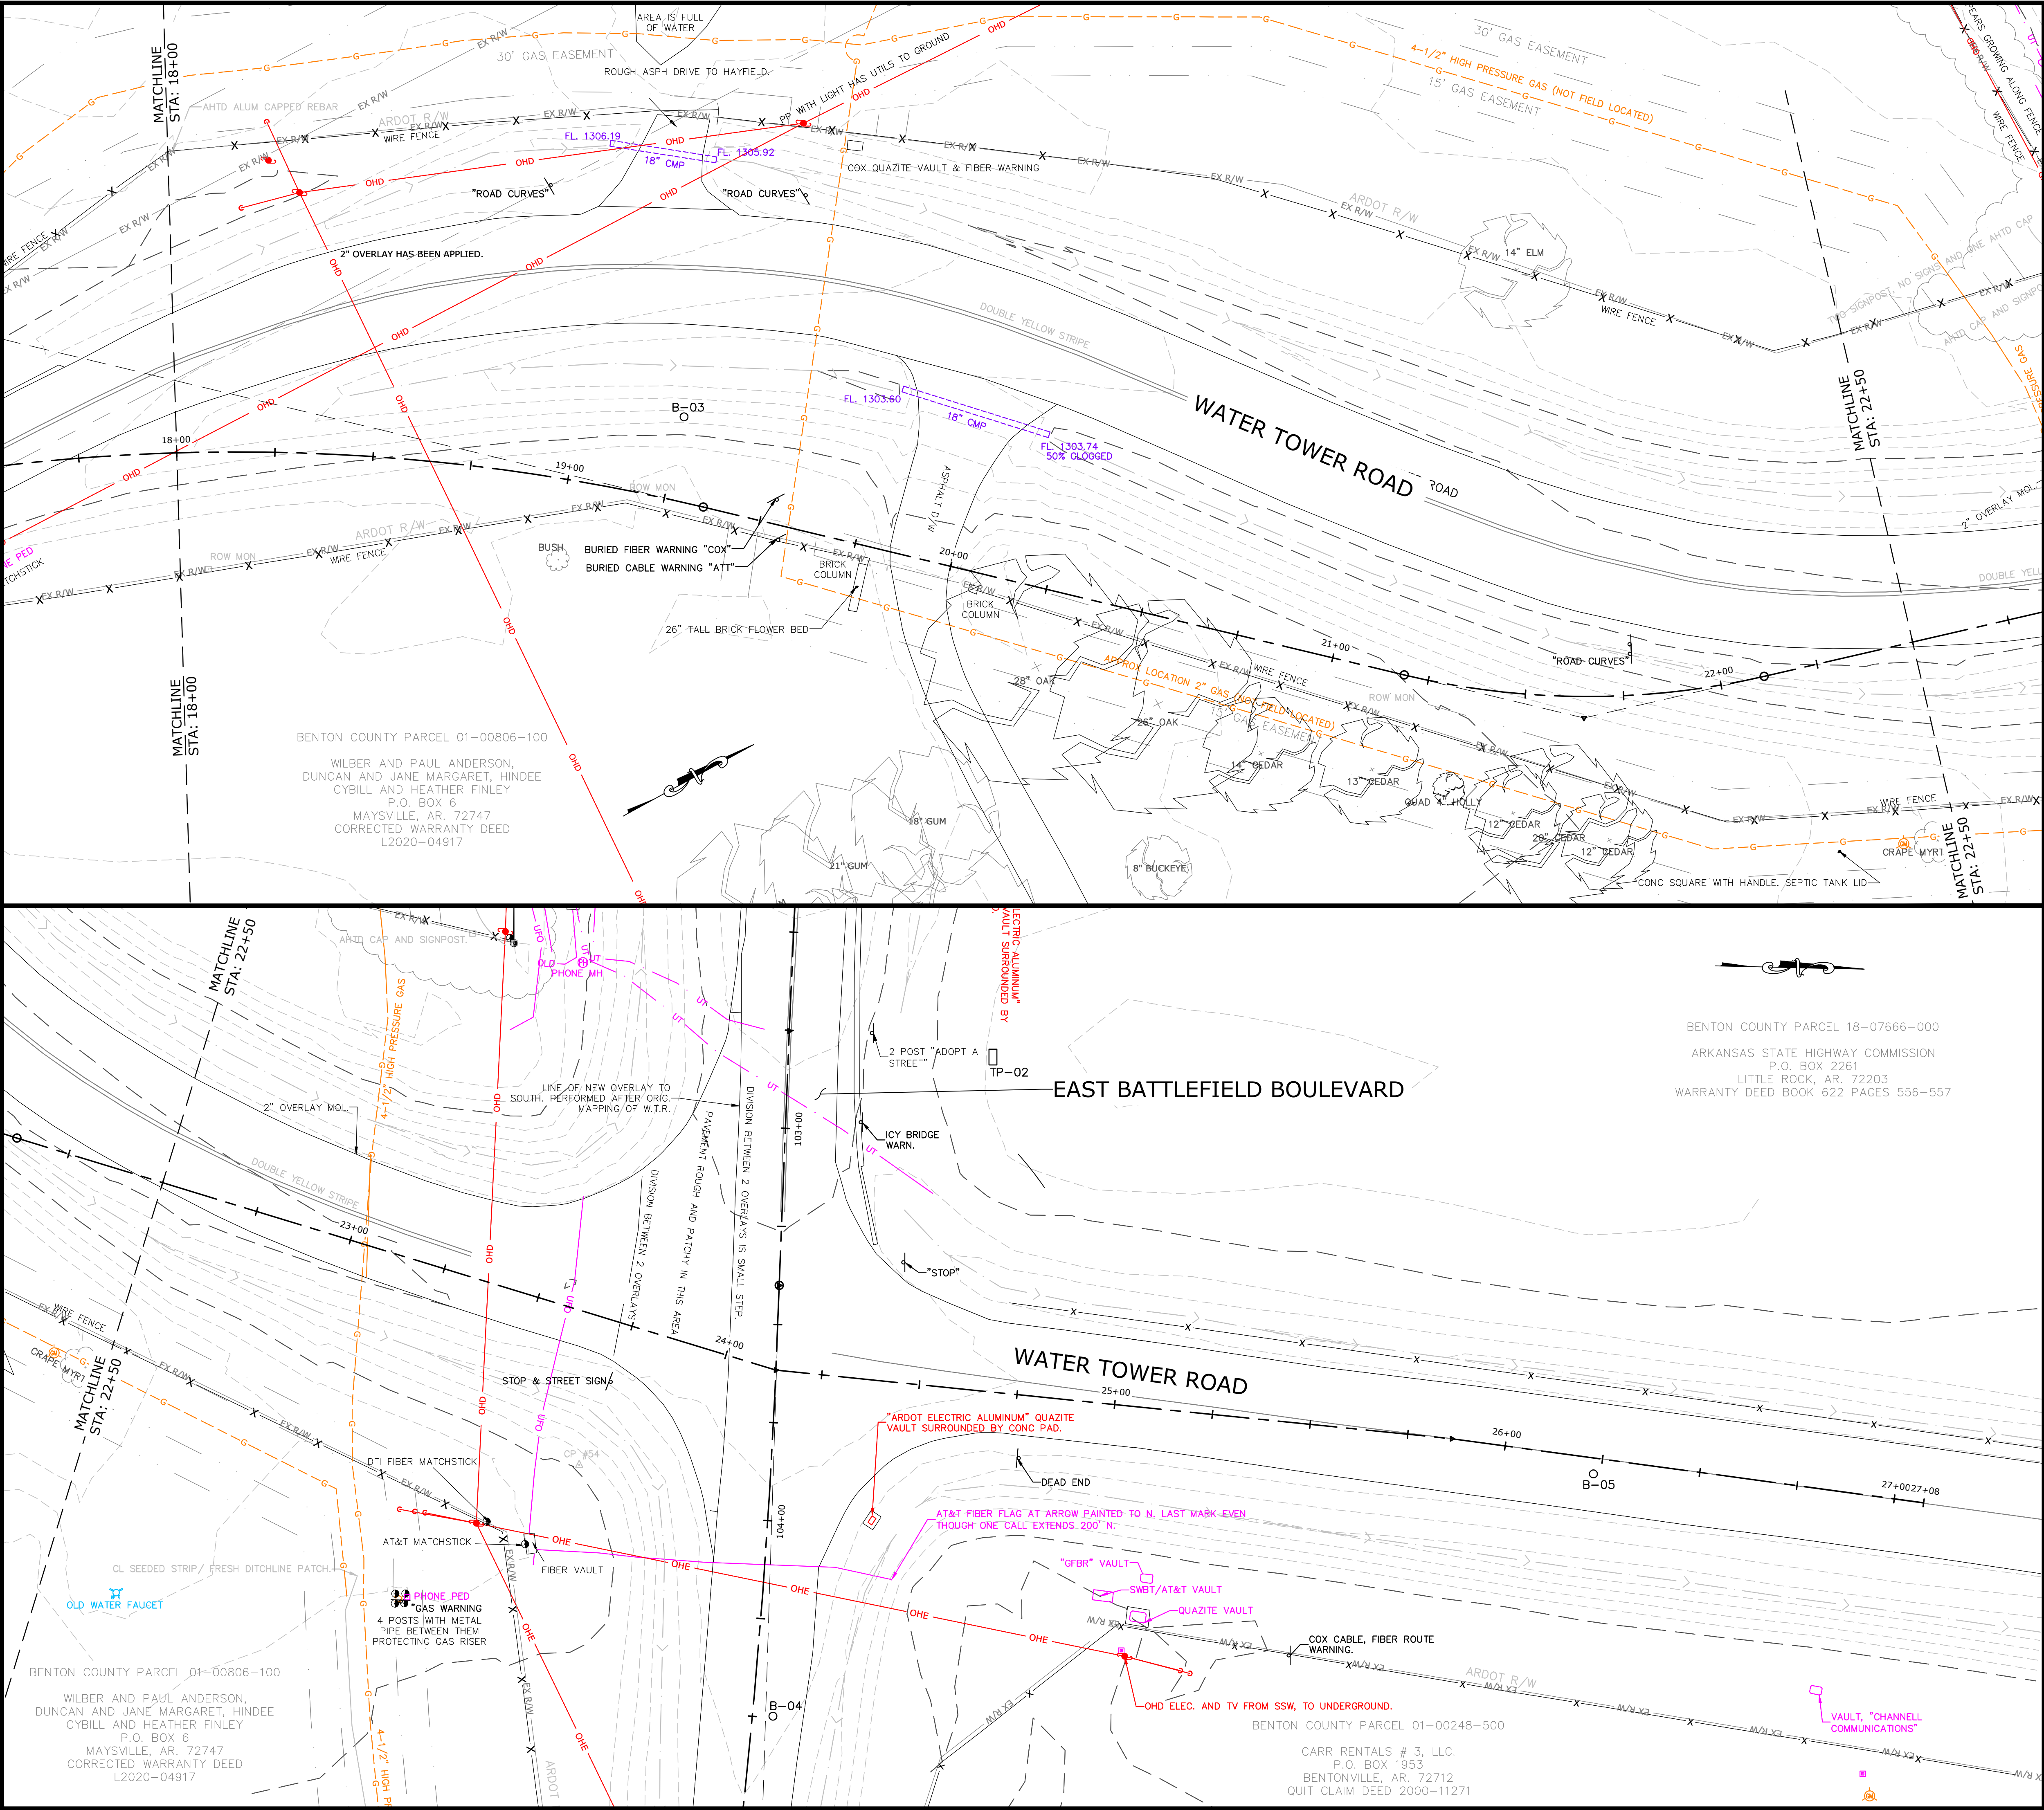

EXISTING LEGEND

- W WATER LINE
- G GAS LINE
- UT UNDERGROUND TELEPHONE
- UFO UNDERGROUND FIBER
- OHE OVERHEAD ELECTRIC
- OHD OVERHEAD UTILITY
- SD STORM DRAINAGE PIPE
- X FENCE
- 23+00 ROAD CENTERLINE
- DITCH FLOWLINE
- EX R/W RIGHT OF WAY
- EASEMENT
- FIRE HYDRANT
- WATER METER
- WATER VALVE
- GAS VALVE
- PHONE MANHOLE
- WATER FAUCET
- POWER POLE
- GUY WIRE w/ ANCHOR
- GAS METER
- TELEPHONE PEDESTAL
- CABLE TV PEDESTAL
- SIGN (AS NOTED)
- POST (AS NOTED)
- CONTROL POINT
- BUSH
- TREE (TO REMAIN)
- TREE (TO BE REMOVED)

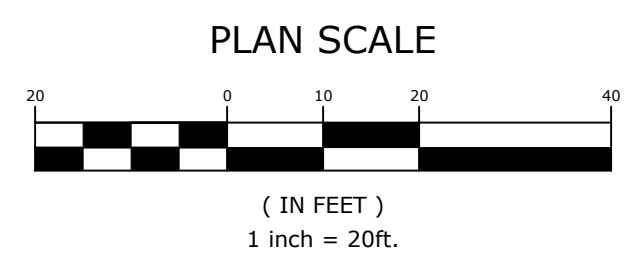

MCE McClelland Consulting, Inc.
DESIGNED TO SERVE
1580 E. STEARNS ST.
FAYETTEVILLE, ARKANSAS 72703
(479) 443-2377
HTTP://WWW.MCE.US.COM

PRELIMINARY
NOT FOR
CONSTRUCTION

ORIGINAL SIGNATURE ON FILE

WATER TOWER RD. PH.3
SE. 6TH ST. TO BATTLEFIELD BLVD.
BENTONVILLE, AR




811
Know what's below.
Call before you dig.

REVISONS		DESCRIPTION	
REV	DATE		


TOPOGRAPHIC
& UTILITY
SURVEY- STA.
18+00 TO STA.
27+08


DESIGNED BY: ELA	DRAWN BY: WAS
DATE: 1/24/2022	REVISION: 30%
SCALE: 1" = 20'	JOB NUMBER: 21-2147

TSU-3

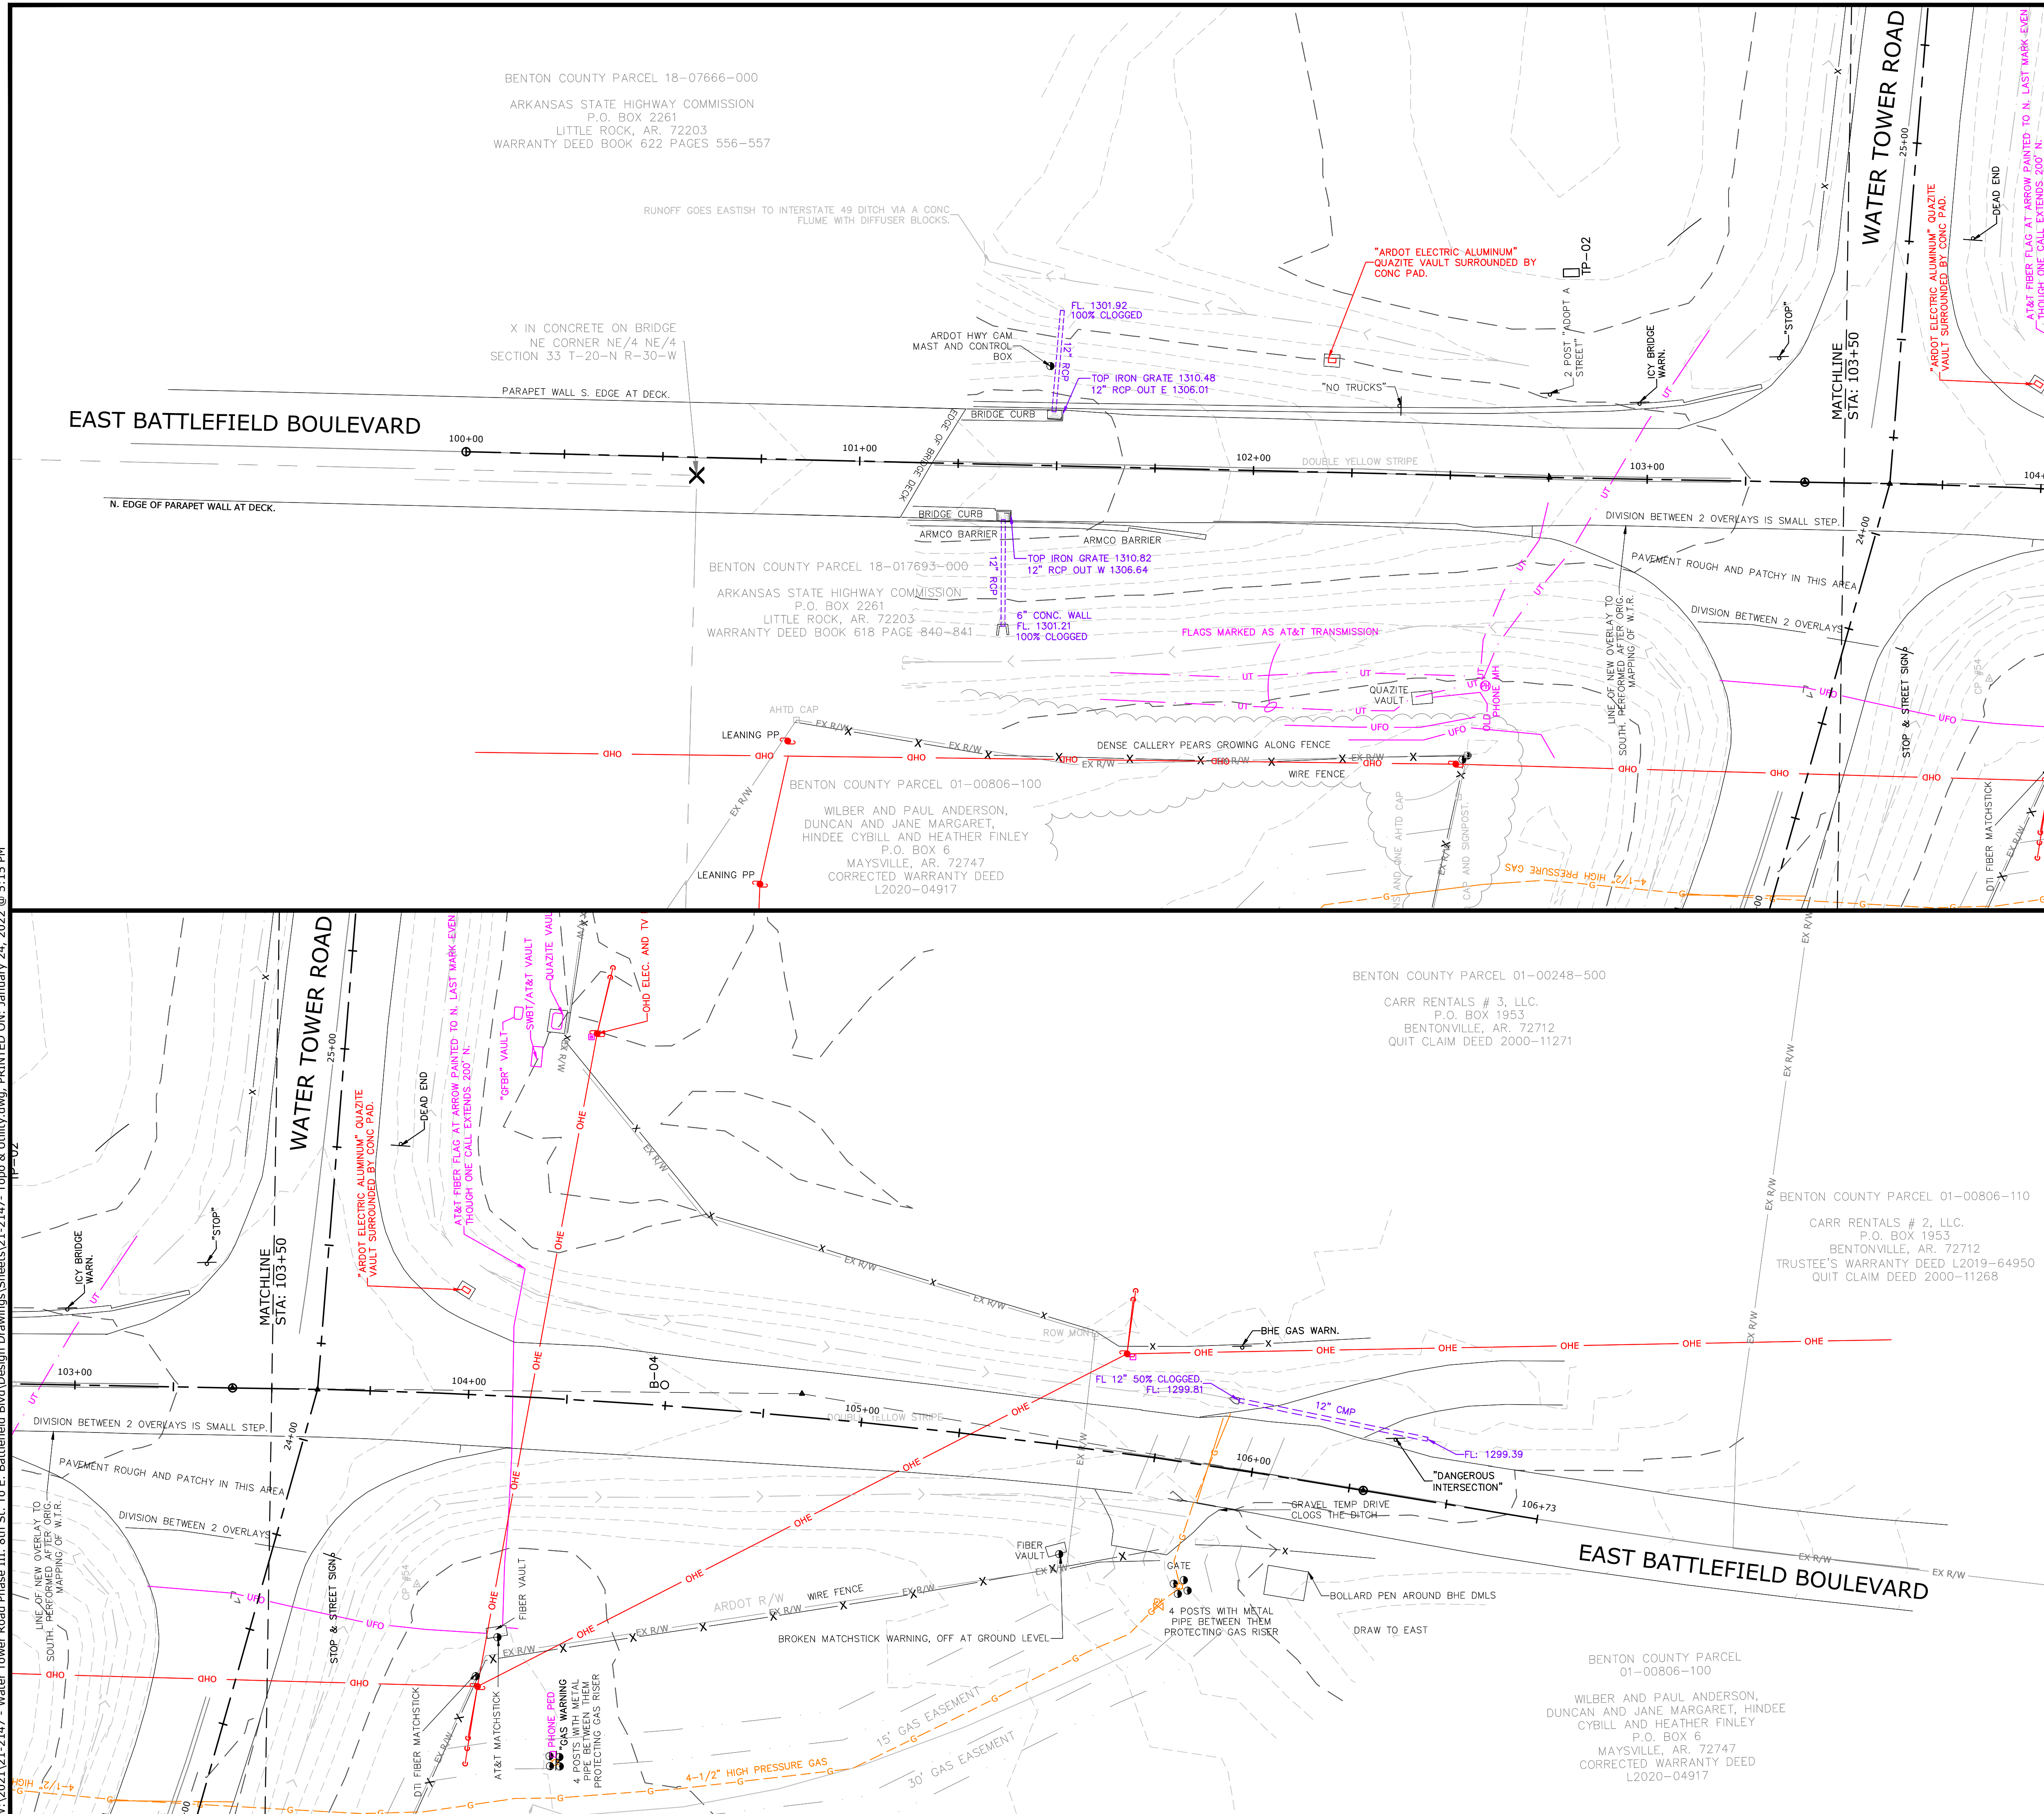


EXISTING LEGEND

 
	W	WATER LINE
	G	GAS LINE
	UT	UNDERGROUND TELEPHONE
	UFO	UNDERGROUND FIBER
	OHE	OVERHEAD ELECTRIC
	OHD	OVERHEAD UTILITY
		STORM DRAINAGE PIPE
	X	FENCE
	23+00	ROAD CENTERLINE
		DITCH FLOWLINE
	EX R/W	RIGHT OF WAY
		EASEMENT
		FIRE HYDRANT
		WATER METER
		WATER VALVE
		GAS VALVE
		PHONE MANHOLE
		WATER FAUCET
		POWER POLE
		GUY WIRE w/ ANCHOR
		GAS METER
		TELEPHONE PEDESTAL
		CABLE TV PEDESTAL
		SIGN (AS NOTED)
		POST (AS NOTED)
		CONTROL POINT
		BUSH
		TREE (TO REMAIN)
		TREE (TO BE REMOVED)

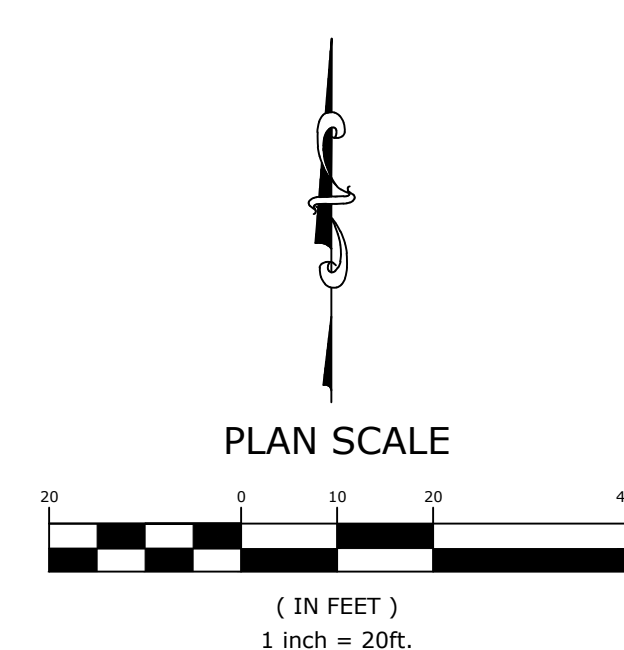

W:\2021\21-2147 - Water Tower Road Phase III. 8th St. To E. Battlfield Blvd\Design Drawings\Sheets\21-2147- Typical Sections.dwg, PRINTED ON: January 25, 2022 @ 8:48 AM

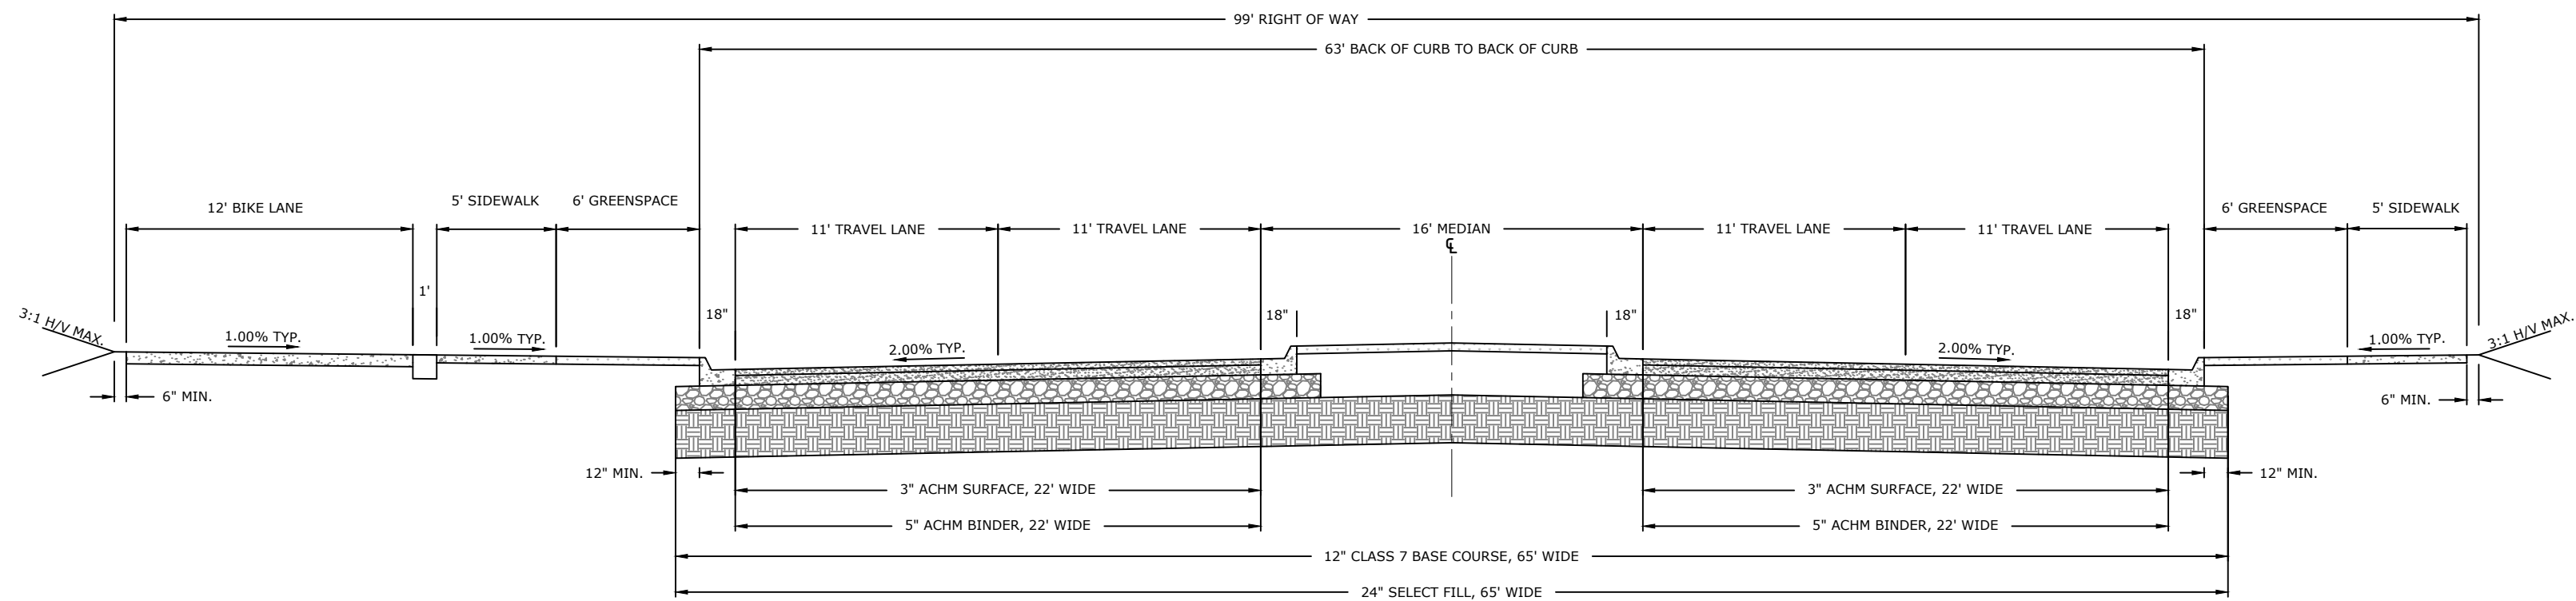

WATER TOWER ROAD 4-LANE W/
MEDIAN SECTION
(BASED ON STANDARD MASTER STREET PLAN SECTIONS
AND BIKE-PED CONNECT BENTONVILLE)

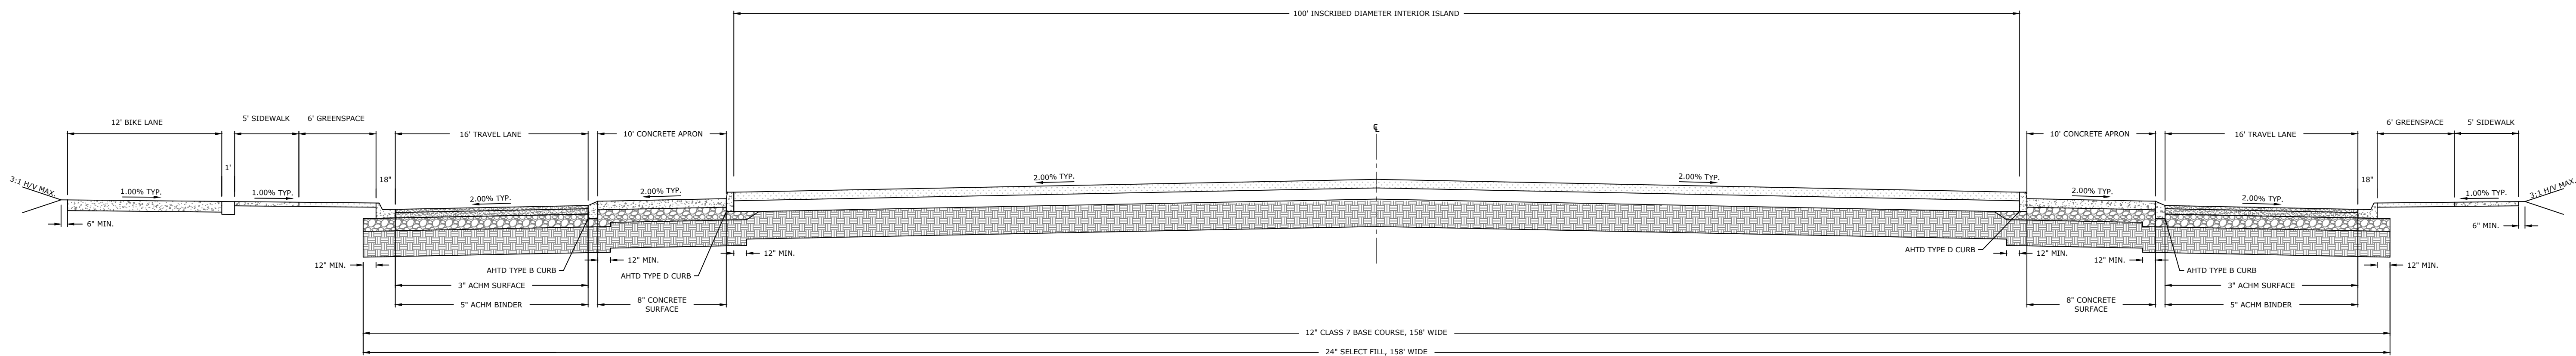

WATER TOWER ROAD
ROUNDBOUT SECTION

PRELIMINARY
NOT FOR
CONSTRUCTION

ORIGINAL SIGNATURE ON FILE

WATER TOWER RD. PH.3
SE. 6TH ST. TO BATTLEFIELD BLVD
BENTONVILLE, AR





REVISIONS		DESCRIPTION
REV	DATE	

TYPICAL
SECTIONS-
WATER TOWER
ROAD

DESIGNED BY: ELA	DRAWN BY : WAS
DATE: 1/25/2022	REVISION: 30%
SCALE: NTS	SHEET NUMBER: 21-2147

TS-1

W:\2021\21-2147 - Water Tower Road Phase III. 8th St. To E. Battlefield Blvd\Design Drawings\Sheets\21-2147- Plan & Profile.dwg, PRINTED ON: January 31, 2022 @ 12:10 PM

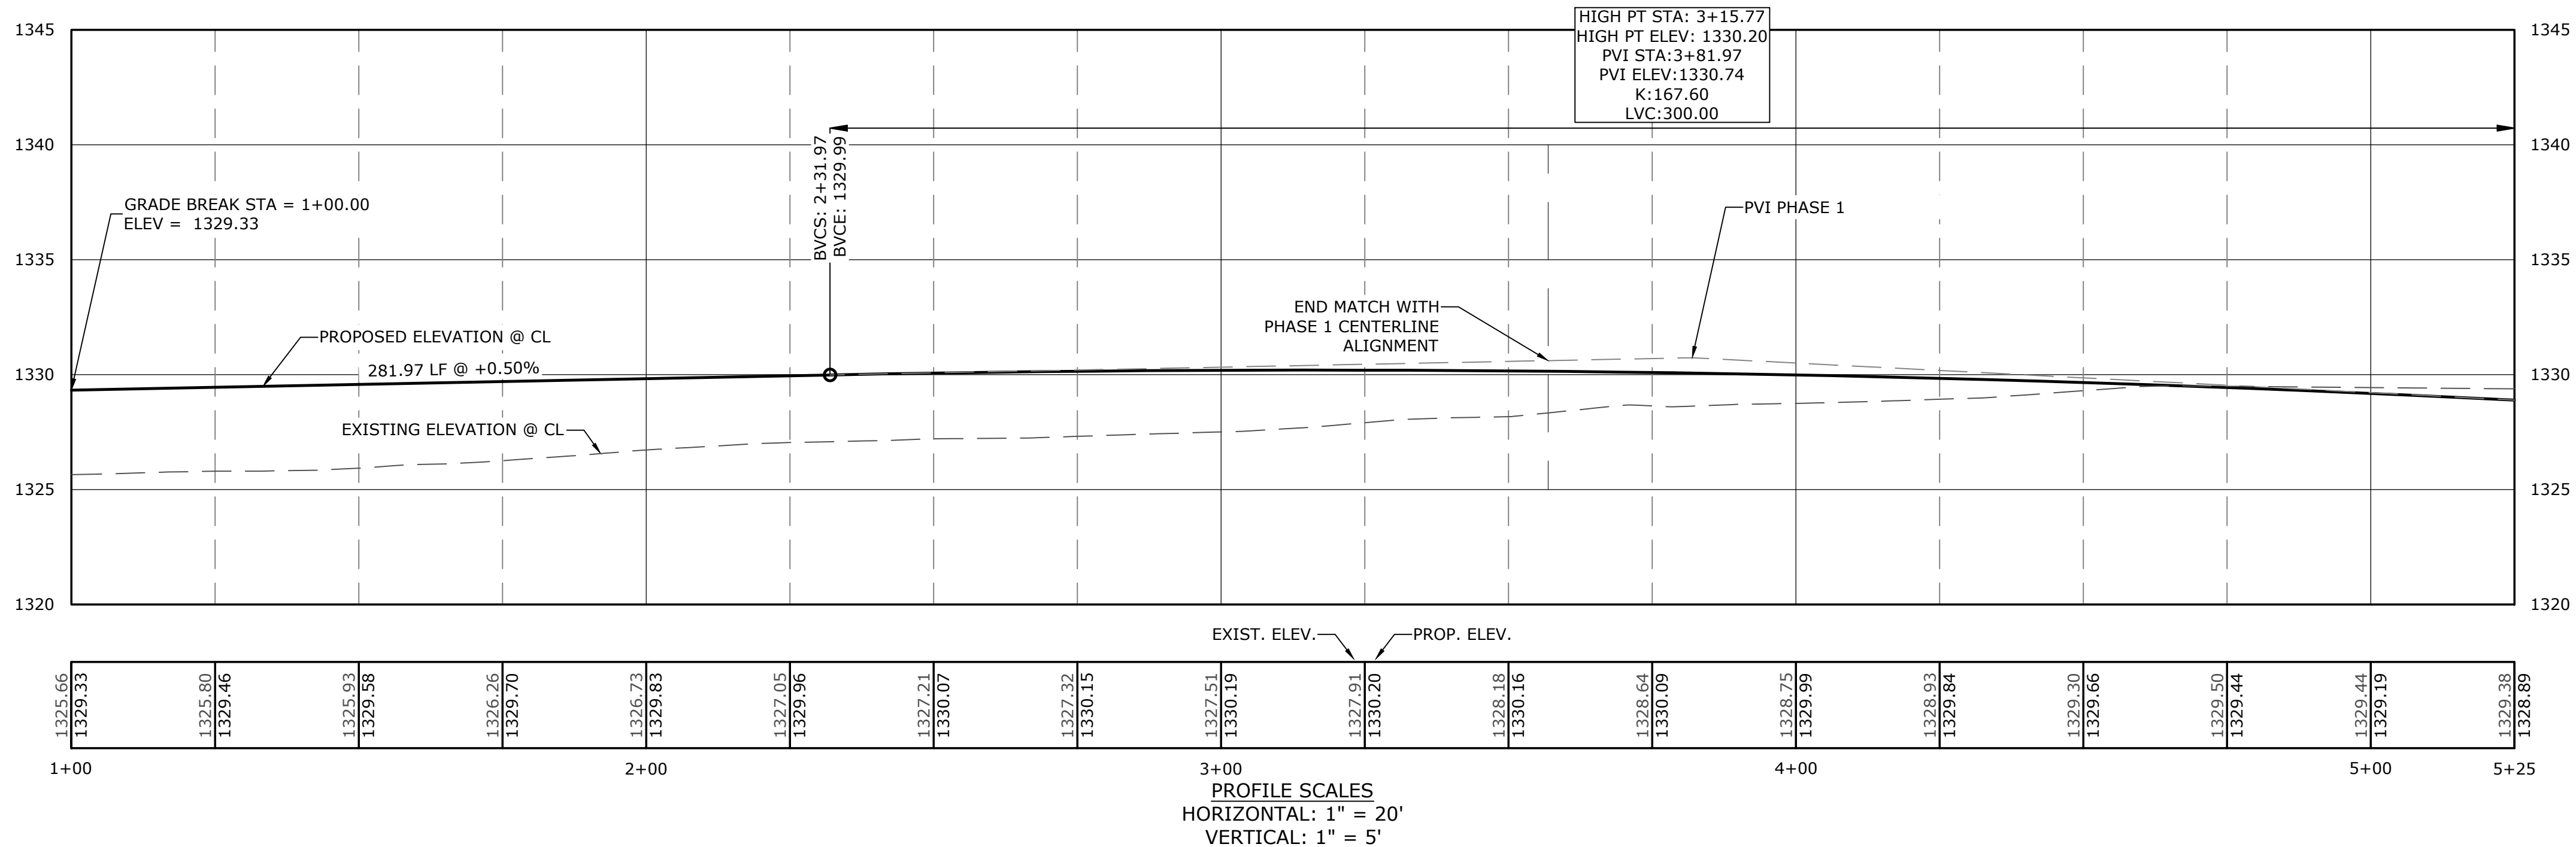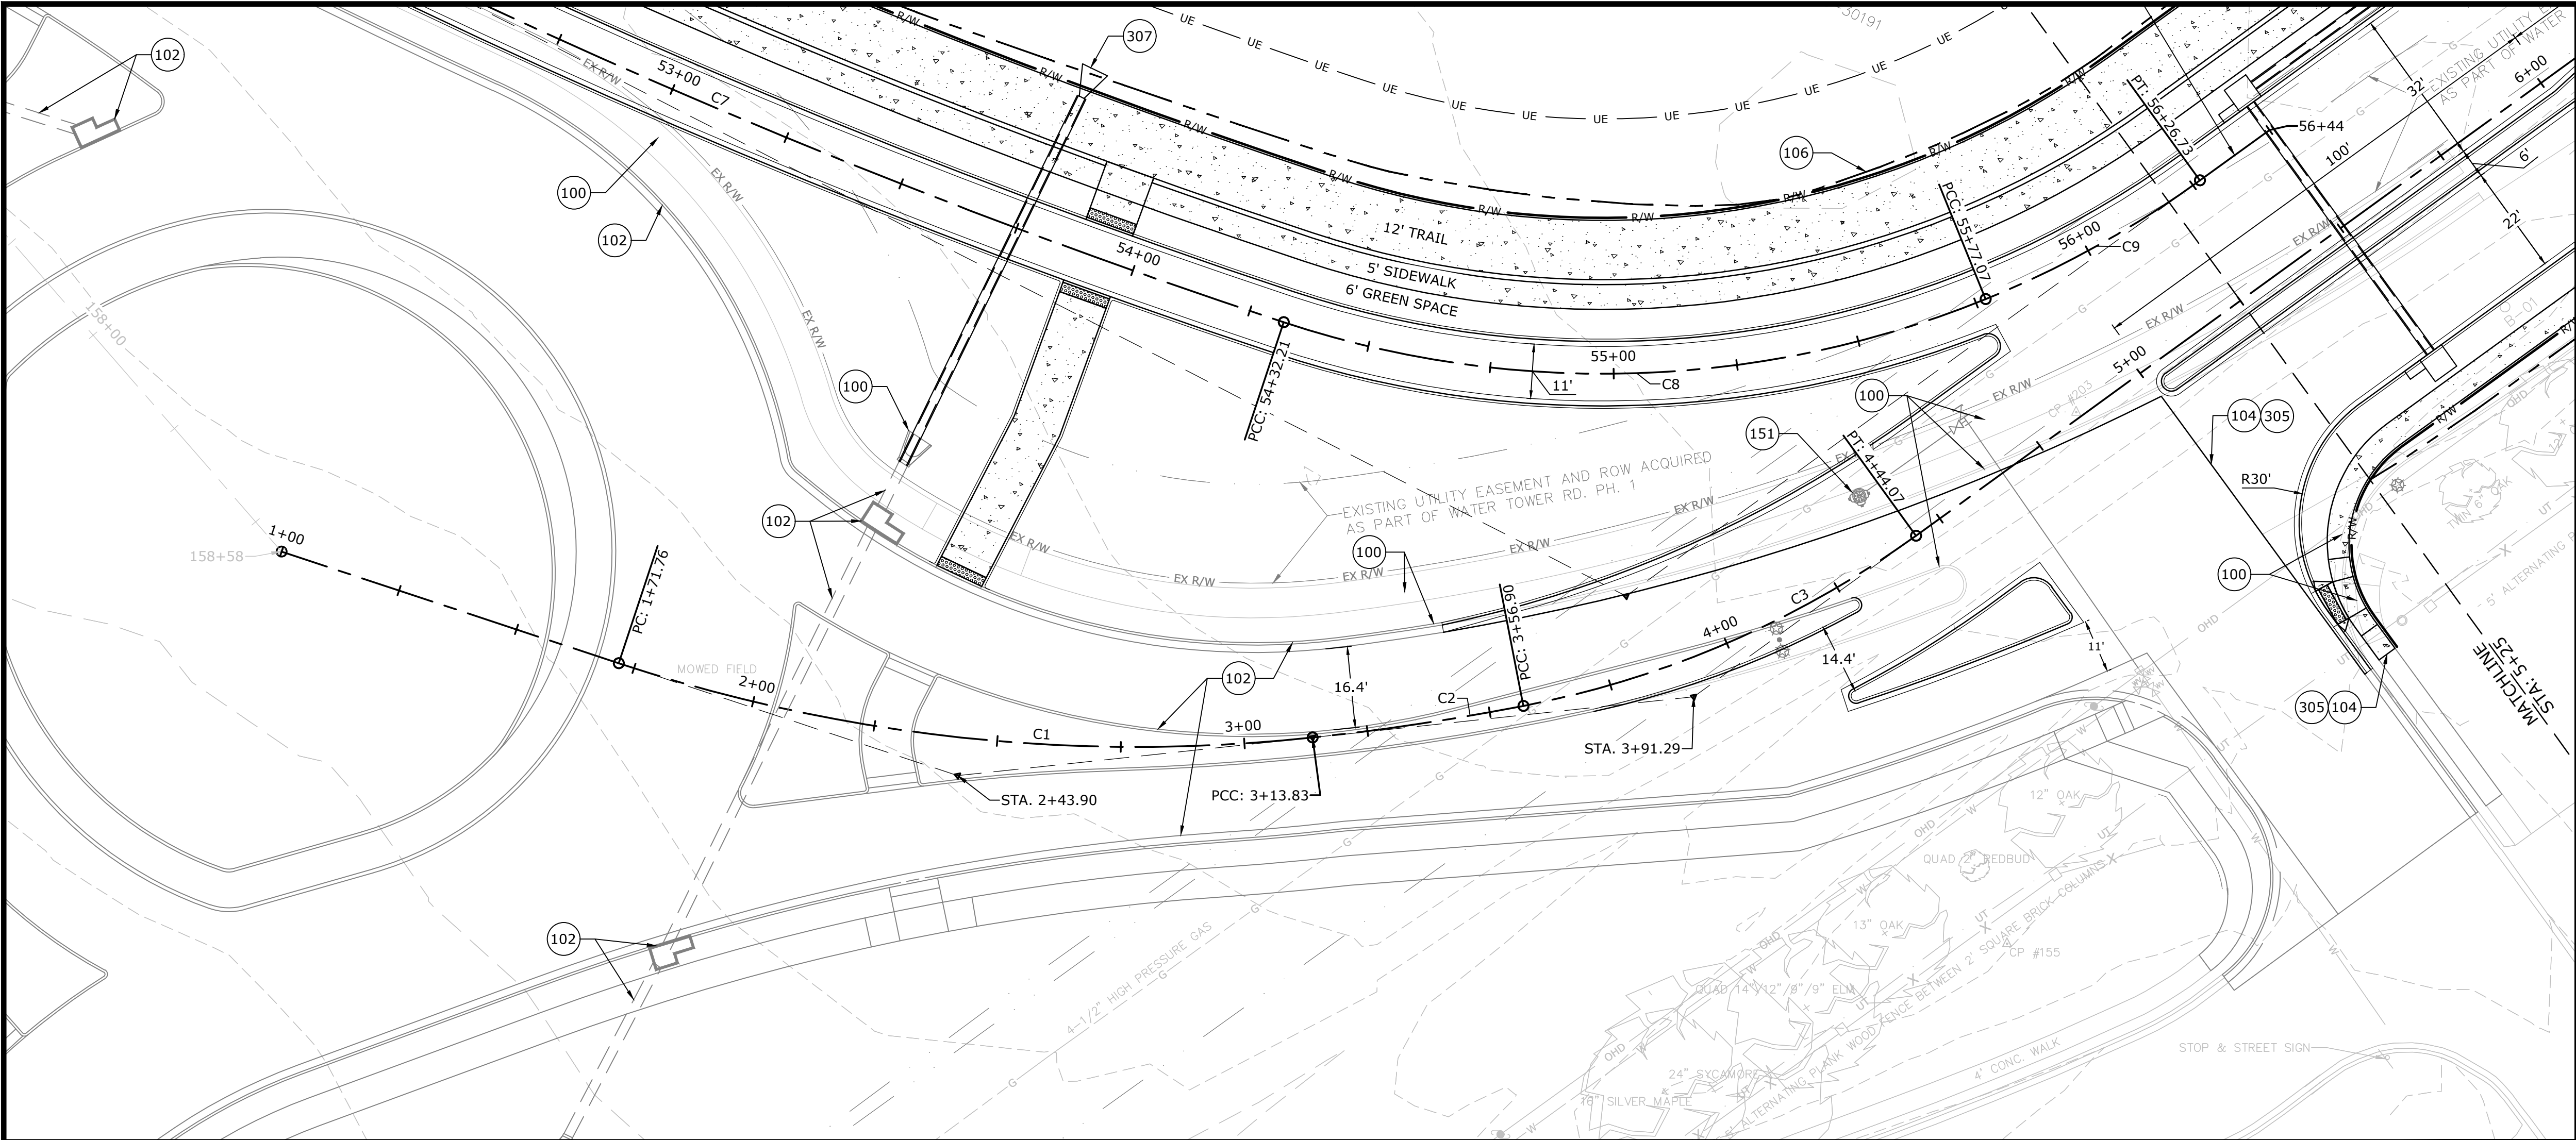

PROPOSED LEGEND

- CURB AND GUTTER
- CONCRETE PAVEMENT, SIDEWALK, AND TRAIL
- ASPHALT PAVEMENT
- GRAVEL DRIVEWAY
- STORM DRAIN STRUCTURE
- FLARED END SECTION
- STORM DRAIN
- CENTERLINE
- CATCHLINE / LIMIT OF GRADING
- BARBED WIRE FENCE
- RIGHT OF WAY
- UTILITY EASEMENT


EXISTING LEGEND

- SANITARY SEWER LINE
- WATER LINE
- GAS LINE
- UNDERGROUND TELEPHONE
- UNDERGROUND ELECTRIC
- UNDERGROUND TELEVISION
- UNDERGROUND FIBER
- OVERHEAD ELECTRIC
- STORM DRAINAGE PIPE
- FENCE
- ROAD CENTERLINE
- DITCH FLOWLINE
- EASEMENT LINE
- GRAVEL LINE
- PHASE 1 CENTERLINE
- FIRE HYDRANT
- WATER METER
- WATER VALVE
- WATER FAUCET
- SANITARY SEWER MH
- CLEAN-OUT
- DRAINAGE MH
- POWER POLE
- GUY WIRE w/ ANCHOR
- GAS METER
- GAS RISER
- STREET LIGHT POLE
- TELEPHONE PEDESTAL
- CABLE TV PEDESTAL
- SIGN (AS NOTED)
- POST (AS NOTED)
- BENCHMARK
- FOUND IRON PIN (AS NOTED)
- CONTROL POINT
- RR SPIKE
- BUSH
- TREE

KEYNOTES


- 100 EXISTING TO BE REMOVED AND / OR DEMOLISHED
- 101 EXISTING TO BE SALVAGED AND RETURNED TO THE OWNER
- 102 EXISTING TO REMAIN
- 103 EXISTING TO BE RELOCATED
- 104 LIMITS OF SAWCUT AND PAVEMENT REMOVAL
- 106 LIMITS OF DISTURBANCE
- 150 UTILITY LINE TO BE RELOCATED
- 151 UTILITY FACILITY TO BE RELOCATED
- 152 UTILITY POLE TO BE RELOCATED
- 305 MATCH EXISTING ELEVATION
- 307 FLARED END SECTION (TO MATCH PIPE MATERIAL)

ALIGNMENT CURVE TABLE				
CURVE #	RADIUS	CL	TL	DELTA
C1	333.00'	142.07'	72.13'	24°26'41"
C2	510.00'	43.06'	21.54'	4°50'16"
C3	200.00'	87.17'	44.29'	24°58'24"
C4	510.00'	364.19'	190.25'	40°54'53"
C5	200.00'	92.45'	47.07'	26°29'09"
C6	1797.97'	288.61'	144.61'	9°11'49"
C7	1485.00'	229.16'	114.81'	8°50'30"
C8	205.50'	144.87'	75.59'	40°23'25"
C9	205.50'	49.66'	24.95'	13°50'44"

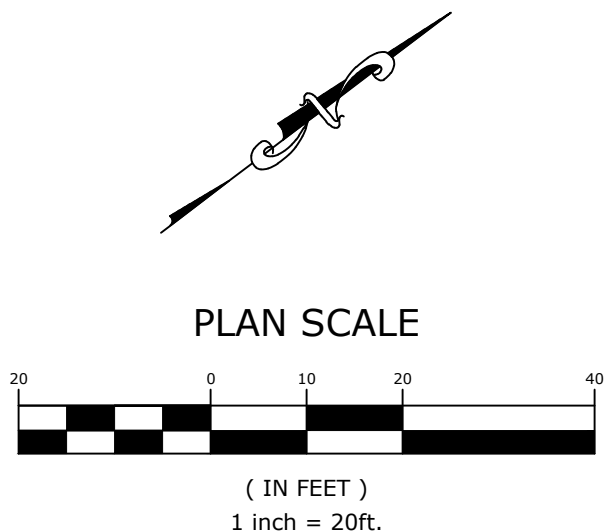


REVISIONS		DESCRIPTION	
REV	DATE	REV	DATE

W:\2021\21-2147 - Water Tower Road Phase III. 8th St. To E. Battlefield Blvd\Design Drawings\Sheets\21-2147 - Plan & Profile.dwg, PRINTED ON: February 1, 2022 @ 4:29 PM

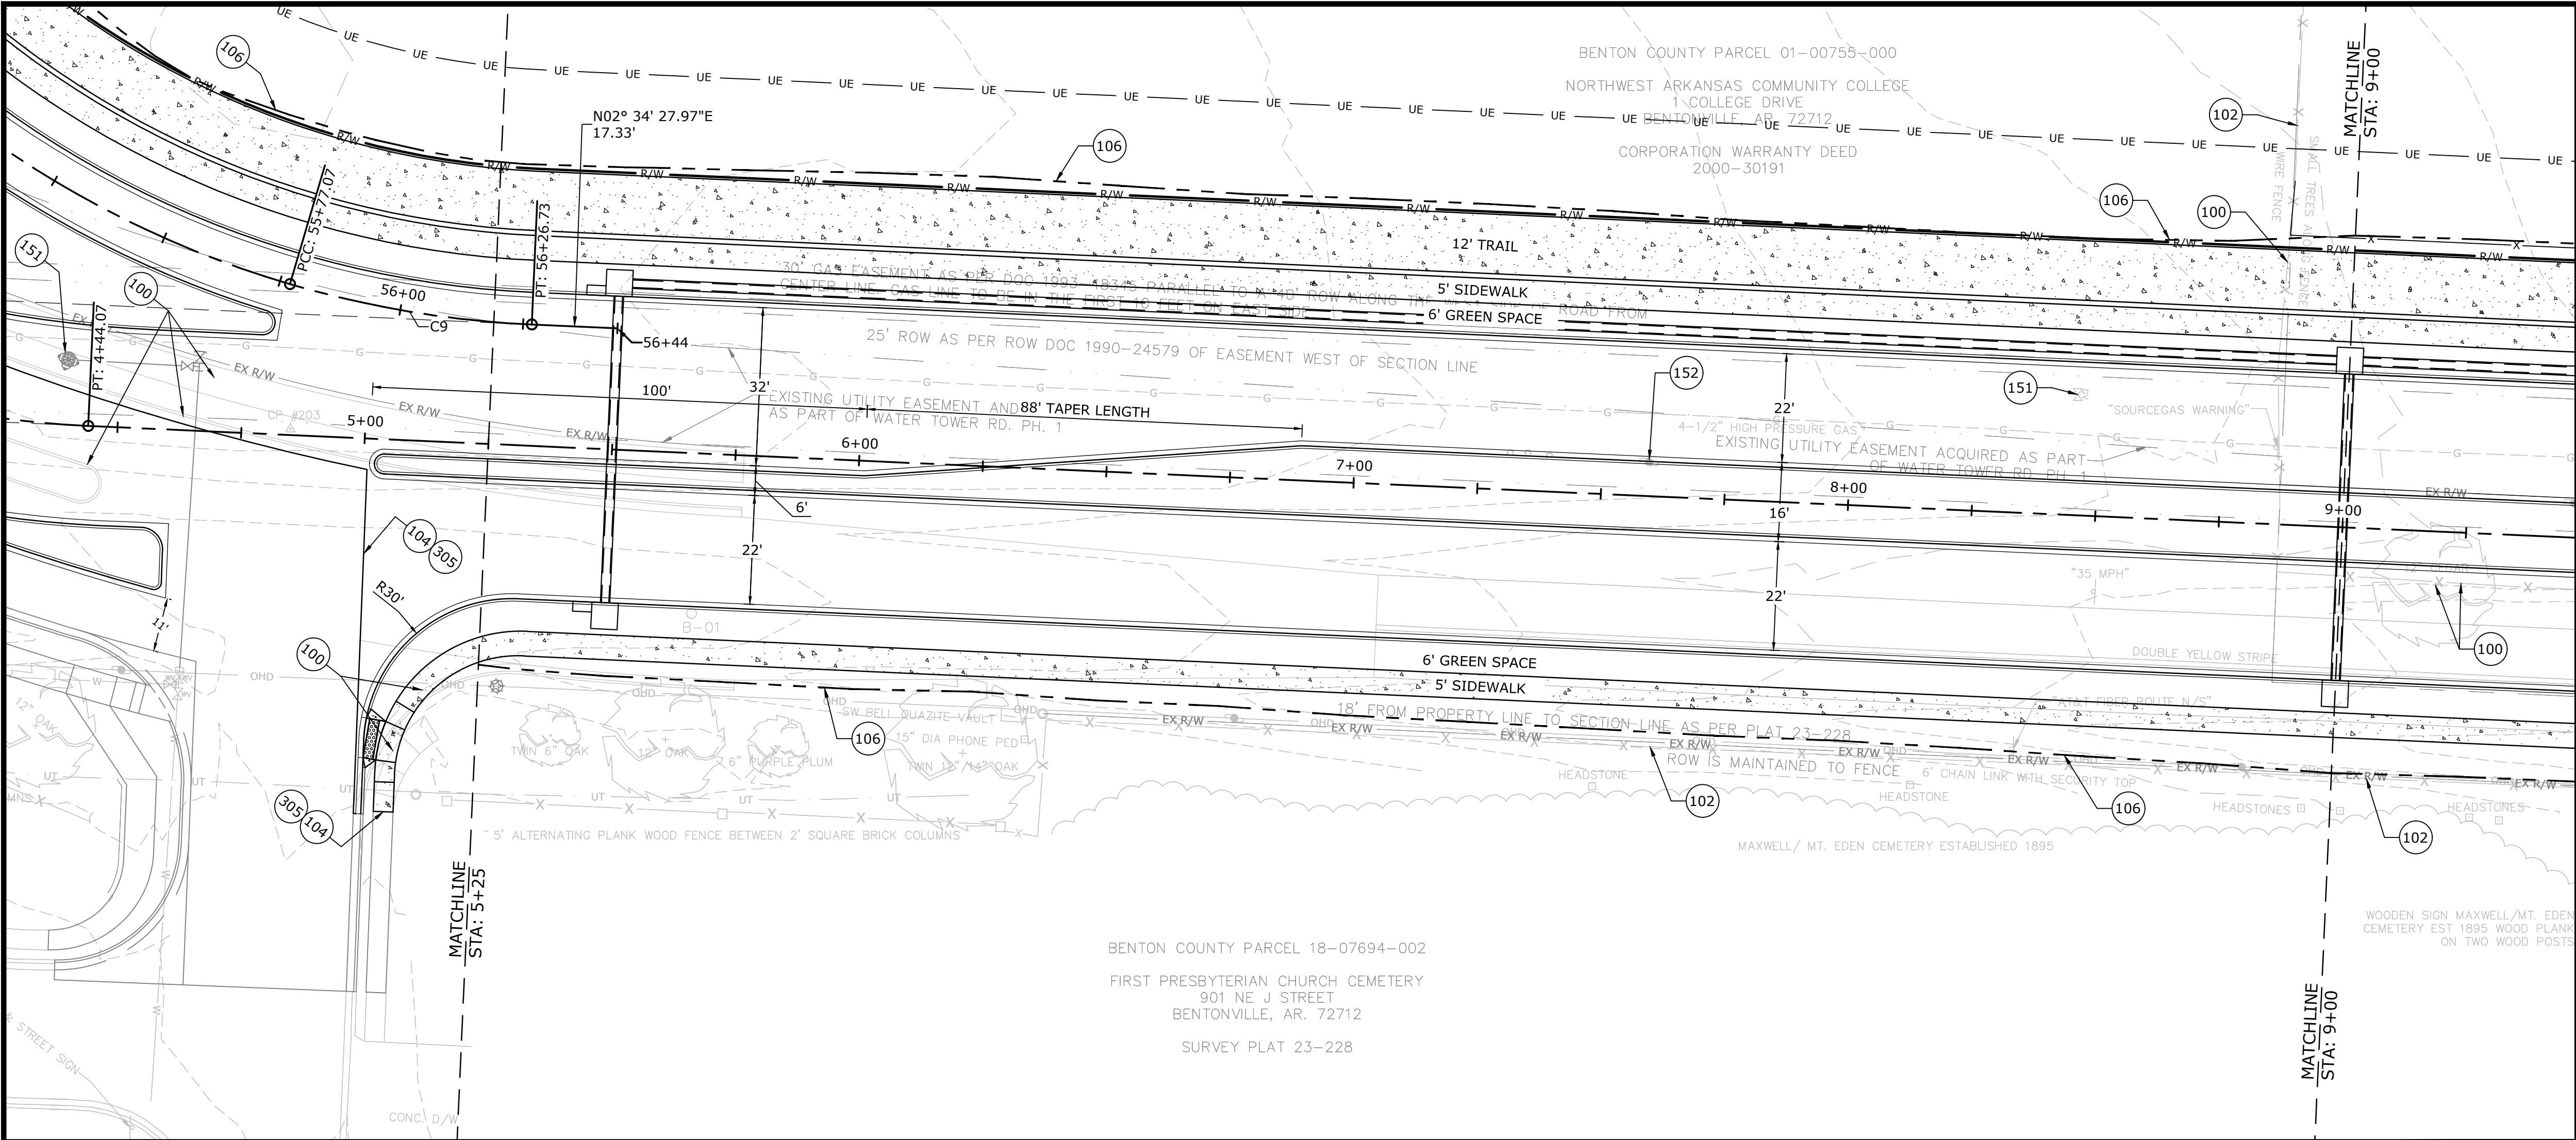

HIGH PT STA: 3+15.77
HIGH PT ELEV: 1330.20
PVI STA: 3+81.97
PVI ELEV: 1330.74
K: 167.60
LVC: 300.00

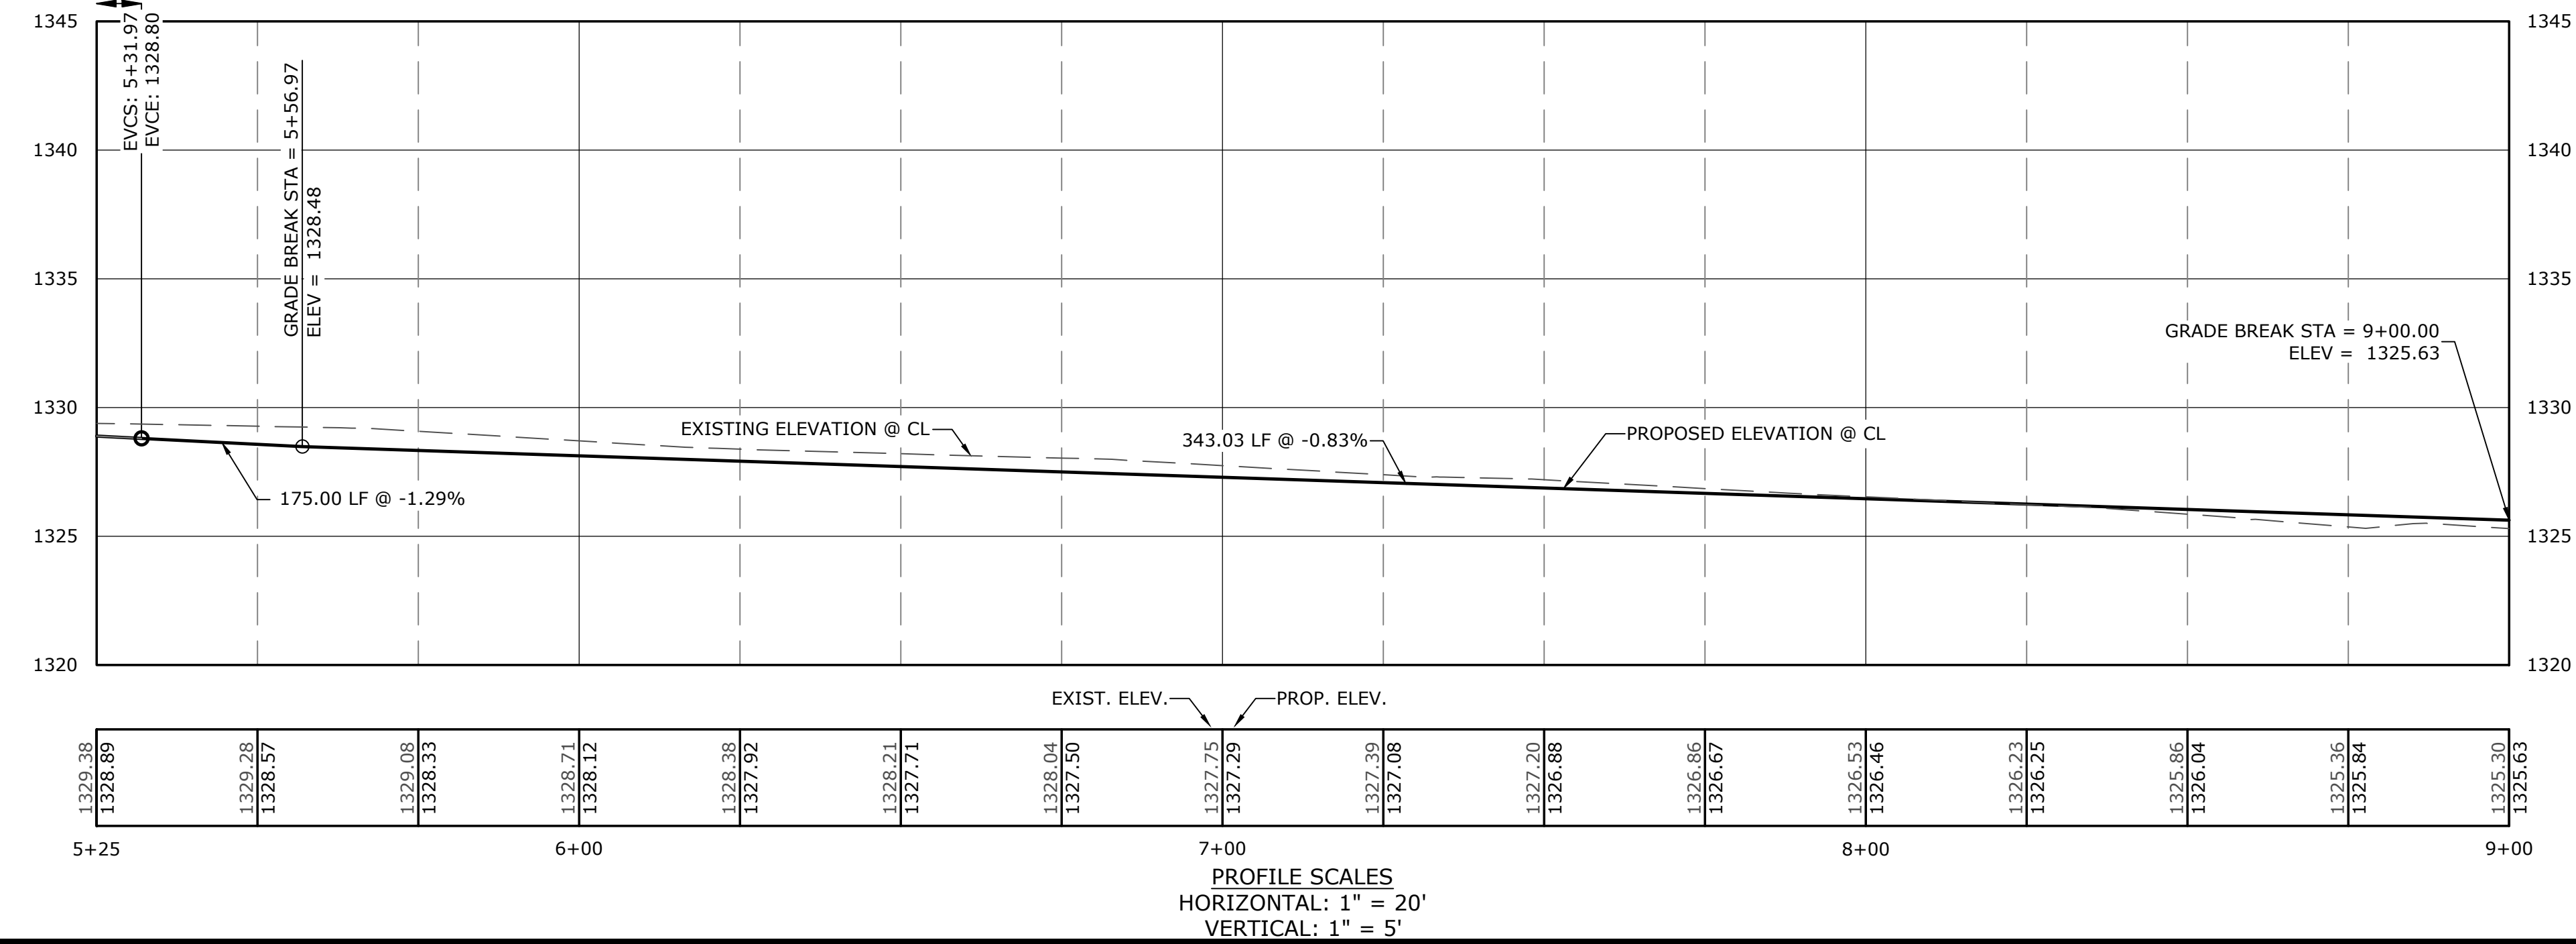

PROPOSED LEGEND

- CURB AND GUTTER
- CONCRETE PAVEMENT, SIDEWALK, AND TRAIL
- ASPHALT PAVEMENT
- GRAVEL DRIVEWAY
- STORM DRAIN STRUCTURE
- FLARED END SECTION
- STORM DRAIN
- CENTERLINE
- CATCHLINE / LIMIT OF GRADING
- BARBED WIRE FENCE
- RIGHT OF WAY
- UTILITY EASEMENT


EXISTING LEGEND

- SS SANITARY SEWER LINE
- WA WATER LINE
- GAS GAS LINE
- UGT UNDERGROUND TELEPHONE
- UGE UNDERGROUND ELECTRIC
- UGTV UNDERGROUND TELEVISION
- UFO UNDERGROUND FIBER
- OHE OVERHEAD ELECTRIC
- SD STORM DRAINAGE PIPE
- FENCE FENCE
- ROAD CENTERLINE
- DITCH FLOWLINE
- EASEMENT LINE
- GRAVEL LINE
- PHASE 1 CENTERLINE
- FIRE HYDRANT
- WATER METER
- WATER VALVE
- WATER FAUCET
- SANITARY SEWER MH
- CLEAN-OUT
- DRAINAGE MH
- POWER POLE
- GUY WIRE w/ ANCHOR
- GAS METER
- GAS RISER
- STREET LIGHT POLE
- TELEPHONE PEDESTAL
- CABLE TV PEDESTAL
- SIGN (AS NOTED)
- POST (AS NOTED)
- BENCHMARK
- FOUND IRON PIN (AS NOTED)
- CONTROL POINT
- RR SPIKE
- BUSH
- TREE

KEYNOTES

- 100 EXISTING TO BE REMOVED AND / OR DEMOLISHED
- 101 EXISTING TO BE SALVAGED AND RETURNED TO THE OWNER
- 102 EXISTING TO REMAIN
- 103 EXISTING TO BE RELOCATED
- 104 LIMITS OF SAWCUT AND PAVEMENT REMOVAL
- 106 LIMITS OF DISTURBANCE
- 150 UTILITY LINE TO BE RELOCATED
- 151 UTILITY FACILITY TO BE RELOCATED
- 152 UTILITY POLE TO BE RELOCATED
- 305 MATCH EXISTING ELEVATION
- 307 FLARED END SECTION (TO MATCH PIPE MATERIAL)

ALIGNMENT CURVE TABLE				
CURVE #	RADIUS	CL	TL	DELTA
C1	333.00'	142.07'	72.13'	24°26'41"
C2	510.00'	43.06'	21.54'	4°50'16"
C3	200.00'	87.17'	44.29'	24°58'24"
C4	510.00'	364.19'	190.25'	40°54'53"
C5	200.00'	92.45'	47.07'	26°29'09"
C6	1797.97'	288.61'	144.61'	9°11'49"
C7	1485.00'	229.16'	114.81'	8°50'30"
C8	205.50'	144.87'	75.59'	40°23'25"
C9	205.50'	49.66'	24.95'	13°50'44"

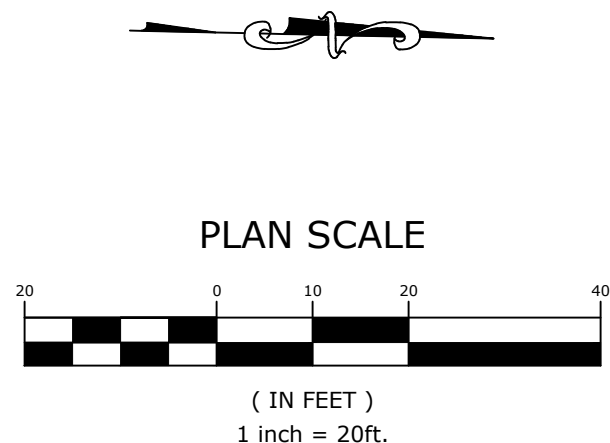

MCE
DESIGNED TO SERVE
McCLELLAND CONSULTING ENGINEERS, INC.
1580 E. STEARNS ST.
FAYETTEVILLE, ARKANSAS 72703
(479) 443-2377
HTTP://WWW.MCE.US.COM

PRELIMINARY
NOT FOR
CONSTRUCTION

ORIGINAL SIGNATURE ON FILE

WATER TOWER RD. PH. 3
SE. 6TH ST. TO BATTLEFIELD BLVD.
BENTONVILLE, AR

BENTONVILLE
B
ENGINEERING

811
Know what's below.
Call before you dig.



REVISIONS		DESCRIPTION	
REV	DATE	DESCRIPTION	

DESIGNED BY: ELA
DATE: 2/1/2022
SCALE: 1" = 20'

DRAWN BY: WAS
REVISION: 30%
JOB NUMBER: 21-2147

PP-2

W:\2021\21-2147 - Water Tower Road Phase III. 8th St. To E. Battlefield Blvd\Design Drawings\Sheets\21-2147- Plan & Profile.dwg, PRINTED ON: February 1, 2022 @ 4:30 PM

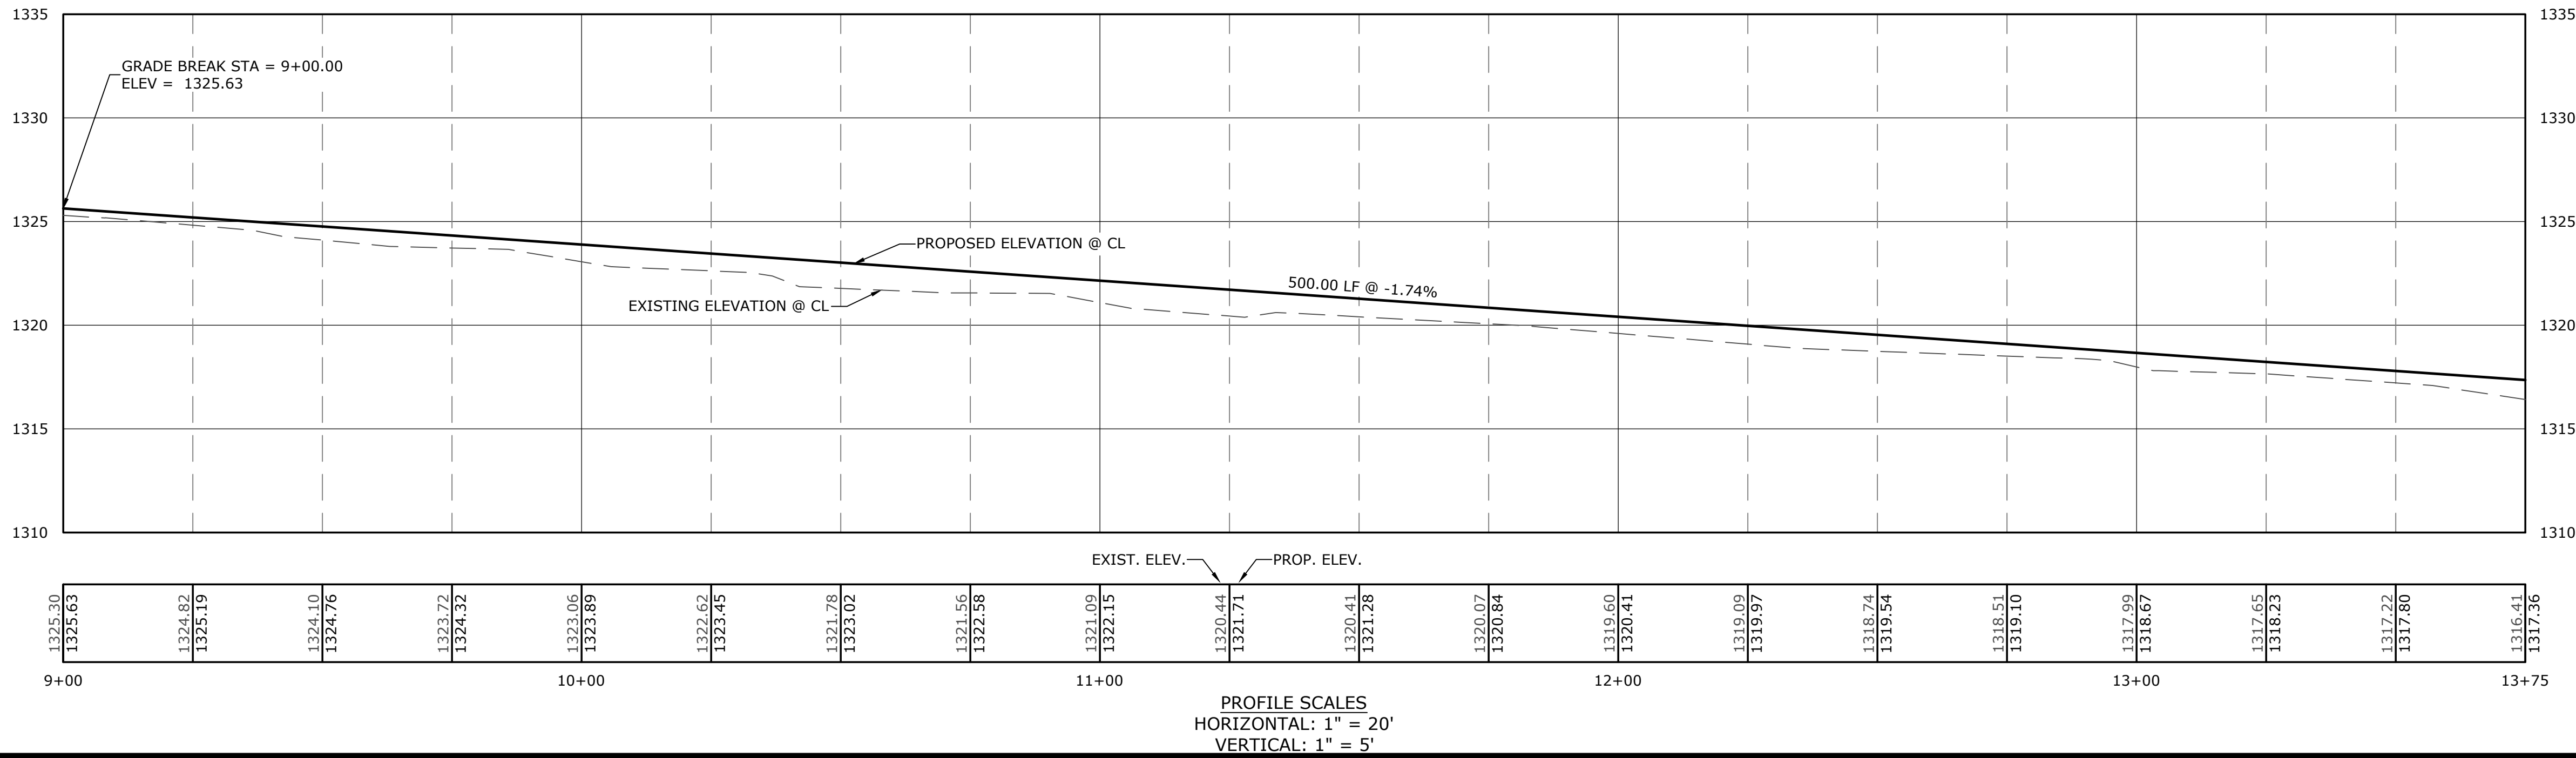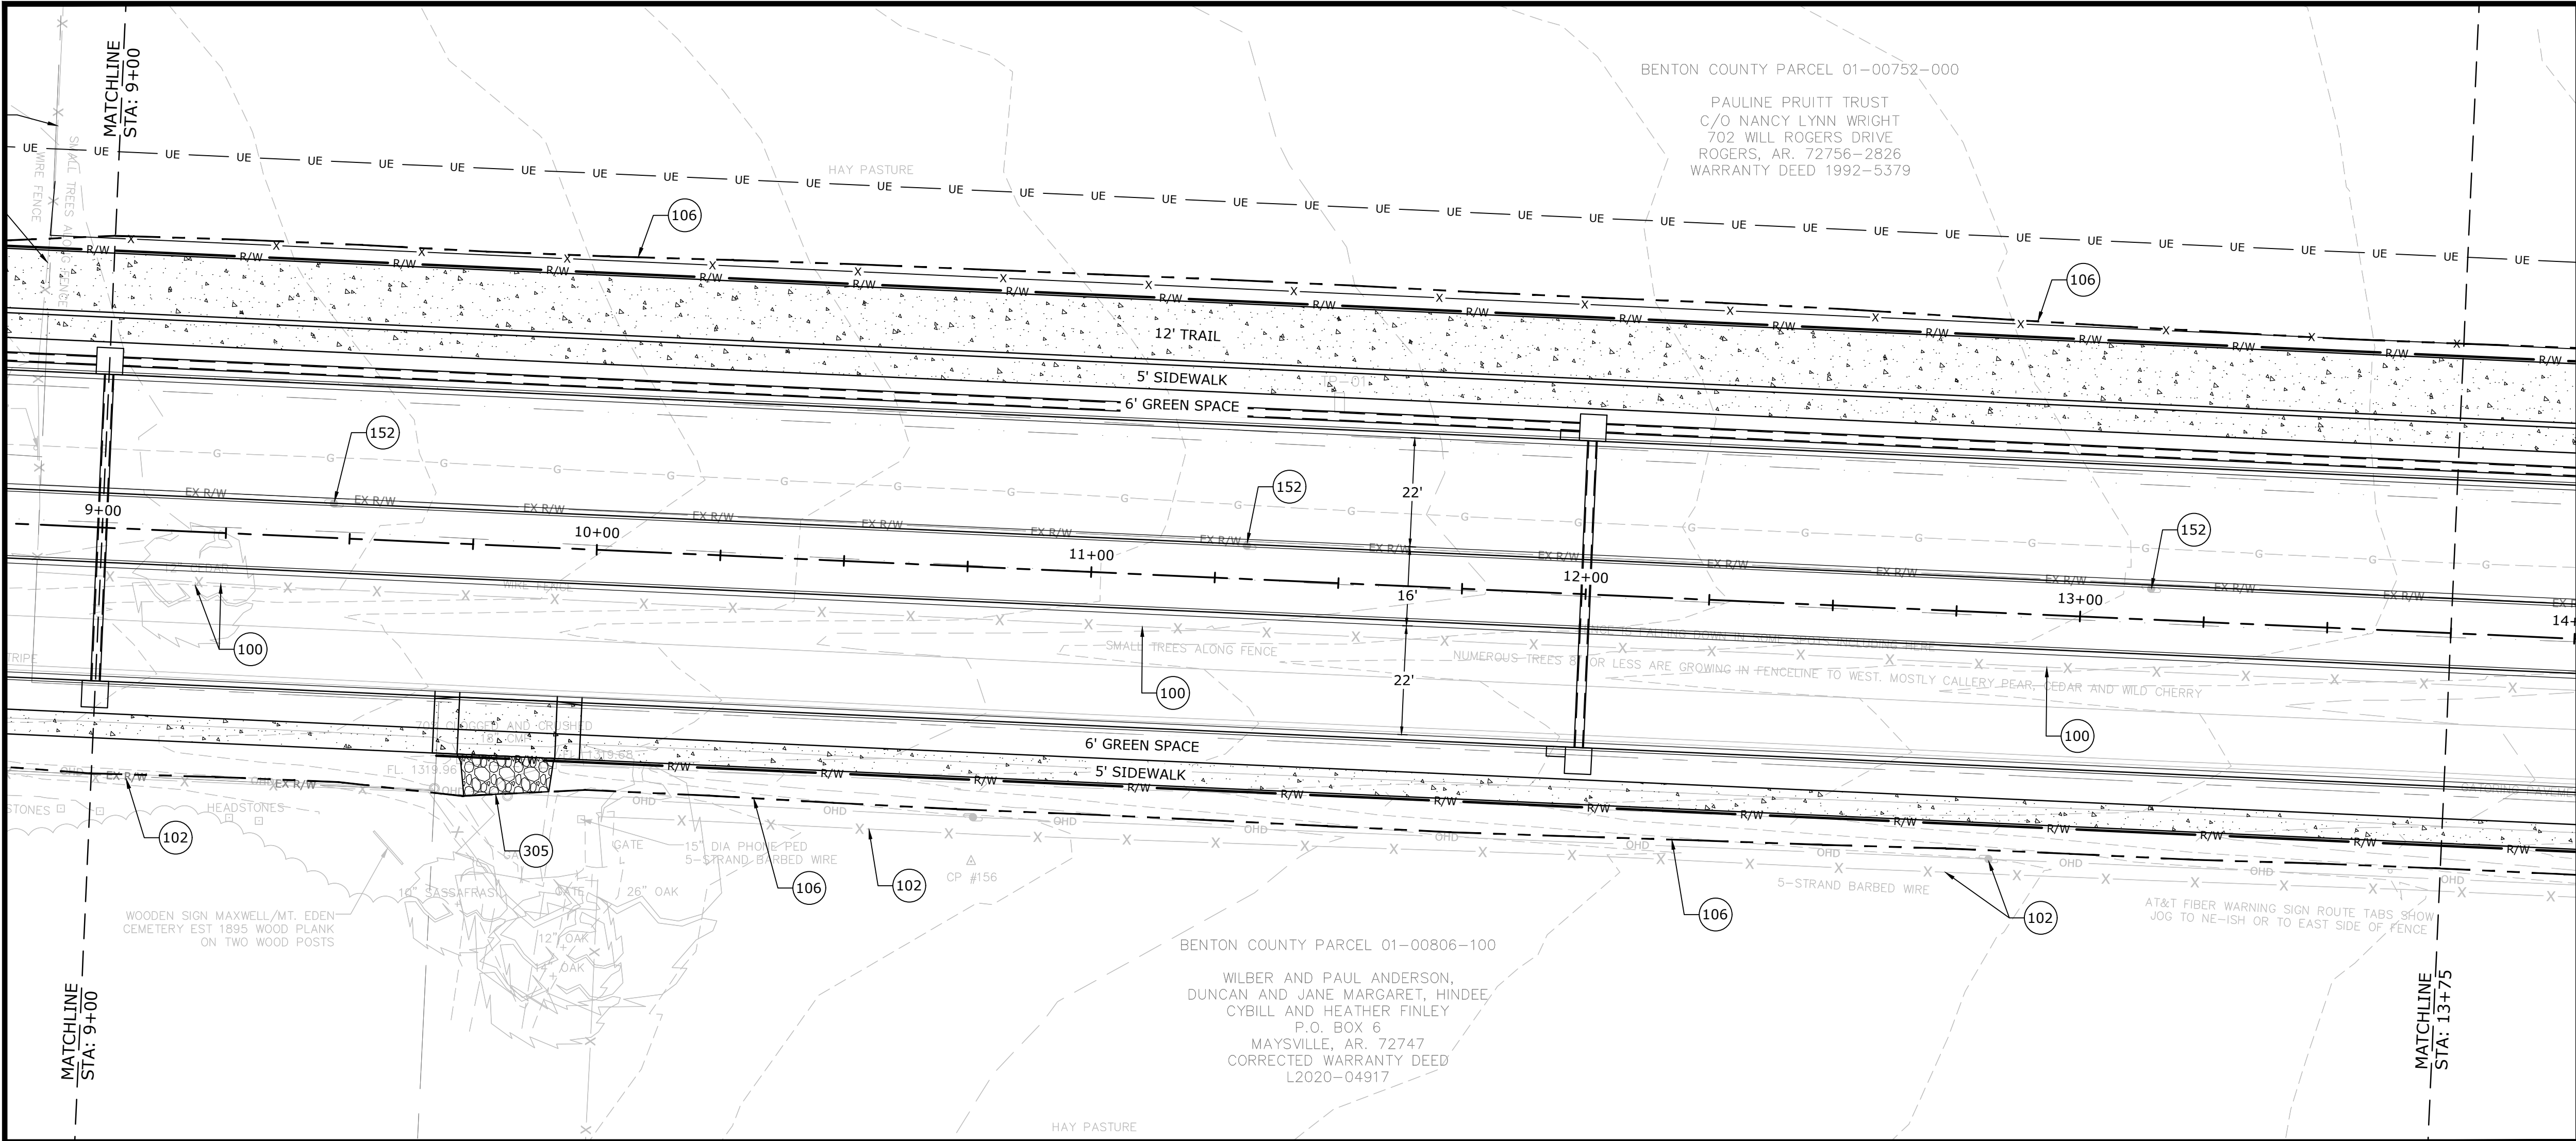

PROPOSED LEGEND

- CURB AND GUTTER
- CONCRETE PAVEMENT, SIDEWALK, AND TRAIL
- ASPHALT PAVEMENT
- GRAVEL DRIVEWAY
- STORM DRAIN STRUCTURE
- FLARED END SECTION
- STORM DRAIN
- CENTERLINE
- CATCHLINE / LIMIT OF GRADING
- BARBED WIRE FENCE
- RIGHT OF WAY
- UTILITY EASEMENT


EXISTING LEGEND

- SS SANITARY SEWER LINE
- WA WATER LINE
- GA GAS LINE
- UGT UNDERGROUND TELEPHONE
- UGE UNDERGROUND ELECTRIC
- UGTV UNDERGROUND TELEVISION
- UFO UNDERGROUND FIBER
- OHE OVERHEAD ELECTRIC
- SDM STORM DRAINAGE PIPE
- FENCE
- ROAD CENTERLINE
- DITCH FLOWLINE
- EASEMENT LINE
- GRAVEL LINE
- PHASE 1 CENTERLINE
- FIRE HYDRANT
- WATER METER
- WATER VALVE
- WATER FAUCET
- SANITARY SEWER MH
- CLEAN-OUT
- DRAINAGE MH
- POWER POLE
- GUY WIRE w/ ANCHOR
- GAS METER
- GAS RISER
- STREET LIGHT POLE
- TELEPHONE PEDESTAL
- CABLE TV PEDESTAL
- SIGN (AS NOTED)
- POST (AS NOTED)
- BENCHMARK
- FOUND IRON PIN (AS NOTED)
- CONTROL POINT
- RR SPIKE
- BUSH
- TREE

KEYNOTES

- 100 EXISTING TO BE REMOVED AND / OR DEMOLISHED
- 101 EXISTING TO BE SALVAGED AND RETURNED TO THE OWNER
- 102 EXISTING TO REMAIN
- 103 EXISTING TO BE RELOCATED
- 104 LIMITS OF SAWCUT AND PAVEMENT REMOVAL
- 106 LIMITS OF DISTURBANCE
- 150 UTILITY LINE TO BE RELOCATED
- 151 UTILITY FACILITY TO BE RELOCATED
- 152 UTILITY POLE TO BE RELOCATED
- 305 MATCH EXISTING ELEVATION
- 307 FLARED END SECTION (TO MATCH PIPE MATERIAL)

ALIGNMENT CURVE TABLE				
CURVE #	RADIUS	CL	TL	DELTA
C1	333.00'	142.07'	72.13'	24°26'41"
C2	510.00'	43.06'	21.54'	4°50'16"
C3	200.00'	87.17'	44.29'	24°58'24"
C4	510.00'	364.19'	190.25'	40°54'53"
C5	200.00'	92.45'	47.07'	26°29'09"
C6	1797.97'	288.61'	144.61'	9°11'49"
C7	1485.00'	229.16'	114.81'	8°50'30"
C8	205.50'	144.87'	75.59'	40°23'25"
C9	205.50'	49.66'	24.95'	13°50'44"

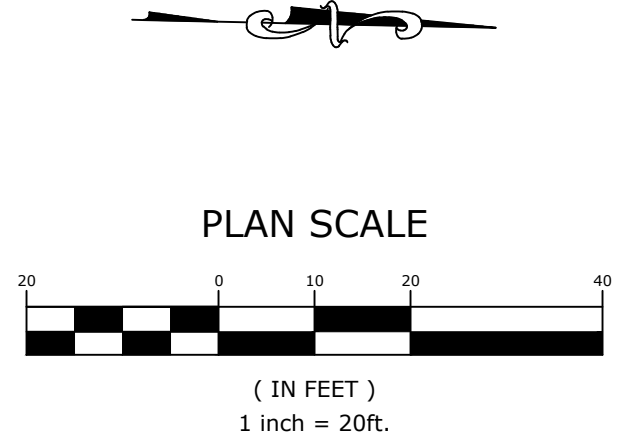

MCE **McCLELLAND**
DESIGNED TO SERVE **CONSULTING**
ENGINEERS, INC.
1580 E. STEARNS ST.
FAYETTEVILLE, ARKANSAS 72703
(479) 443-2377
HTTP://WWW.MCE.US.COM

PRELIMINARY
NOT FOR
CONSTRUCTION

ORIGINAL SIGNATURE ON FILE

WATER TOWER RD. PH. 3
SE. 6TH ST. TO BATTLEFIELD BLVD
BENTONVILLE, AR




REVISIONS		DESCRIPTION	
REV	DATE	DESCRIPTION	DATE

PLAN AND
PROFILE
WATER TOWER
RD.- STA.
9+00 TO STA.
13+75

DESIGNED BY: ELA	DRAWN BY: WAS
DATE: 2/1/2022	REVISION: 30%
SCALE: 1" = 20'	JOB NUMBER: 21-2147

PP-3


W:\2021\21-2147 - Water Tower Road Phase III. 8th St. To E. Battletield Blvd\Design Drawings\Sheets\21-2147- Plan & Profile.dwg, PRINTED ON: January 31, 2022 @ 12:12 PM

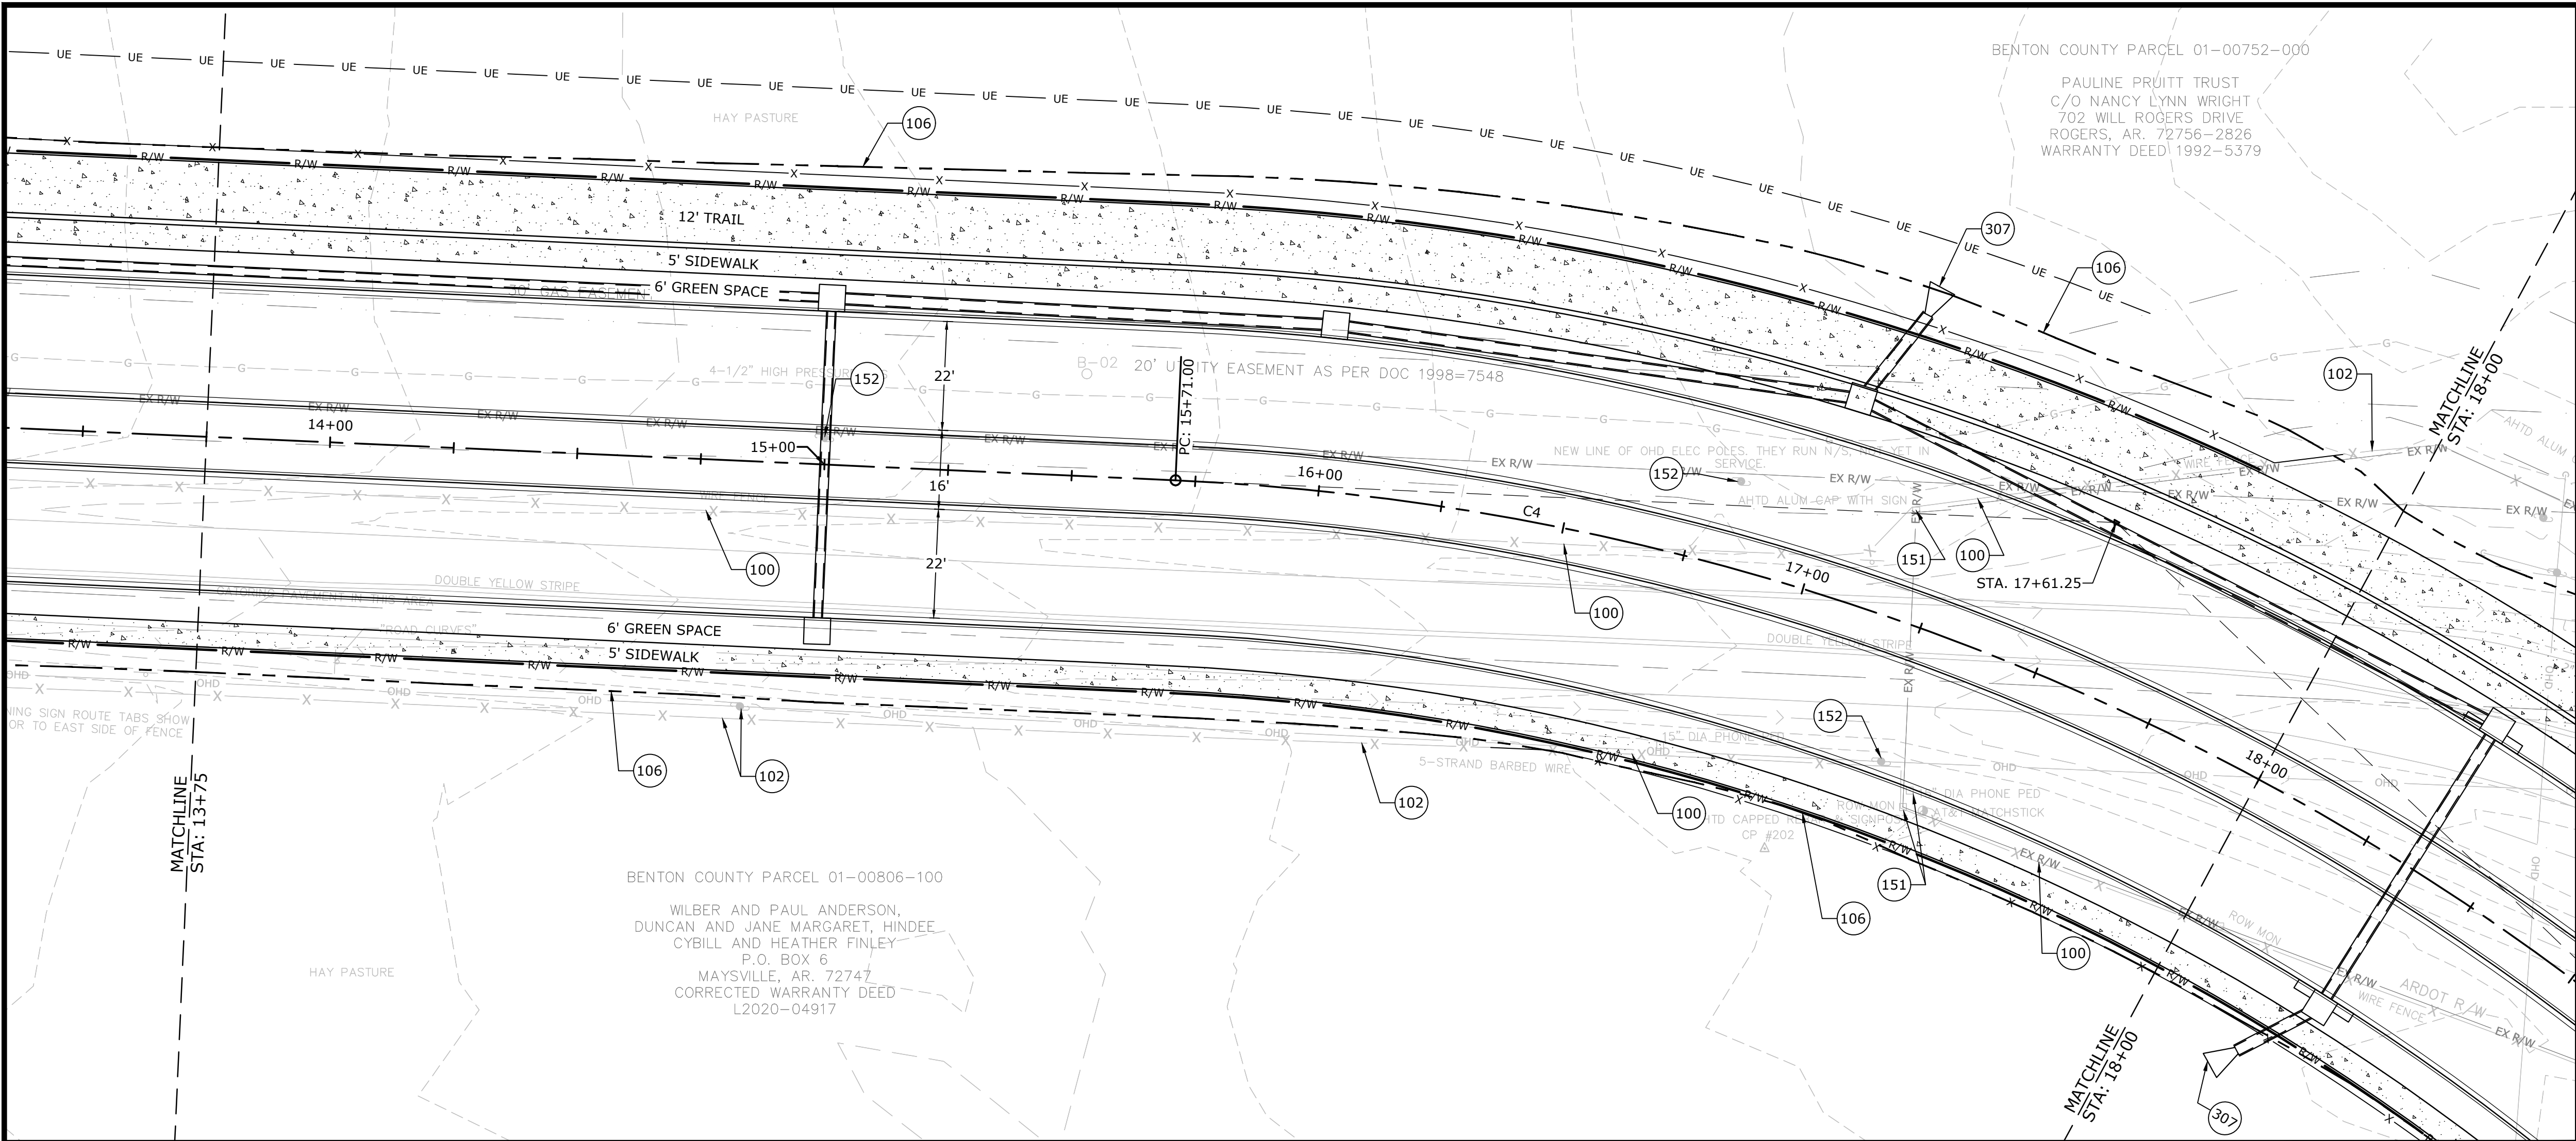


- PROPOSED LEGEND**
- CURB AND GUTTER
 - CONCRETE PAVEMENT, SIDEWALK, AND TRAIL
 - ASPHALT PAVEMENT
 - GRAVEL DRIVEWAY
 - STORM DRAIN STRUCTURE
 - FLARED END SECTION
 - STORM DRAIN
 - CENTERLINE
 - CATCHLINE / LIMIT OF GRADING
 - BARBED WIRE FENCE
 - RIGHT OF WAY
 - UTILITY EASEMENT

- EXISTING LEGEND**
- | | | | |
|------|------------------------|-----|---------------------------|
| SS | SANITARY SEWER LINE | W | WATER FAUCET |
| WA | WATER LINE | WS | SANITARY SEWER MH |
| GAS | GAS LINE | CO | CLEAN-OUT |
| UGT | UNDERGROUND TELEPHONE | DM | DRAINAGE MH |
| UGE | UNDERGROUND ELECTRIC | PP | POWER POLE |
| UGTV | UNDERGROUND TELEVISION | GW | GUY WIRE w/ ANCHOR |
| UFO | UNDERGROUND FIBER | GM | GAS METER |
| OHE | OVERHEAD ELECTRIC | GR | GAS RISER |
| OHD | OVERHEAD DRAINAGE PIPE | SLP | STREET LIGHT POLE |
| F | FENCE | TP | TELEPHONE PEDESTAL |
| RL | ROAD CENTERLINE | CTV | CABLE TV PEDESTAL |
| DF | DITCH FLOWLINE | SN | SIGN (AS NOTED) |
| EL | EASEMENT LINE | PS | POST (AS NOTED) |
| GL | GRAVEL LINE | B | BENCHMARK |
| PC | PHASE 1 CENTERLINE | FIP | FOUND IRON PIN (AS NOTED) |
| FH | FIRE HYDRANT | CP | CONTROL POINT |
| WM | WATER METER | RRS | RR SPIKE |
| WV | WATER VALVE | B | BUSH |
| | | T | TREE |

- KEYNOTES**
- 100 EXISTING TO BE REMOVED AND / OR DEMOLISHED
 - 101 EXISTING TO BE SALVAGED AND RETURNED TO THE OWNER
 - 102 EXISTING TO REMAIN
 - 103 EXISTING TO BE RELOCATED
 - 104 LIMITS OF SAWCUT AND PAVEMENT REMOVAL
 - 106 LIMITS OF DISTURBANCE
 - 150 UTILITY LINE TO BE RELOCATED
 - 151 UTILITY FACILITY TO BE RELOCATED
 - 152 UTILITY POLE TO BE RELOCATED
 - 305 MATCH EXISTING ELEVATION
 - 307 FLARED END SECTION (TO MATCH PIPE MATERIAL)


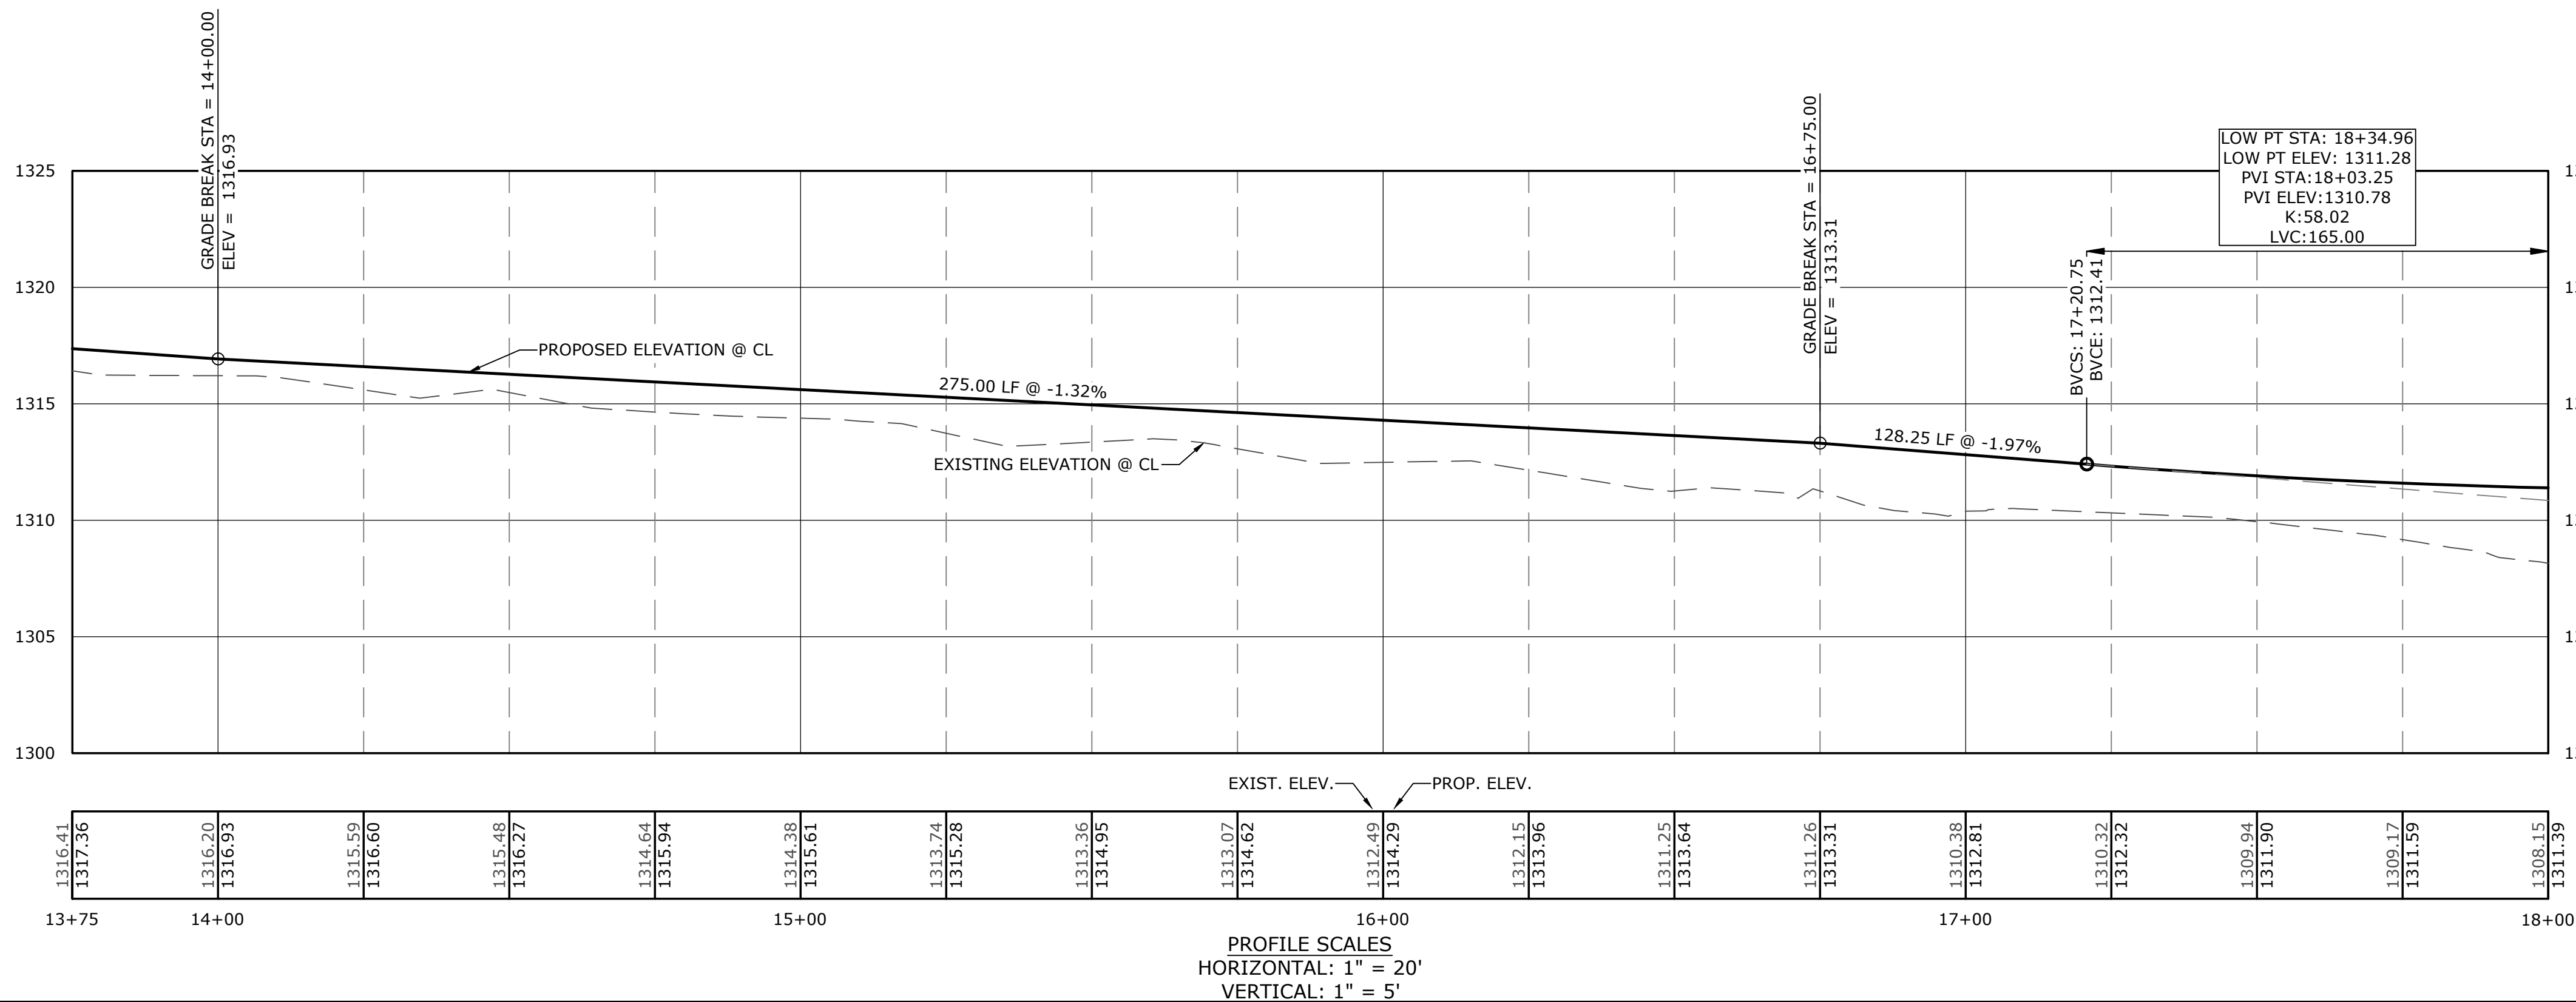


ALIGNMENT CURVE TABLE				
CURVE #	RADIUS	CL	TL	DELTA
C1	333.00'	142.07'	72.13'	24°26'41"
C2	510.00'	43.06'	21.54'	4°50'16"
C3	200.00'	87.17'	44.29'	24°58'24"
C4	510.00'	364.19'	190.25'	40°54'53"
C5	200.00'	92.45'	47.07'	26°29'09"
C6	1797.97'	288.61'	144.61'	9°11'49"
C7	1485.00'	229.16'	114.81'	8°50'30"
C8	205.50'	144.87'	75.59'	40°23'25"
C9	205.50'	49.66'	24.95'	13°50'44"

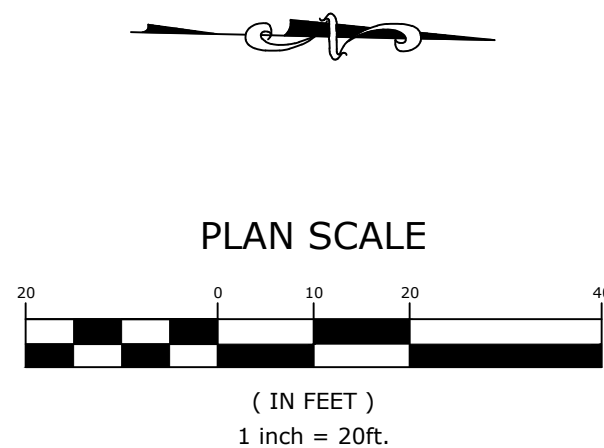

REVISIONS			
REV	DATE	DESCRIPTION	

W:\2021\21-2147 - Water Tower Road Phase III. 8th St. To E. Battiefeld Blvd\Design Drawings\Sheets\21-2147- Plan & Profile.dwg, PRINTED ON: January 31, 2022 @ 12:12 PM

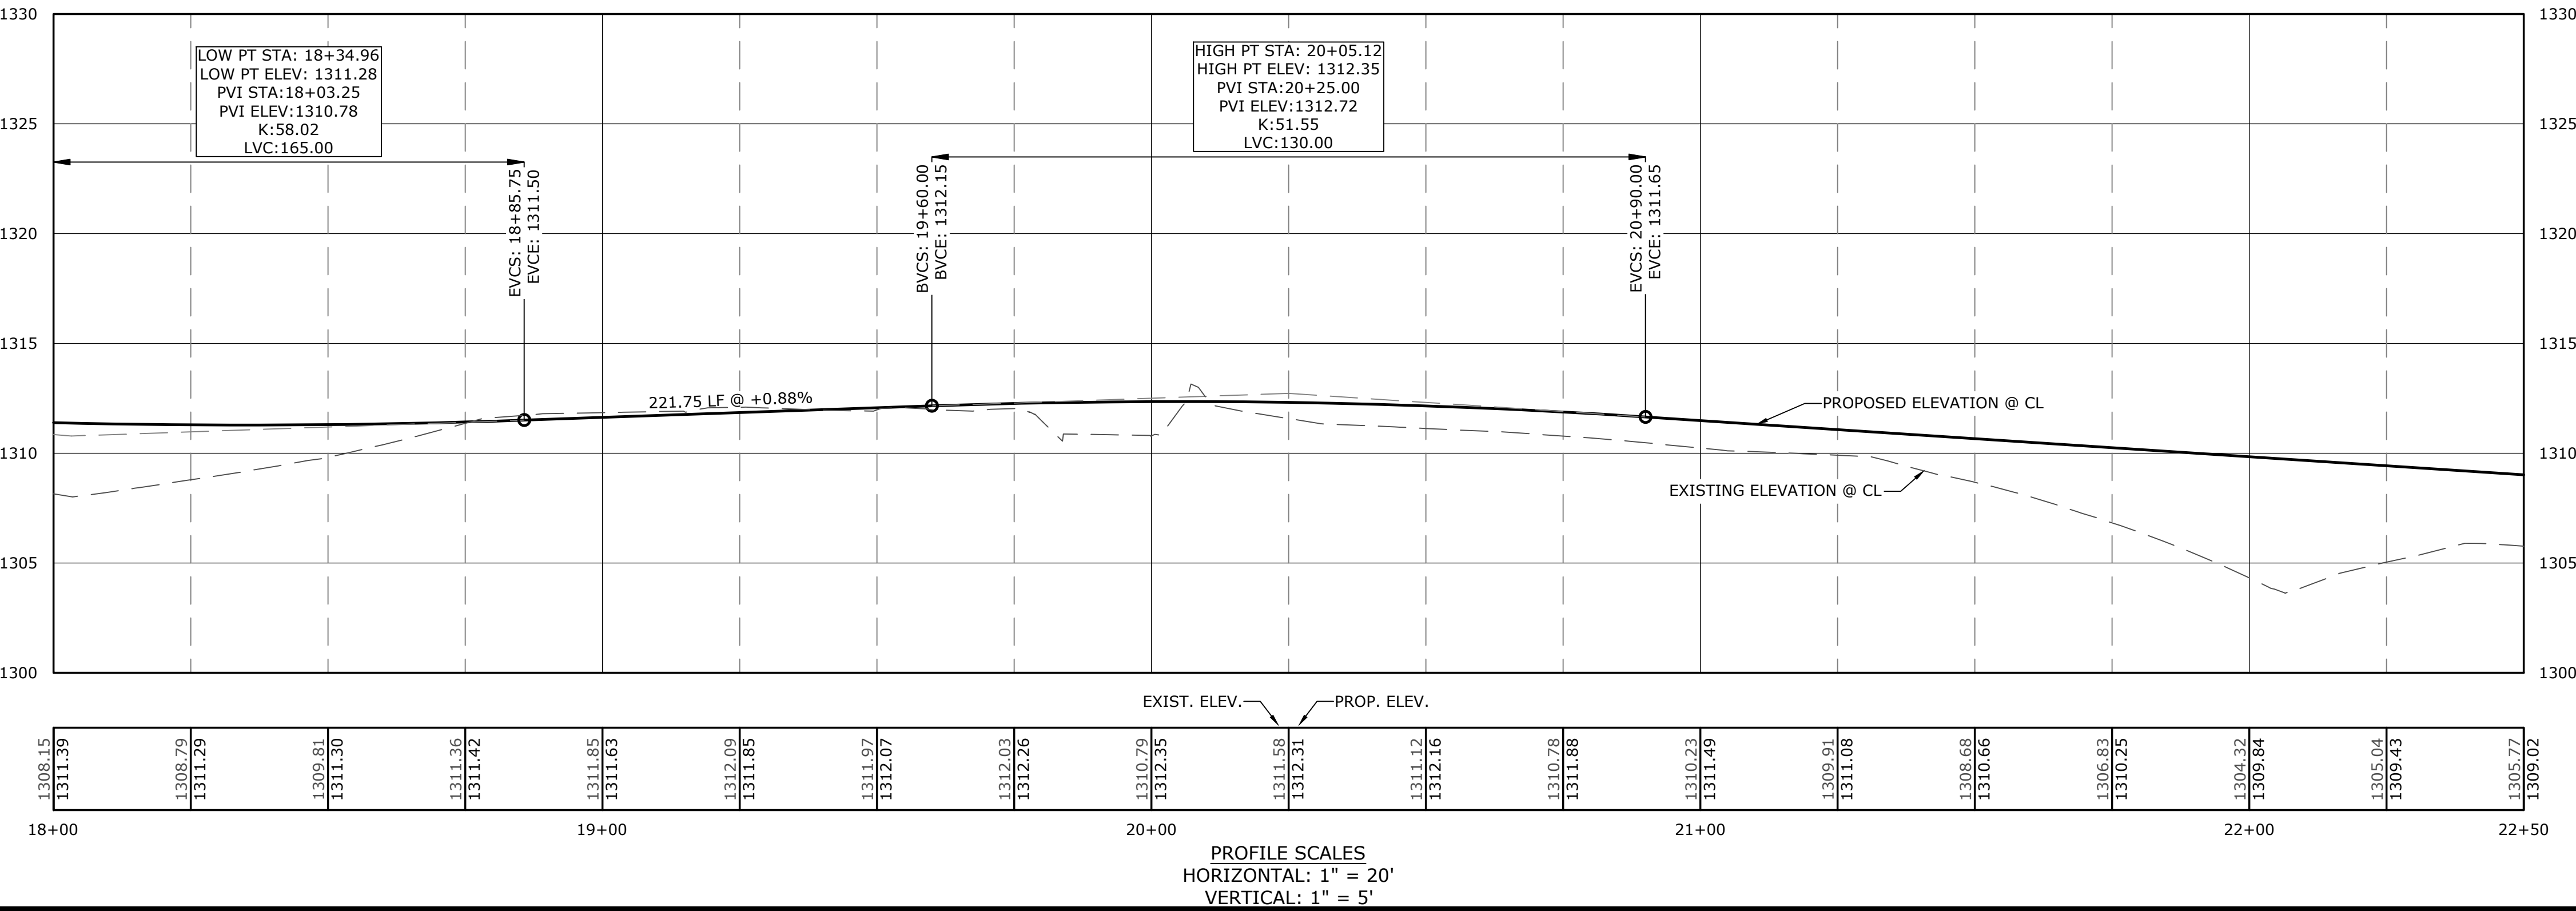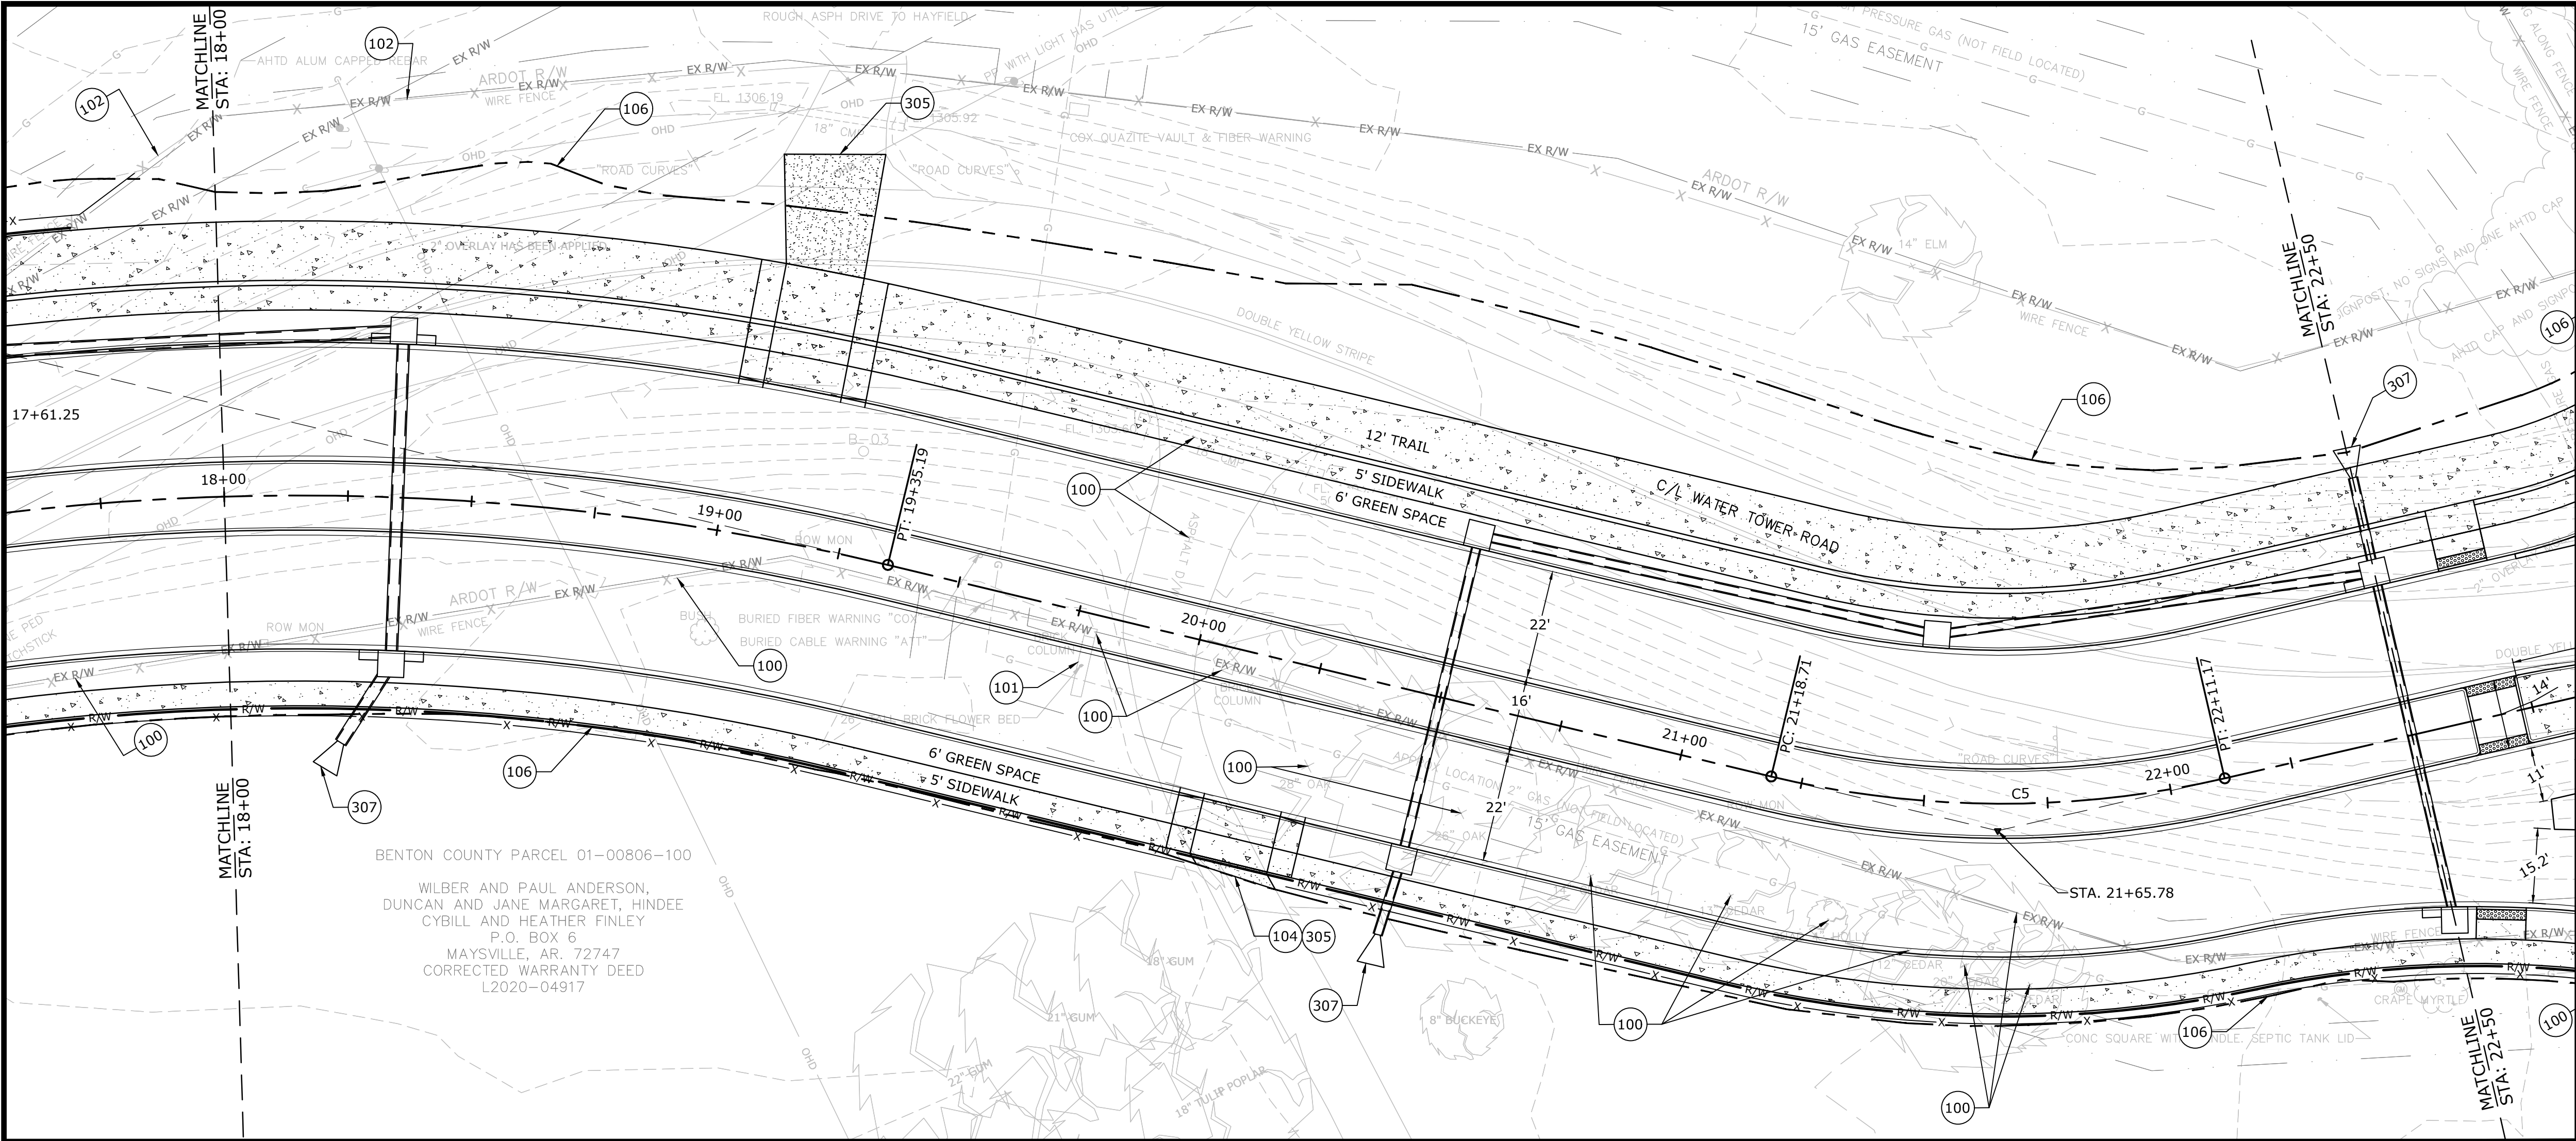

PROPOSED LEGEND

- CURB AND GUTTER
- CONCRETE PAVEMENT, SIDEWALK, AND TRAIL
- ASPHALT PAVEMENT
- GRAVEL DRIVEWAY
- STORM DRAIN STRUCTURE
- FLARED END SECTION
- STORM DRAIN
- CENTERLINE
- CATCHLINE / LIMIT OF GRADING
- BARBED WIRE FENCE
- RIGHT OF WAY
- UTILITY EASEMENT


EXISTING LEGEND

- SS: SANITARY SEWER LINE
- WA: WATER LINE
- GAS: GAS LINE
- UGT: UNDERGROUND TELEPHONE
- UGE: UNDERGROUND ELECTRIC
- UGTV: UNDERGROUND TELEVISION
- UFO: UNDERGROUND FIBER
- OHE: OVERHEAD ELECTRIC
- SD: STORM DRAINAGE PIPE
- FENCE: FENCE
- ROAD CL: ROAD CENTERLINE
- DITCH FL: DITCH FLOWLINE
- EASEMENT: EASEMENT LINE
- GRAVEL: GRAVEL LINE
- PHASE 1 CL: PHASE 1 CENTERLINE
- FH: FIRE HYDRANT
- WM: WATER METER
- WV: WATER VALVE
- WF: WATER FAUCET
- SSMH: SANITARY SEWER MH
- CO: CLEAN-OUT
- DMH: DRAINAGE MH
- PP: POWER POLE
- GUY: GUY WIRE w/ ANCHOR
- GR: GAS RISER
- SLP: STREET LIGHT POLE
- TP: TELEPHONE PEDESTAL
- CTV: CABLE TV PEDESTAL
- SN: SIGN (AS NOTED)
- POST: POST (AS NOTED)
- BENCH: BENCHMARK
- FIP: FOUND IRON PIN (AS NOTED)
- CP: CONTROL POINT
- RRS: RR SPIKE
- BUSH: BUSH
- TREE: TREE

KEYNOTES

- 100 EXISTING TO BE REMOVED AND / OR DEMOLISHED
- 101 EXISTING TO BE SALVAGED AND RETURNED TO THE OWNER
- 102 EXISTING TO REMAIN
- 103 EXISTING TO BE RELOCATED
- 104 LIMITS OF SAWCUT AND PAVEMENT REMOVAL
- 106 LIMITS OF DISTURBANCE
- 150 UTILITY LINE TO BE RELOCATED
- 151 UTILITY FACILITY TO BE RELOCATED
- 152 UTILITY POLE TO BE RELOCATED
- 305 MATCH EXISTING ELEVATION
- 307 FLARED END SECTION (TO MATCH PIPE MATERIAL)

ALIGNMENT CURVE TABLE				
CURVE #	RADIUS	CL	TL	DELTA
C1	333.00'	142.07'	72.13'	24°26'41"
C2	510.00'	43.06'	21.54'	4°50'16"
C3	200.00'	87.17'	44.29'	24°58'24"
C4	510.00'	364.19'	190.25'	40°54'53"
C5	200.00'	92.45'	47.07'	26°29'09"
C6	1797.97'	288.61'	144.61'	9°11'49"
C7	1485.00'	229.16'	114.81'	8°50'30"
C8	205.50'	144.87'	75.59'	40°23'25"
C9	205.50'	49.66'	24.95'	13°50'44"

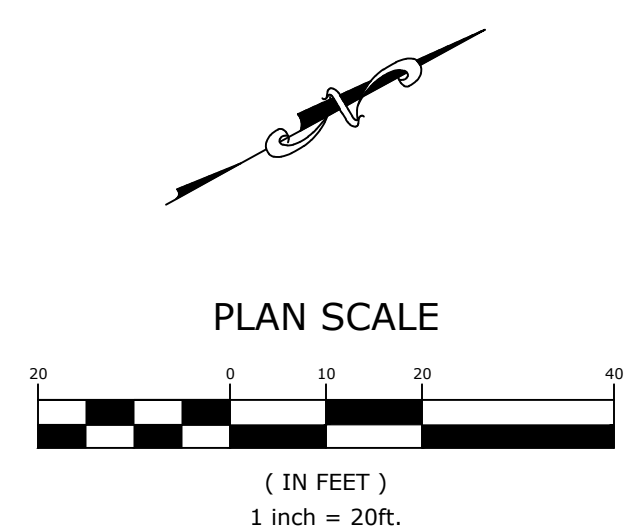

MCE McClelland Consulting, Inc.
DESIGNED TO SERVE ENGINEERS, INC.
1580 E. STEARNS ST.
FAYETTEVILLE, ARKANSAS 72703
(479) 443-2377
HTTP://WWW.MCE.US.COM

PRELIMINARY
NOT FOR
CONSTRUCTION

ORIGINAL SIGNATURE ON FILE

WATER TOWER RD. PH.3
SE. 6TH ST. TO BATTLEFIELD BLVD
BENTONVILLE, AR

BENTONVILLE
ENGINEERING

811
Know what's below.
Call before you dig.



REVISIONS		DESCRIPTION	
REV	DATE	DESCRIPTION	

PLAN AND PROFILE
WATER TOWER
RD.- STA.
18+00 TO STA.
22+50

DESIGNED BY: ELA	DRAWN BY: WAS
DATE: 1/31/2022	REVISION: 30%
SCALE: 1" = 20'	JOB NUMBER: 21-2147

PP-5

W:\2021\21-2147 - Water Tower Road Phase III. 8th St. To E. Battlefield Blvd\Design Drawings\Sheets\21-2147- Plan & Profile.dwg, PRINTED ON: February 2, 2022 @ 2:56 PM

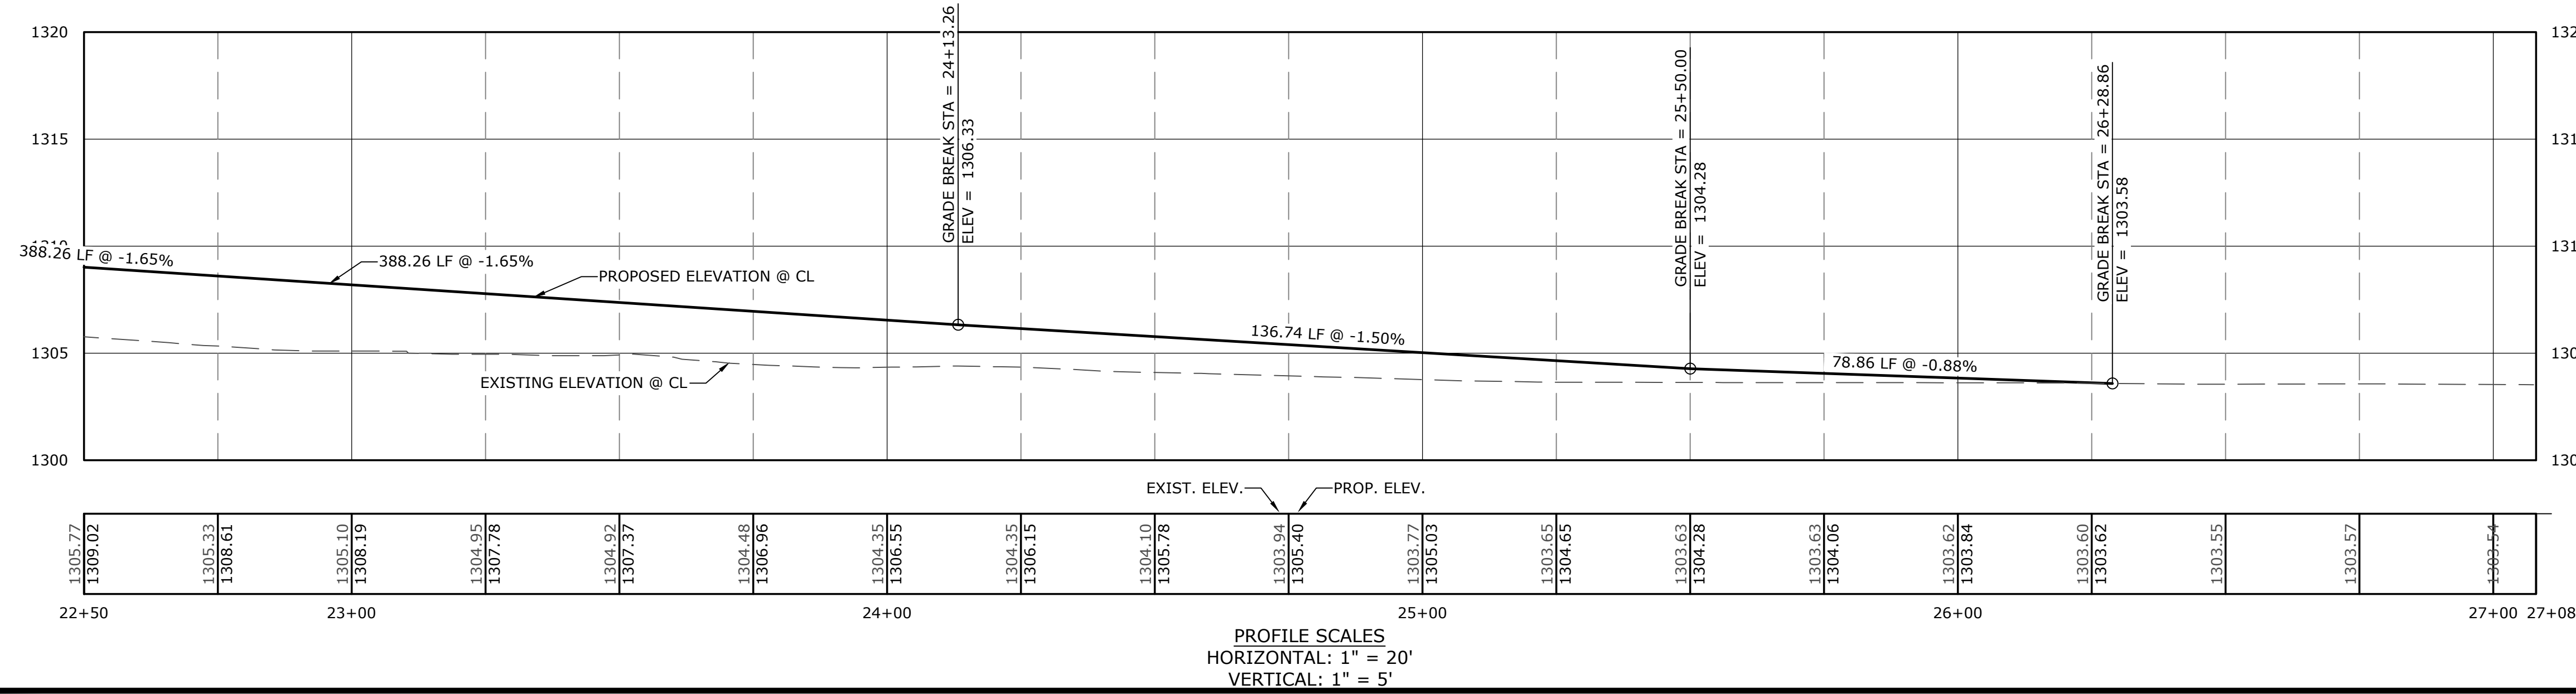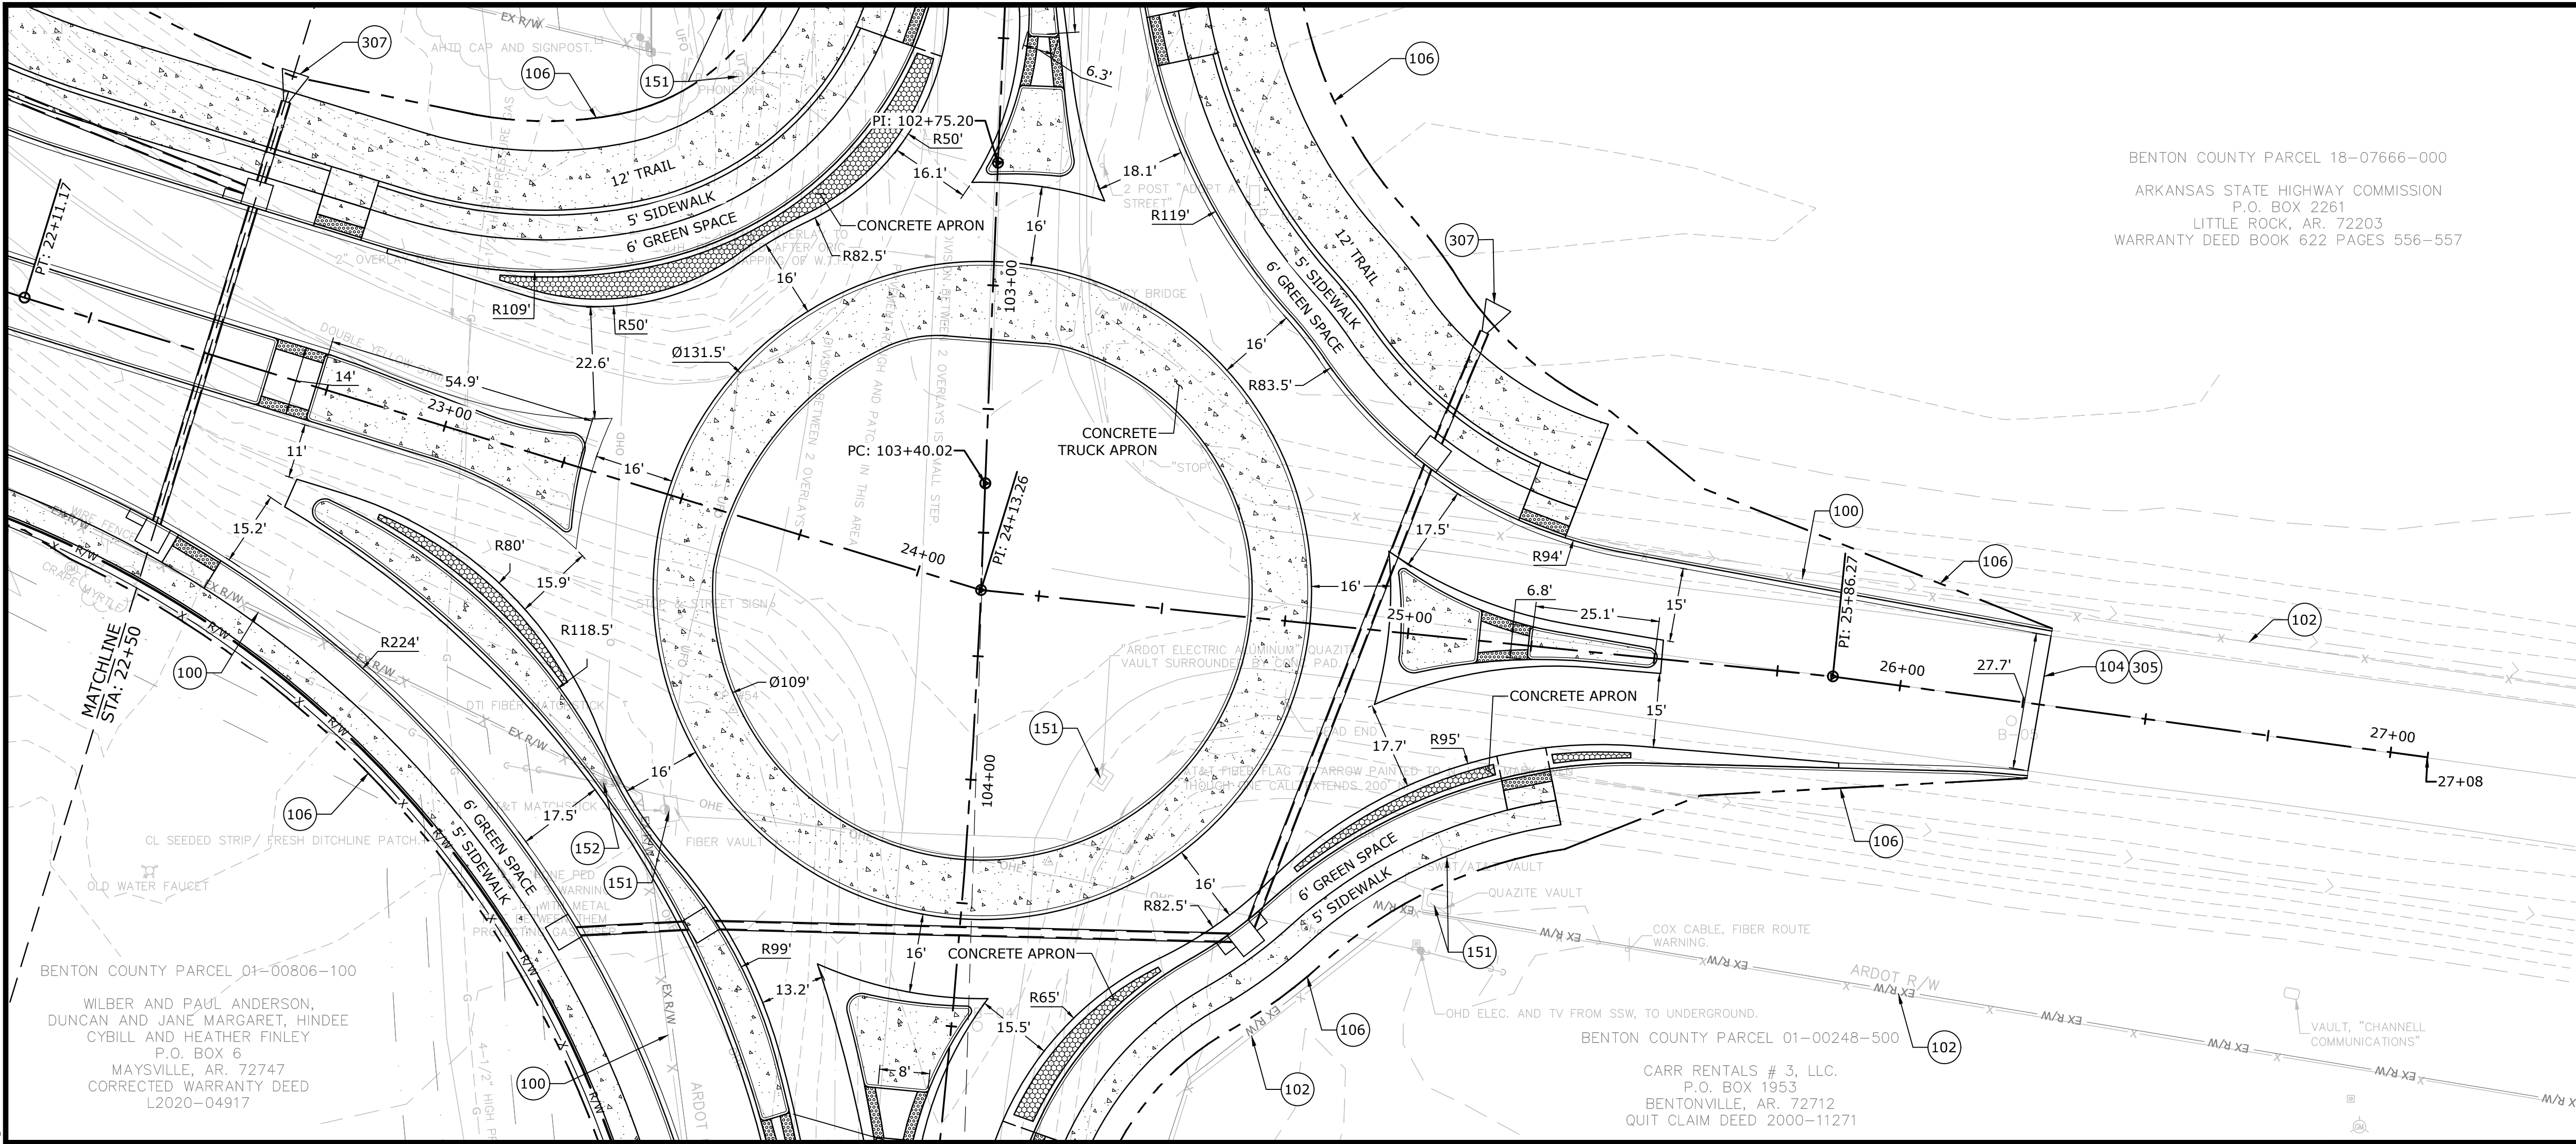


- PROPOSED LEGEND**
- CURB AND GUTTER
 - CONCRETE PAVEMENT, SIDEWALK, AND TRAIL
 - ASPHALT PAVEMENT
 - GRAVEL DRIVEWAY
 - STORM DRAIN STRUCTURE
 - FLARED END SECTION
 - STORM DRAIN
 - CENTERLINE
 - CATCHLINE / LIMIT OF GRADING
 - BARBED WIRE FENCE
 - RIGHT OF WAY
 - UTILITY EASEMENT

- EXISTING LEGEND**
- SS- SANITARY SEWER LINE
 - WA- WATER LINE
 - GAS- GAS LINE
 - UGT- UNDERGROUND TELEPHONE
 - UGE- UNDERGROUND ELECTRIC
 - UGTV- UNDERGROUND TELEVISION
 - UFO- UNDERGROUND FIBER
 - OHE- OVERHEAD ELECTRIC
 - SD- STORM DRAINAGE PIPE
 - F- FENCE
 - RC- ROAD CENTERLINE
 - DF- DITCH FLOWLINE
 - E- EASEMENT LINE
 - GL- GRAVEL LINE
 - PHASE 1 CENTERLINE
 - FH- FIRE HYDRANT
 - WM- WATER METER
 - WV- WATER VALVE
 - WT- WATER FAUCET
 - SMH- SANITARY SEWER MH
 - CO- CLEAN-OUT
 - DMH- DRAINAGE MH
 - PP- POWER POLE
 - GWA- GUY WIRE W/ ANCHOR
 - GR- GAS METER
 - SR- GAS RISER
 - SLP- STREET LIGHT POLE
 - TP- TELEPHONE PEDESTAL
 - CTP- CABLE TV PEDESTAL
 - SN- SIGN (AS NOTED)
 - PN- POST (AS NOTED)
 - B- BENCHMARK
 - FIP- FOUND IRON PIN (AS NOTED)
 - CP- CONTROL POINT
 - RS- RR SPIKE
 - B- BUSH
 - T- TREE

- KEYNOTES**
- 100 EXISTING TO BE REMOVED AND / OR DEMOLISHED
 - 101 EXISTING TO BE SALVAGED AND RETURNED TO THE OWNER
 - 102 EXISTING TO REMAIN
 - 103 EXISTING TO BE RELOCATED
 - 104 LIMITS OF SAWCUT AND PAVEMENT REMOVAL
 - 106 LIMITS OF DISTURBANCE
 - 150 UTILITY LINE TO BE RELOCATED
 - 151 UTILITY FACILITY TO BE RELOCATED
 - 152 UTILITY POLE TO BE RELOCATED
 - 305 MATCH EXISTING ELEVATION
 - 307 FLARED END SECTION (TO MATCH PIPE MATERIAL)

ALIGNMENT CURVE TABLE				
CURVE #	RADIUS	CL	TL	DELTA
C1	333.00'	142.07'	72.13'	24°26'41"
C2	510.00'	43.06'	21.54'	4°50'16"
C3	200.00'	87.17'	44.29'	24°58'24"
C4	510.00'	364.19'	190.25'	40°54'53"
C5	200.00'	92.45'	47.07'	26°29'09"
C6	1797.97'	288.61'	144.61'	9°11'49"
C7	1485.00'	229.16'	114.81'	8°50'30"
C8	205.50'	144.87'	75.59'	40°23'25"
C9	205.50'	49.66'	24.95'	13°50'44"

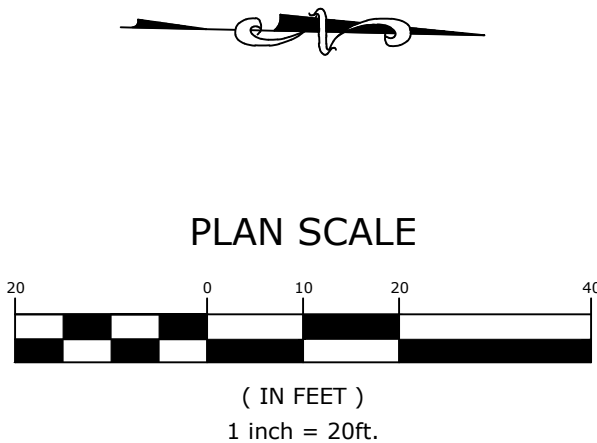

MCE McCLELLAND CONSULTING ENGINEERS, INC.
DESIGNED TO SERVE
1580 E. STEARNS ST.
FAYETTEVILLE, ARKANSAS 72703
(479) 443-2377
HTTP://WWW.MCE.US.COM

PRELIMINARY
NOT FOR
CONSTRUCTION

ORIGINAL SIGNATURE ON FILE

WATER TOWER RD. PH. 3
SE. 6TH ST. TO BATTLEFIELD BLVD.
BENTONVILLE, AR

BENTONVILLE ENGINEERING

811
Know what's below.
Call before you dig.



REVIEWS		DESCRIPTION	
REV	DATE		

PLAN AND PROFILE
WATER TOWER
RD.- STA.
22+50 TO STA.
27+08

DESIGNED BY: ELA	DRAWN BY: WAS
DATE: 2/2/2022	REVISION: 30%
SCALE: 1" = 20'	JOB NUMBER: 21-2147

PP-6

W:\2021\21-2147 - Water Tower Road Phase III: 8th St. To E. Battlefield Blvd\Design Drawings\Sheets\21-2147- Plan & Profile.dwg, PRINTED ON: January 31, 2022 @ 12:13 PM

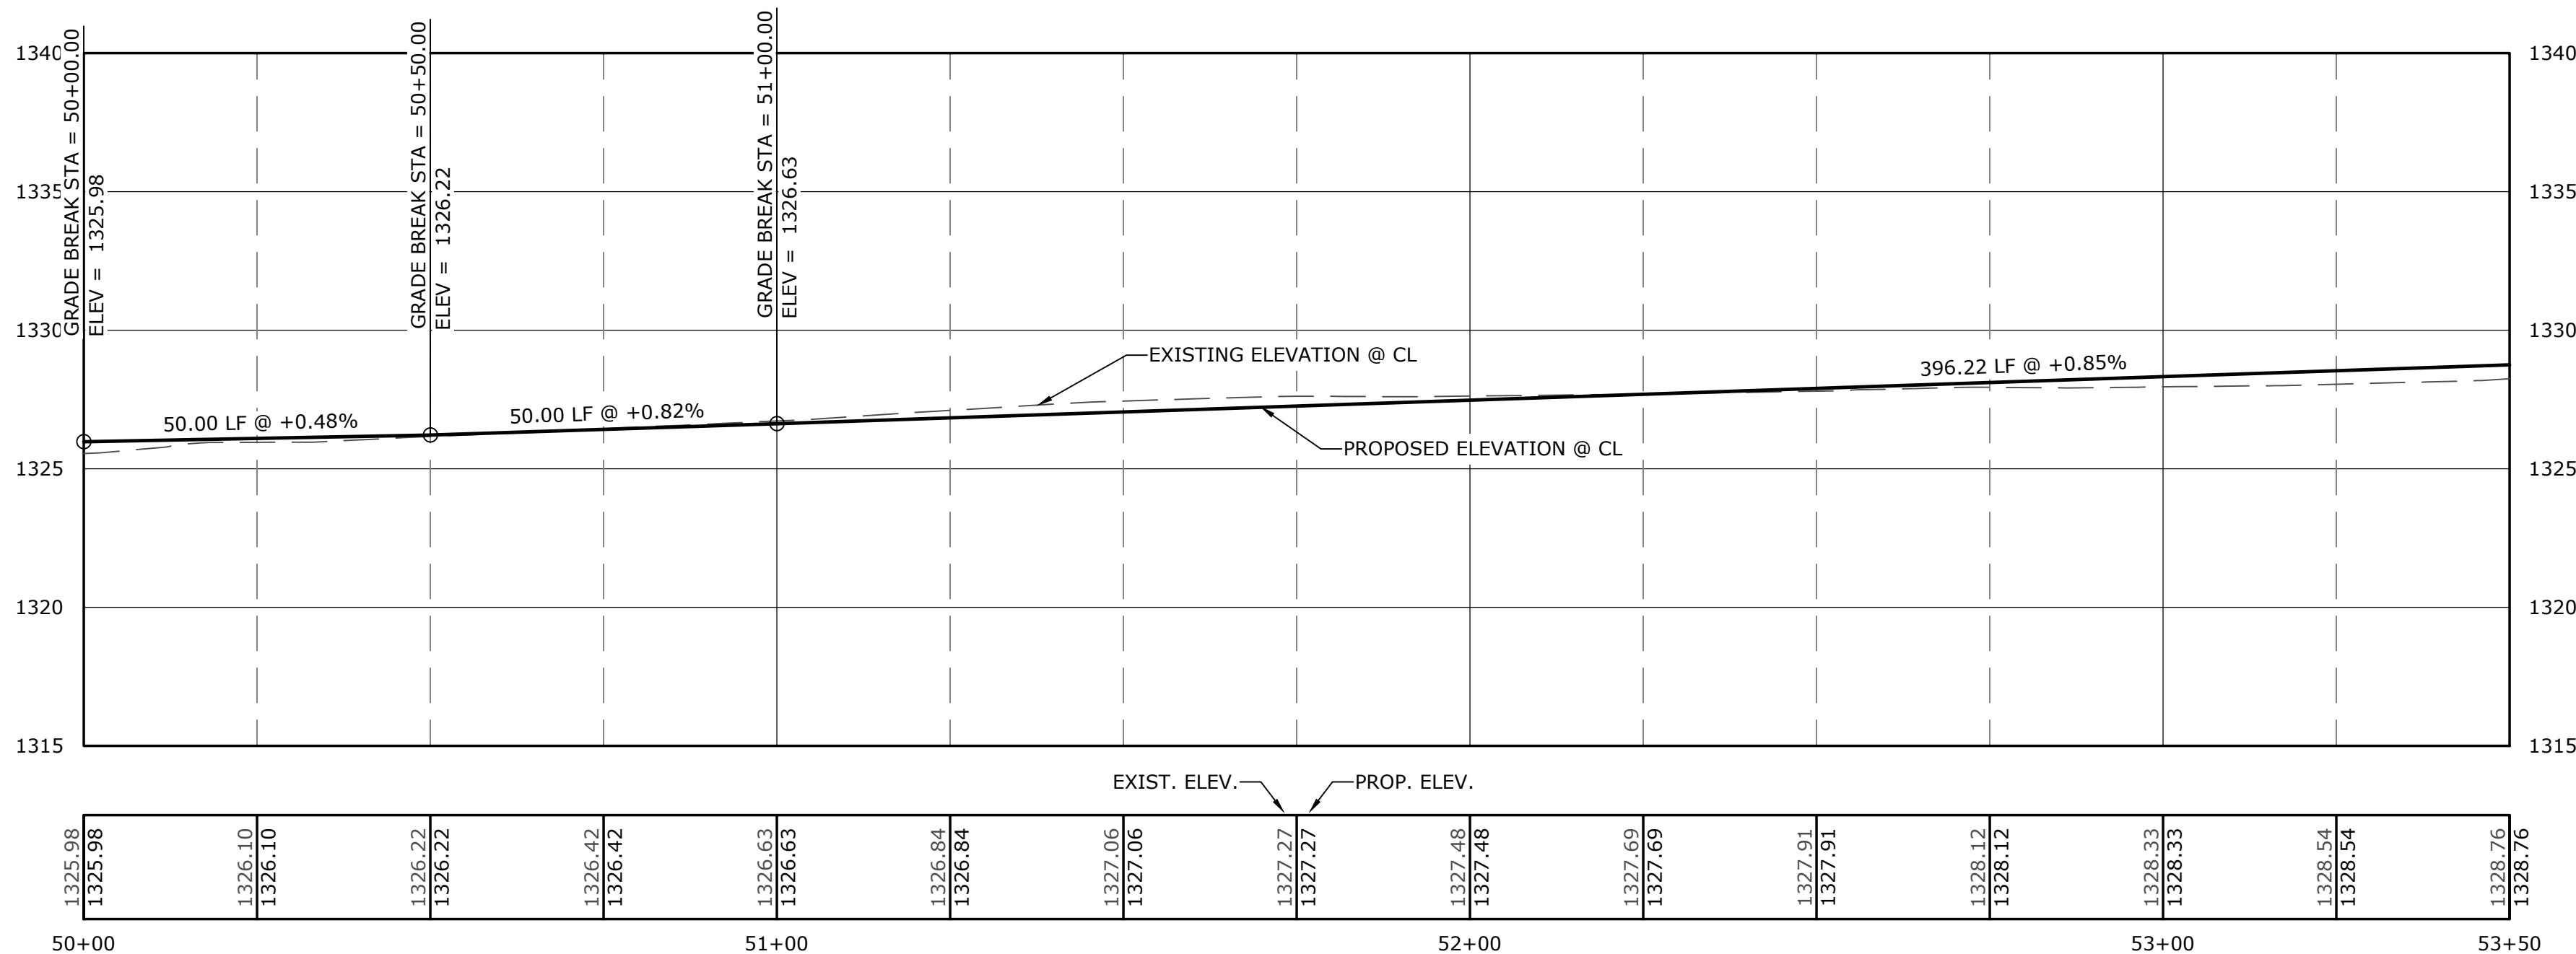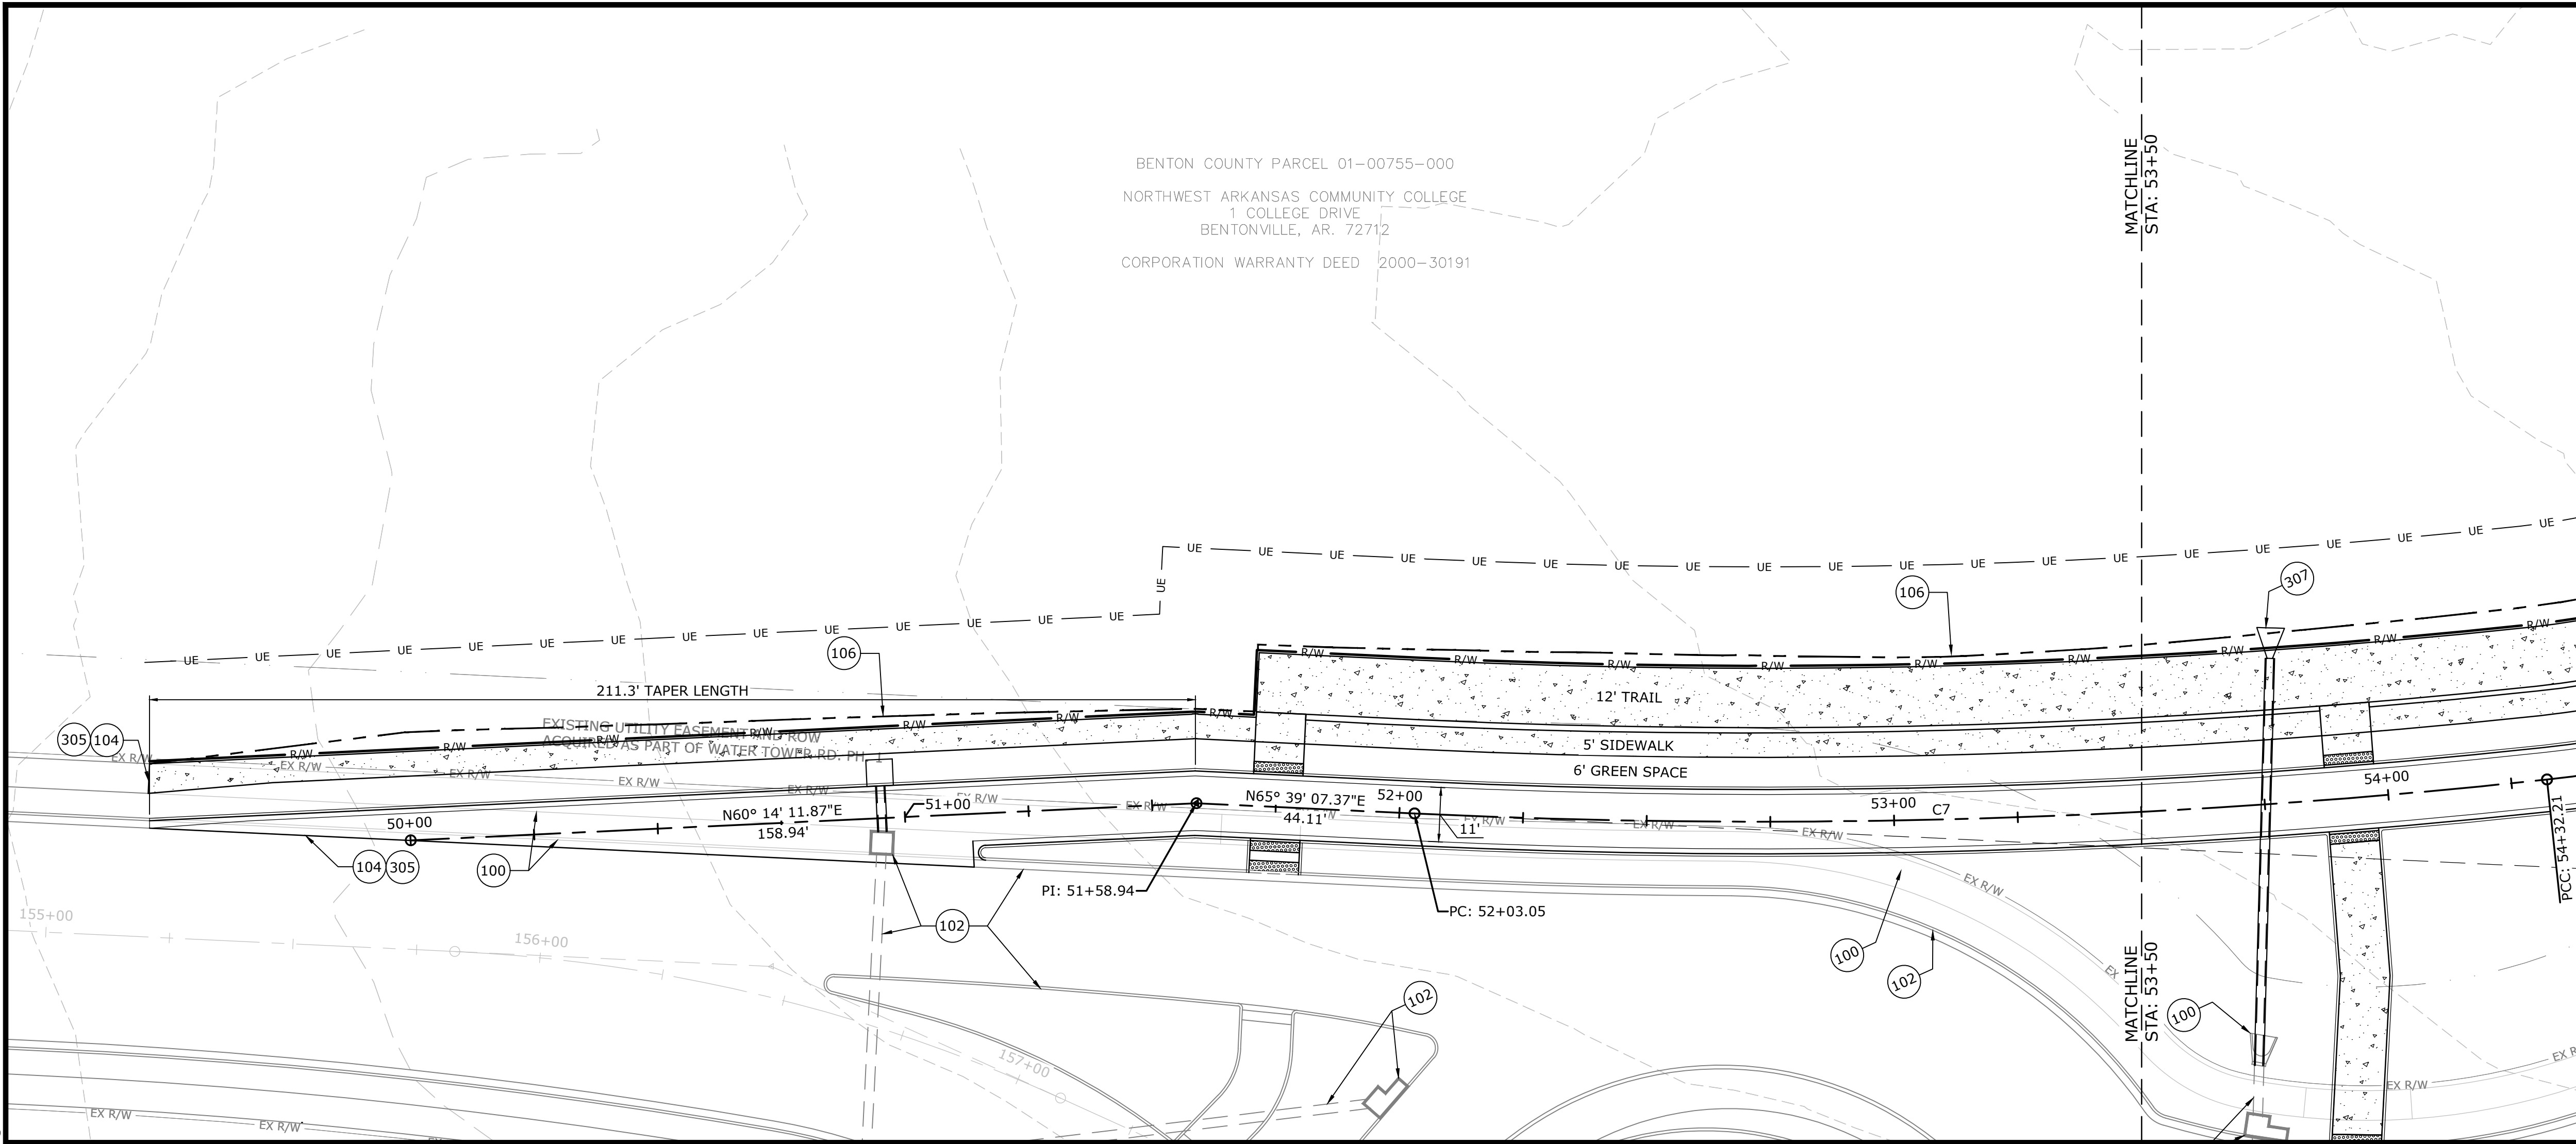

PROPOSED LEGEND

- CURB AND GUTTER
- CONCRETE PAVEMENT, SIDEWALK, AND TRAIL
- ASPHALT PAVEMENT
- GRAVEL DRIVEWAY
- STORM DRAIN STRUCTURE
- FLARED END SECTION
- STORM DRAIN
- CENTERLINE
- CATCHLINE / LIMIT OF GRADING
- BARBED WIRE FENCE
- R/W
- UE


EXISTING LEGEND

- SS SANITARY SEWER LINE
- WA WATER LINE
- GAS GAS LINE
- UGT UNDERGROUND TELEPHONE
- UGE UNDERGROUND ELECTRIC
- UGTV UNDERGROUND TELEVISION
- UFO UNDERGROUND FIBER
- OHE OVERHEAD ELECTRIC
- SD STORM DRAINAGE PIPE
- FENCE
- ROAD CENTERLINE
- DITCH FLOWLINE
- EASEMENT LINE
- GRAVEL LINE
- PHASE 1 CENTERLINE
- FIRE HYDRANT
- WATER METER
- WATER VALVE
- WATER FAUCET
- SANITARY SEWER MH
- CLEAN-OUT
- DRAINAGE MH
- POWER POLE
- GUY WIRE W/ ANCHOR
- GAS METER
- GAS RISER
- STREET LIGHT POLE
- TELEPHONE PEDESTAL
- CABLE TV PEDESTAL
- SIGN (AS NOTED)
- POST (AS NOTED)
- BENCHMARK
- FOUND IRON PIN (AS NOTED)
- CONTROL POINT
- RR SPIKE
- BUSH
- TREE

KEYNOTES

- 100 EXISTING TO BE REMOVED AND / OR DEMOLISHED
- 101 EXISTING TO BE SALVAGED AND RETURNED TO THE OWNER
- 102 EXISTING TO REMAIN
- 103 EXISTING TO BE RELOCATED
- 104 LIMITS OF SAWCUT AND PAVEMENT REMOVAL
- 106 LIMITS OF DISTURBANCE
- 150 UTILITY LINE TO BE RELOCATED
- 151 UTILITY FACILITY TO BE RELOCATED
- 152 UTILITY POLE TO BE RELOCATED
- 305 MATCH EXISTING ELEVATION
- 307 FLARED END SECTION (TO MATCH PIPE MATERIAL)

ALIGNMENT CURVE TABLE				
CURVE #	RADIUS	CL	TL	DELTA
C1	333.00'	142.07'	72.13'	24°26'41"
C2	510.00'	43.06'	21.54'	4°50'16"
C3	200.00'	87.17'	44.29'	24°58'24"
C4	510.00'	364.19'	190.25'	40°54'53"
C5	200.00'	92.45'	47.07'	26°29'09"
C6	1797.97'	288.61'	144.61'	9°11'49"
C7	1485.00'	229.16'	114.81'	8°50'30"
C8	205.50'	144.87'	75.59'	40°23'25"
C9	205.50'	49.66'	24.95'	13°50'44"

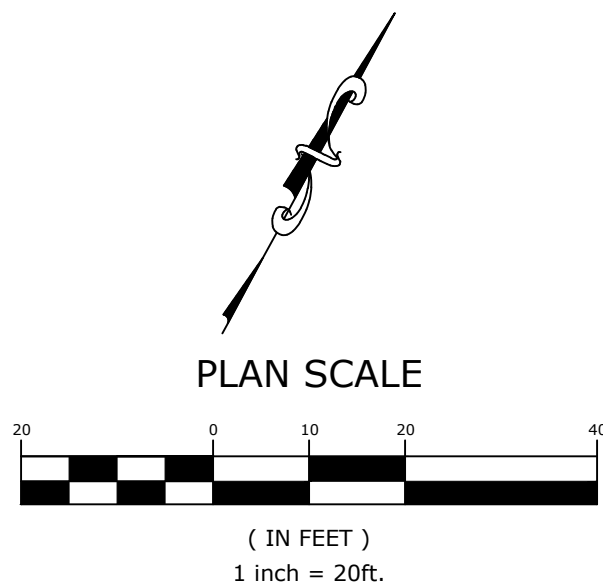

PRELIMINARY
NOT FOR
CONSTRUCTION

ORIGINAL SIGNATURE ON FILE

WATER TOWER RD. PH. 3
SE. 6TH ST. TO BATTLEFIELD BLVD.
BENTONVILLE, AR





REVIEWS		DESCRIPTION	
REV	DATE	REV	DATE

PLAN AND
PROFILE SE.
8TH ST.
CONNECT.-
STA. 50+00
TO STA. 53+50

DESIGNED BY: ELA	DRAWN BY : WAS
DATE: 1/31/2022	REVISION: 30%
SCALE: 1" = 20'	JOB NUMBER: 21-2147

W:\2021\21-2147 - Water Tower Road Phase III: 8th St. To E. Battlefield Blvd\Design Drawings\Sheets\21-2147- Plan & Profile.dwg, PRINTED ON: January 31, 2022 @ 12:13 PM

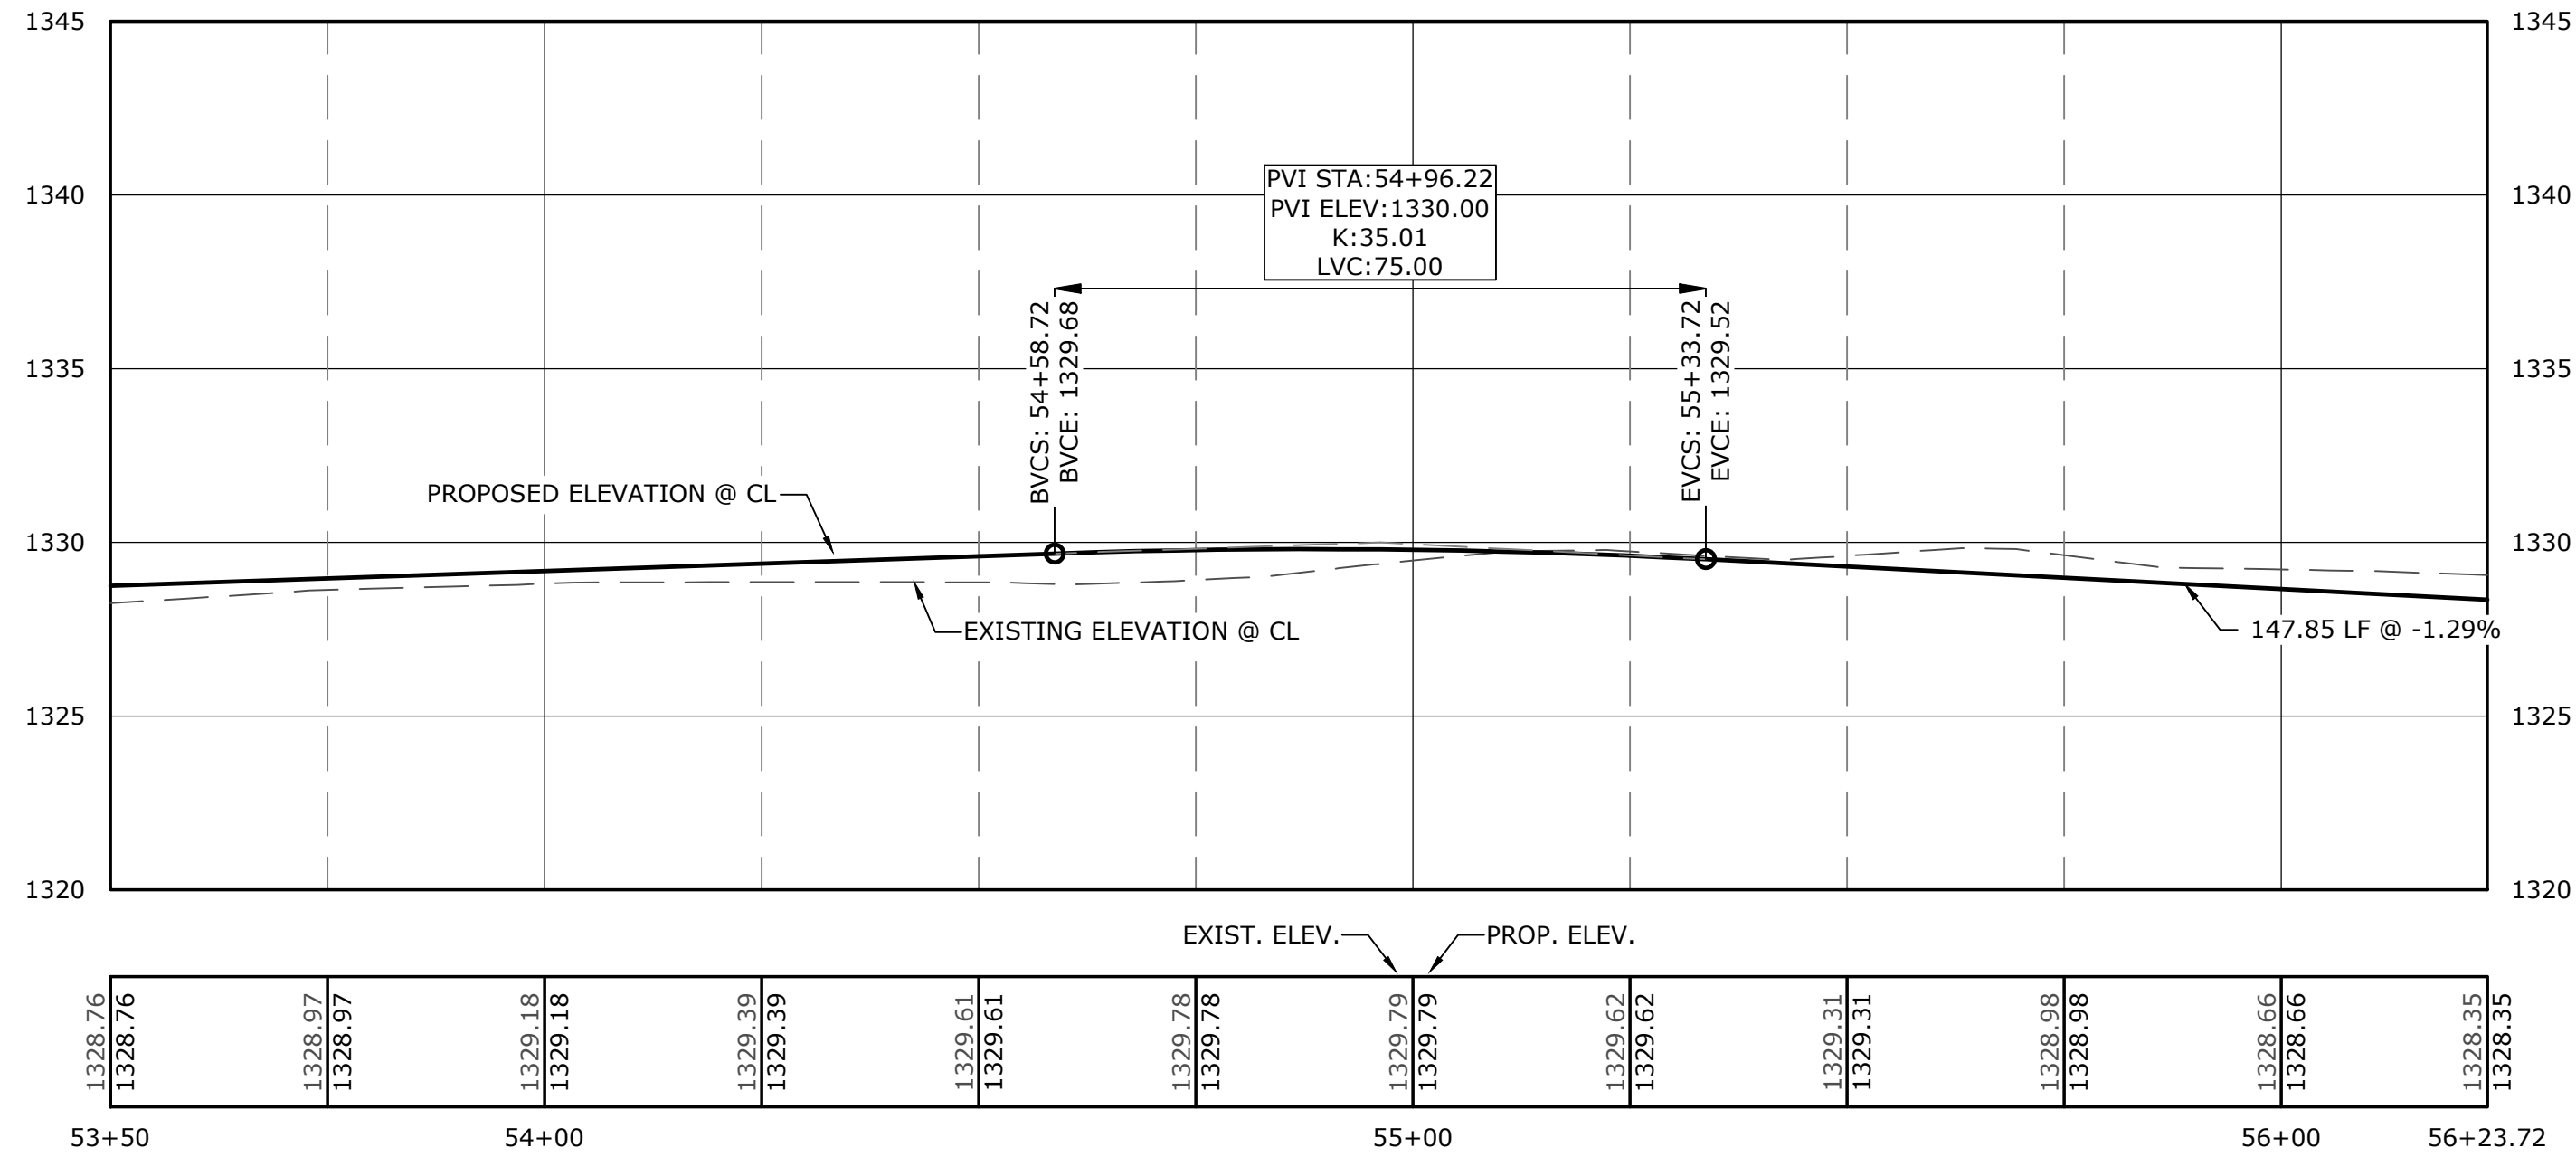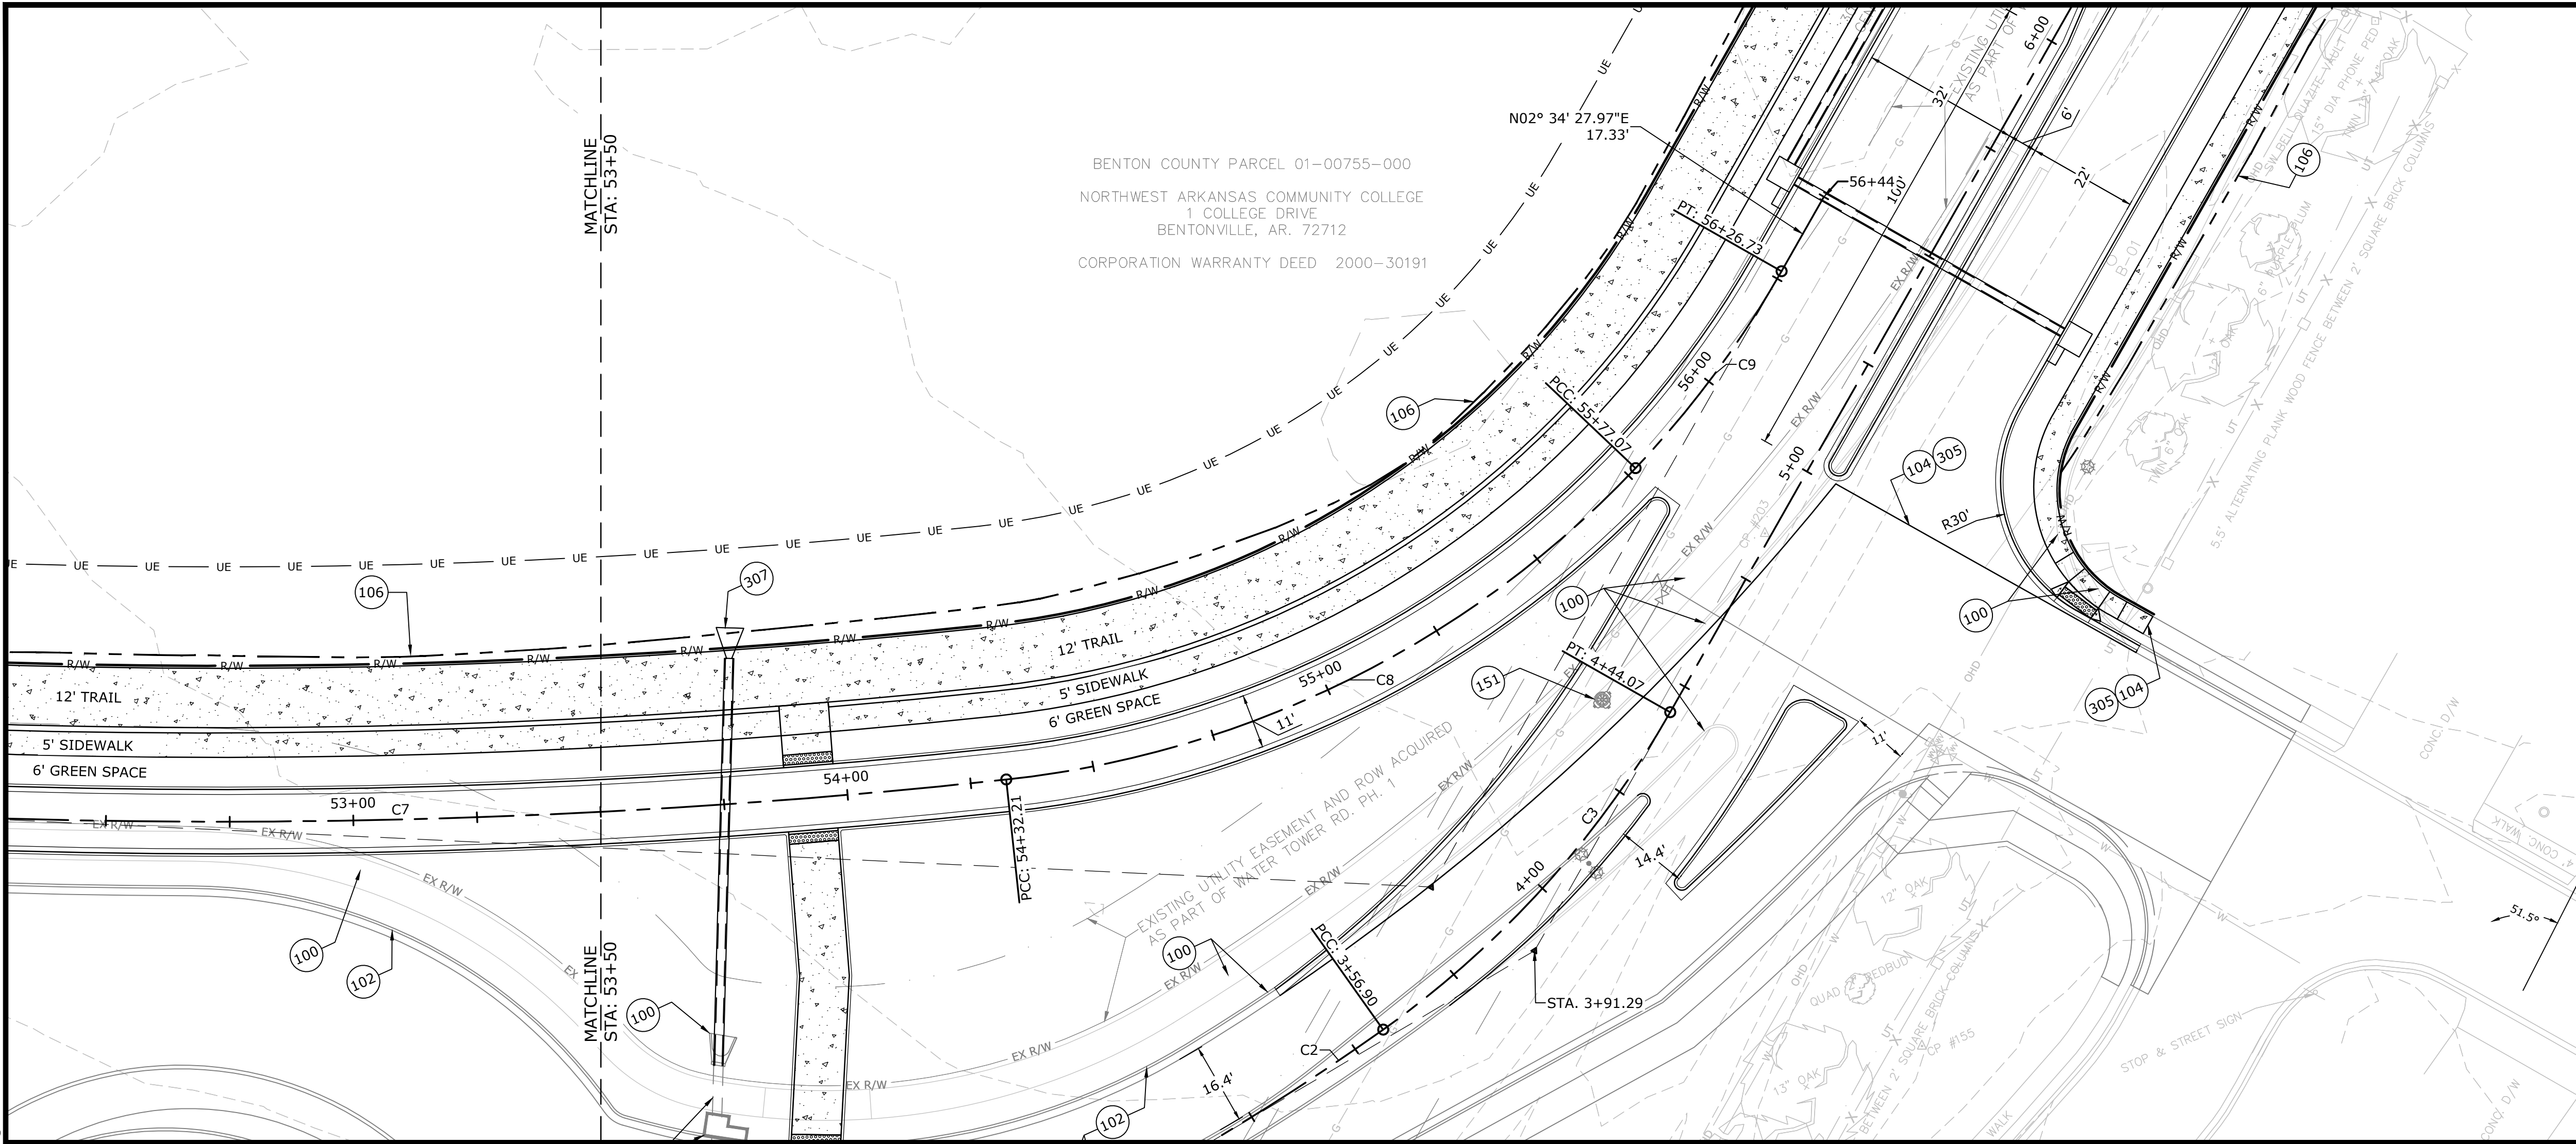

PROPOSED LEGEND


- CURB AND GUTTER
- CONCRETE PAVEMENT, SIDEWALK, AND TRAIL
- ASPHALT PAVEMENT
- GRAVEL DRIVEWAY
- STORM DRAIN STRUCTURE
- FLARED END SECTION
- STORM DRAIN
- CENTERLINE
- CATCHLINE / LIMIT OF GRADING
- BARBED WIRE FENCE
- RIGHT OF WAY
- UTILITY EASEMENT

EXISTING LEGEND


- SS: SANITARY SEWER LINE
- WA: WATER LINE
- GAS: GAS LINE
- UGT: UNDERGROUND TELEPHONE
- UGE: UNDERGROUND ELECTRIC
- UGTV: UNDERGROUND TELEVISION
- UFO: UNDERGROUND FIBER
- OHE: OVERHEAD ELECTRIC
- SD: STORM DRAINAGE PIPE
- FENCE
- ROAD CENTERLINE
- DITCH FLOWLINE
- EASEMENT LINE
- GRAVEL LINE
- PHASE 1 CENTERLINE
- FIRE HYDRANT
- WATER METER
- WATER VALVE
- WATER FAUCET
- SANITARY SEWER MH
- CLEAN-OUT
- DRAINAGE MH
- POWER POLE
- GUY WIRE W/ ANCHOR
- GAS METER
- GAS RISER
- STREET LIGHT POLE
- TELEPHONE PEDESTAL
- CABLE TV PEDESTAL
- SIGN (AS NOTED)
- POST (AS NOTED)
- BENCHMARK
- FOUND IRON PIN (AS NOTED)
- CONTROL POINT
- RR SPIKE
- BUSH
- TREE

KEYNOTES

- 100 EXISTING TO BE REMOVED AND / OR DEMOLISHED
- 101 EXISTING TO BE SALVAGED AND RETURNED TO THE OWNER
- 102 EXISTING TO REMAIN
- 103 EXISTING TO BE RELOCATED
- 104 LIMITS OF SAWCUT AND PAVEMENT REMOVAL
- 106 LIMITS OF DISTURBANCE
- 150 UTILITY LINE TO BE RELOCATED
- 151 UTILITY FACILITY TO BE RELOCATED
- 152 UTILITY POLE TO BE RELOCATED
- 305 MATCH EXISTING ELEVATION
- 307 FLARED END SECTION (TO MATCH PIPE MATERIAL)

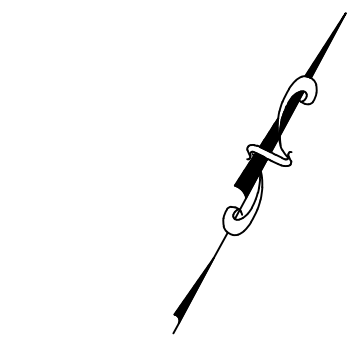

PLAN SCALE


 


(IN FEET)
1 inch = 20ft.

ALIGNMENT CURVE TABLE				
CURVE #	RADIUS	CL	TL	DELTA
C1	333.00'	142.07'	72.13'	24°26'41"
C2	510.00'	43.06'	21.54'	4°50'16"
C3	200.00'	87.17'	44.29'	24°58'24"
C4	510.00'	364.19'	190.25'	40°54'53"
C5	200.00'	92.45'	47.07'	26°29'09"
C6	1797.97'	288.61'	144.61'	9°11'49"
C7	1485.00'	229.16'	114.81'	8°50'30"
C8	205.50'	144.87'	75.59'	40°23'25"
C9	205.50'	49.66'	24.95'	13°50'44"

REVISIONS		DESCRIPTION	
REV	DATE	DESCRIPTION	

W:\2021\21-2147 - Water Tower Road Phase III. 8th St. To E. Battlfield Blvd\Design Drawings\Sheets\21-2147- Plan & Profile.dwg, PRINTED ON: January 31, 2022 @ 3:03 PM

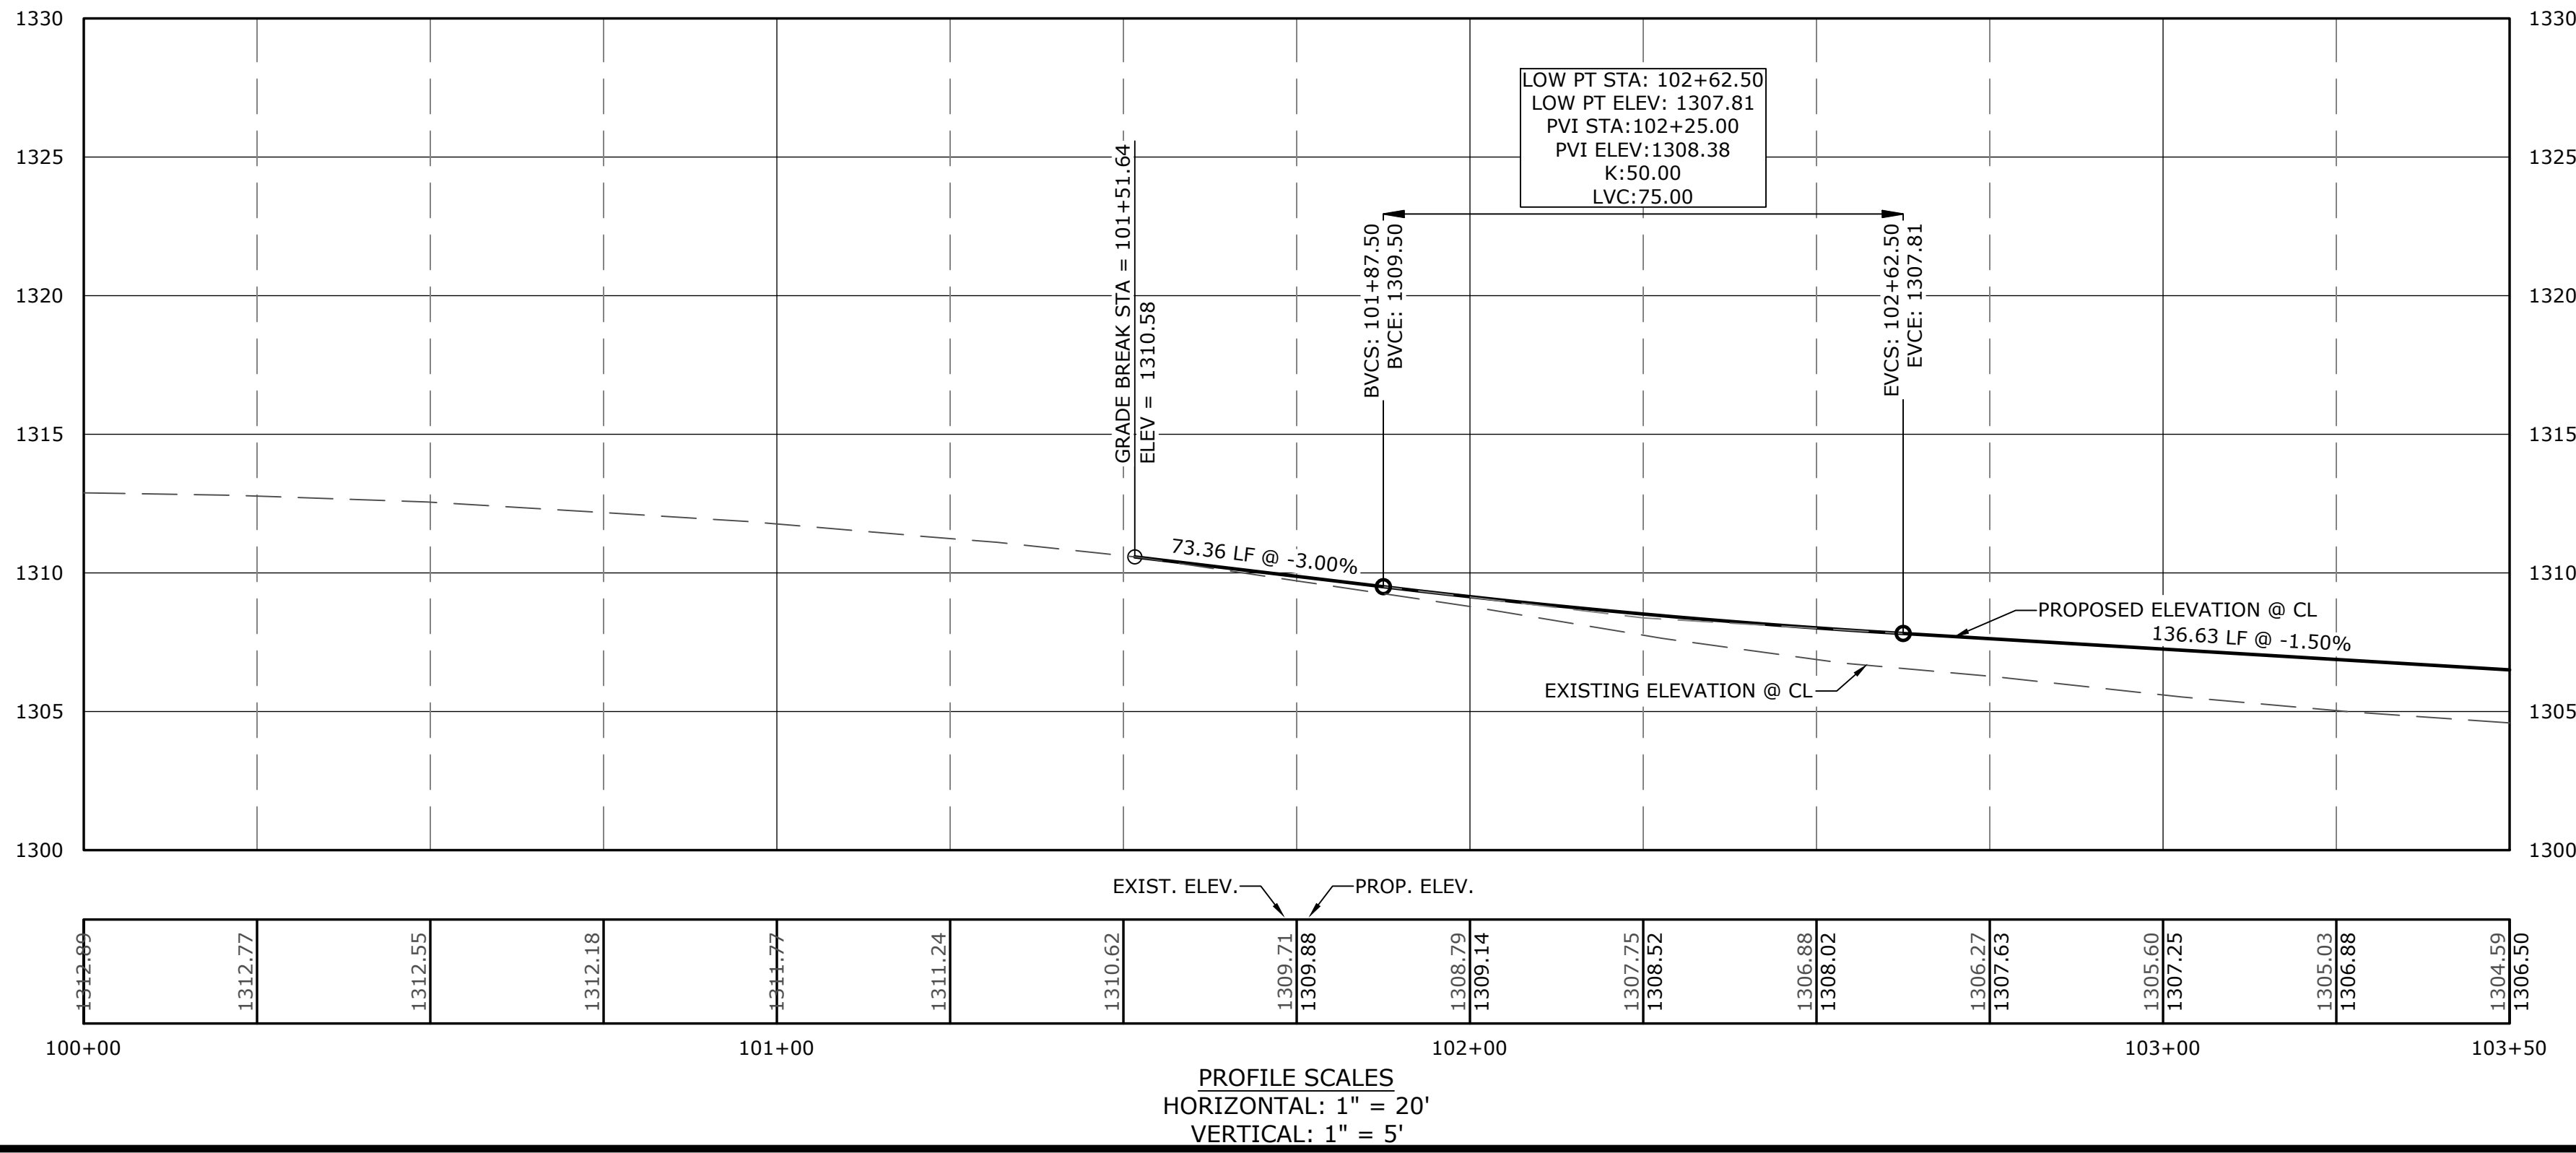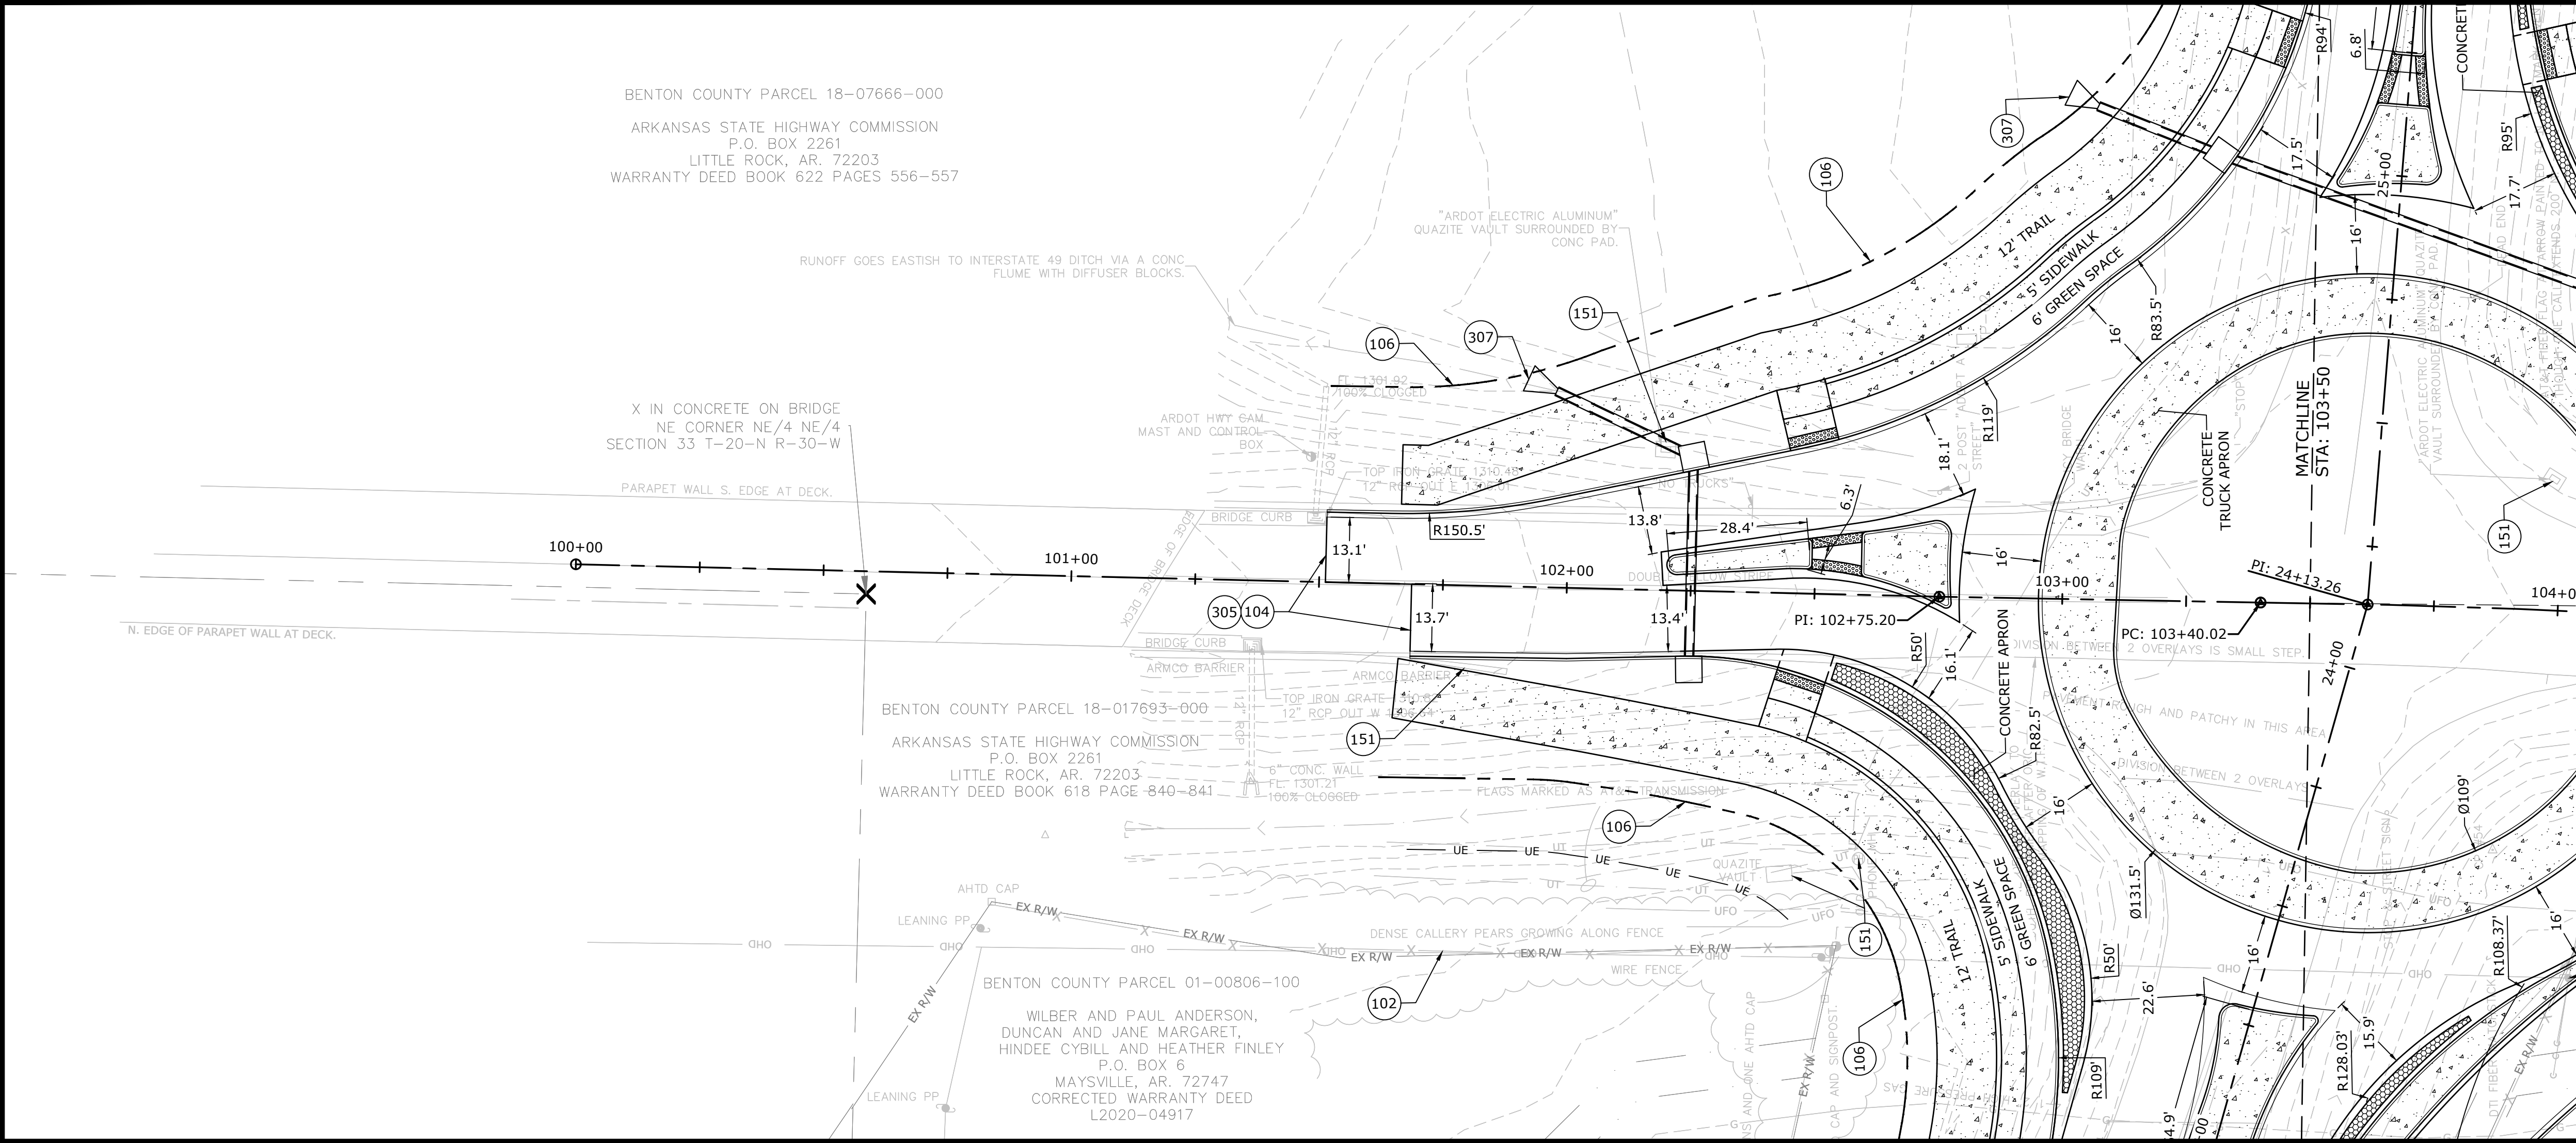

PROPOSED LEGEND

- CURB AND GUTTER
- CONCRETE PAVEMENT, SIDEWALK, AND TRAIL
- ASPHALT PAVEMENT
- GRAVEL DRIVEWAY
- STORM DRAIN STRUCTURE
- FLARED END SECTION
- STORM DRAIN
- CENTERLINE
- CATCHLINE / LIMIT OF GRADING
- BARBED WIRE FENCE
- RIGHT OF WAY
- UTILITY EASEMENT


EXISTING LEGEND

- SS- SANITARY SEWER LINE
- WA- WATER LINE
- GAS- GAS LINE
- UGT- UNDERGROUND TELEPHONE
- UGE- UNDERGROUND ELECTRIC
- UGTV- UNDERGROUND TELEVISION
- UFO- UNDERGROUND FIBER
- OHE- OVERHEAD ELECTRIC
- SD- STORM DRAINAGE PIPE
- FENCE
- ROAD CENTERLINE
- DITCH FLOWLINE
- EASEMENT LINE
- GRAVEL LINE
- PHASE 1 CENTERLINE
- FIRE HYDRANT
- WATER METER
- WATER VALVE
- WATER FAUCET
- SANITARY SEWER MH
- CLEAN-OUT
- DRAINAGE MH
- POWER POLE
- GUY WIRE W/ ANCHOR
- GAS METER
- GAS RISER
- STREET LIGHT POLE
- TELEPHONE PEDESTAL
- CABLE TV PEDESTAL
- SIGN (AS NOTED)
- POST (AS NOTED)
- BENCHMARK
- FOUND IRON PIN (AS NOTED)
- CONTROL POINT
- RR SPIKE
- BUSH
- TREE

KEYNOTES

- 100 EXISTING TO BE REMOVED AND / OR DEMOLISHED
- 101 EXISTING TO BE SALVAGED AND RETURNED TO THE OWNER
- 102 EXISTING TO REMAIN
- 103 EXISTING TO BE RELOCATED
- 104 LIMITS OF SAWCUT AND PAVEMENT REMOVAL
- 106 LIMITS OF DISTURBANCE
- 150 UTILITY LINE TO BE RELOCATED
- 151 UTILITY FACILITY TO BE RELOCATED
- 152 UTILITY POLE TO BE RELOCATED
- 305 MATCH EXISTING ELEVATION
- 307 FLARED END SECTION (TO MATCH PIPE MATERIAL)

ALIGNMENT CURVE TABLE				
CURVE #	RADIUS	CL	TL	DELTA
C1	333.00'	142.07'	72.13'	24°26'41"
C2	510.00'	43.06'	21.54'	4°50'16"
C3	200.00'	87.17'	44.29'	24°58'24"
C4	510.00'	364.19'	190.25'	40°54'53"
C5	200.00'	92.45'	47.07'	26°29'09"
C6	1797.97'	288.61'	144.61'	9°11'49"
C7	1485.00'	229.16'	114.81'	8°50'30"
C8	205.50'	144.87'	75.59'	40°23'25"
C9	205.50'	49.66'	24.95'	13°50'44"

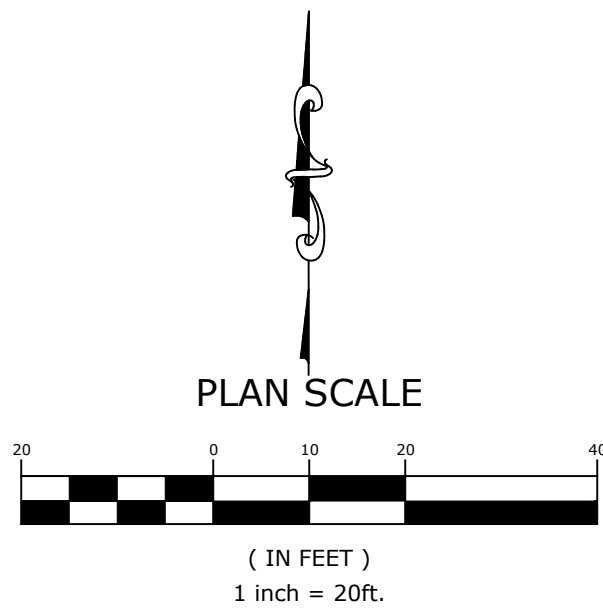

PRELIMINARY
NOT FOR
CONSTRUCTION

ORIGINAL SIGNATURE ON FILE

WATER TOWER RD. PH. 3
SE. 6TH ST. TO BATTLEFIELD BLVD.
BENTONVILLE, AR





REVIEWS		DESCRIPTION	
REV	DATE		

PLAN AND
PROFILE
BATTLEFIELD
BLVD.- STA.
100+00 TO
STA. 103+50

DESIGNED BY: ELA	DRAWN BY: WAS
DATE: 1/31/2022	REVISION: 30%
SCALE: 1" = 20'	JOB NUMBER: 21-2147

W:\2021\21-2147 - Water Tower Road Phase III. 8th St. To E. Battlefield Blvd\Design Drawings\Sheets\21-2147- Plan & Profile.dwg, PRINTED ON: February 2, 2022 @ 2:57 PM

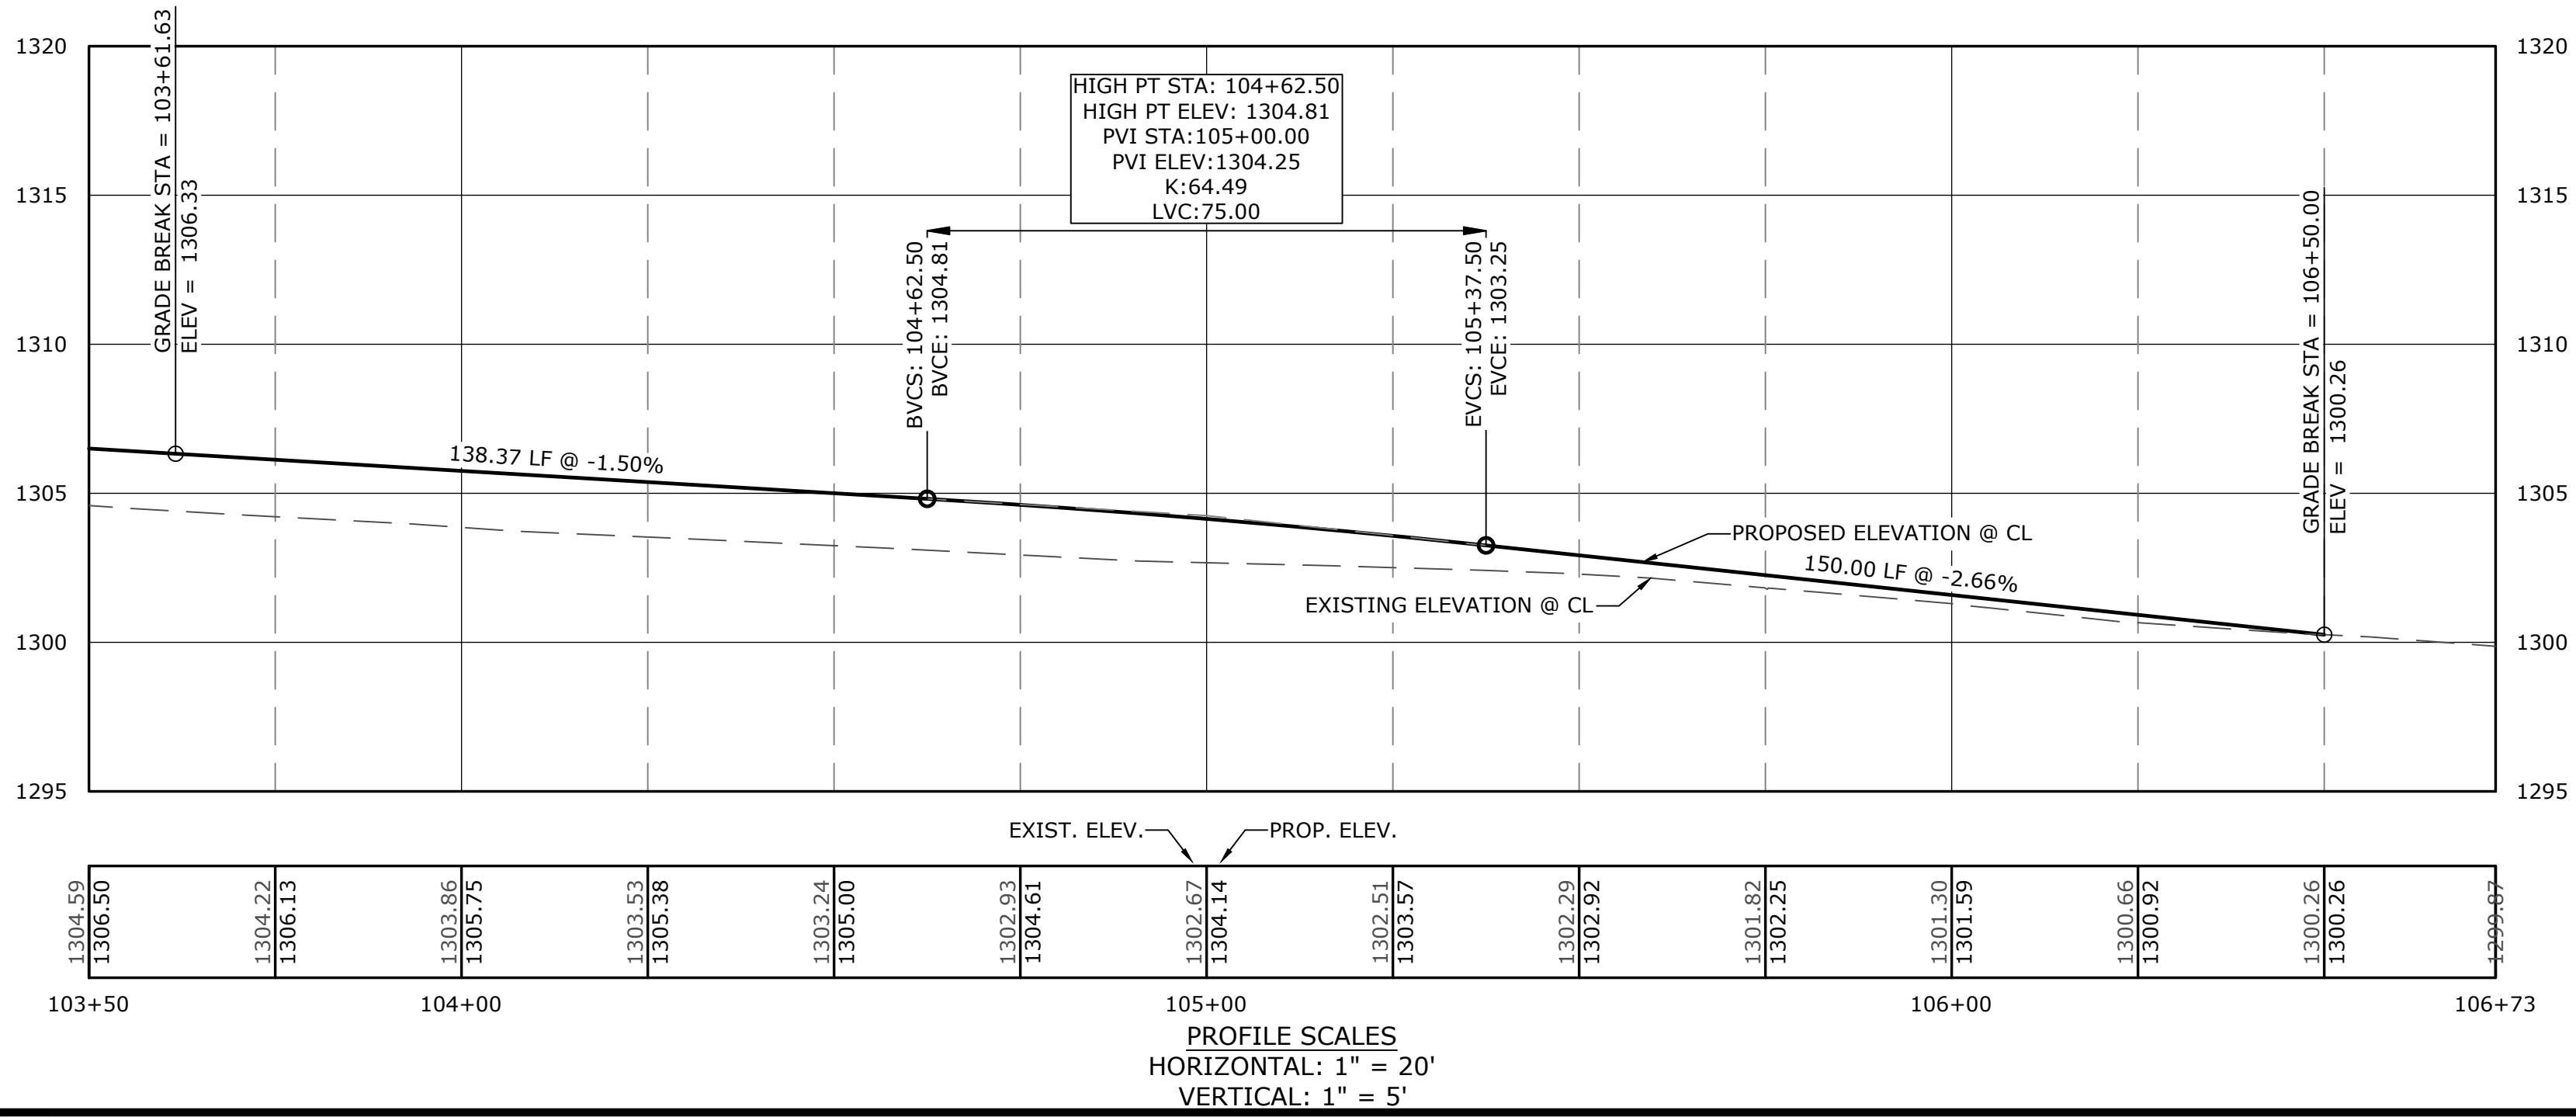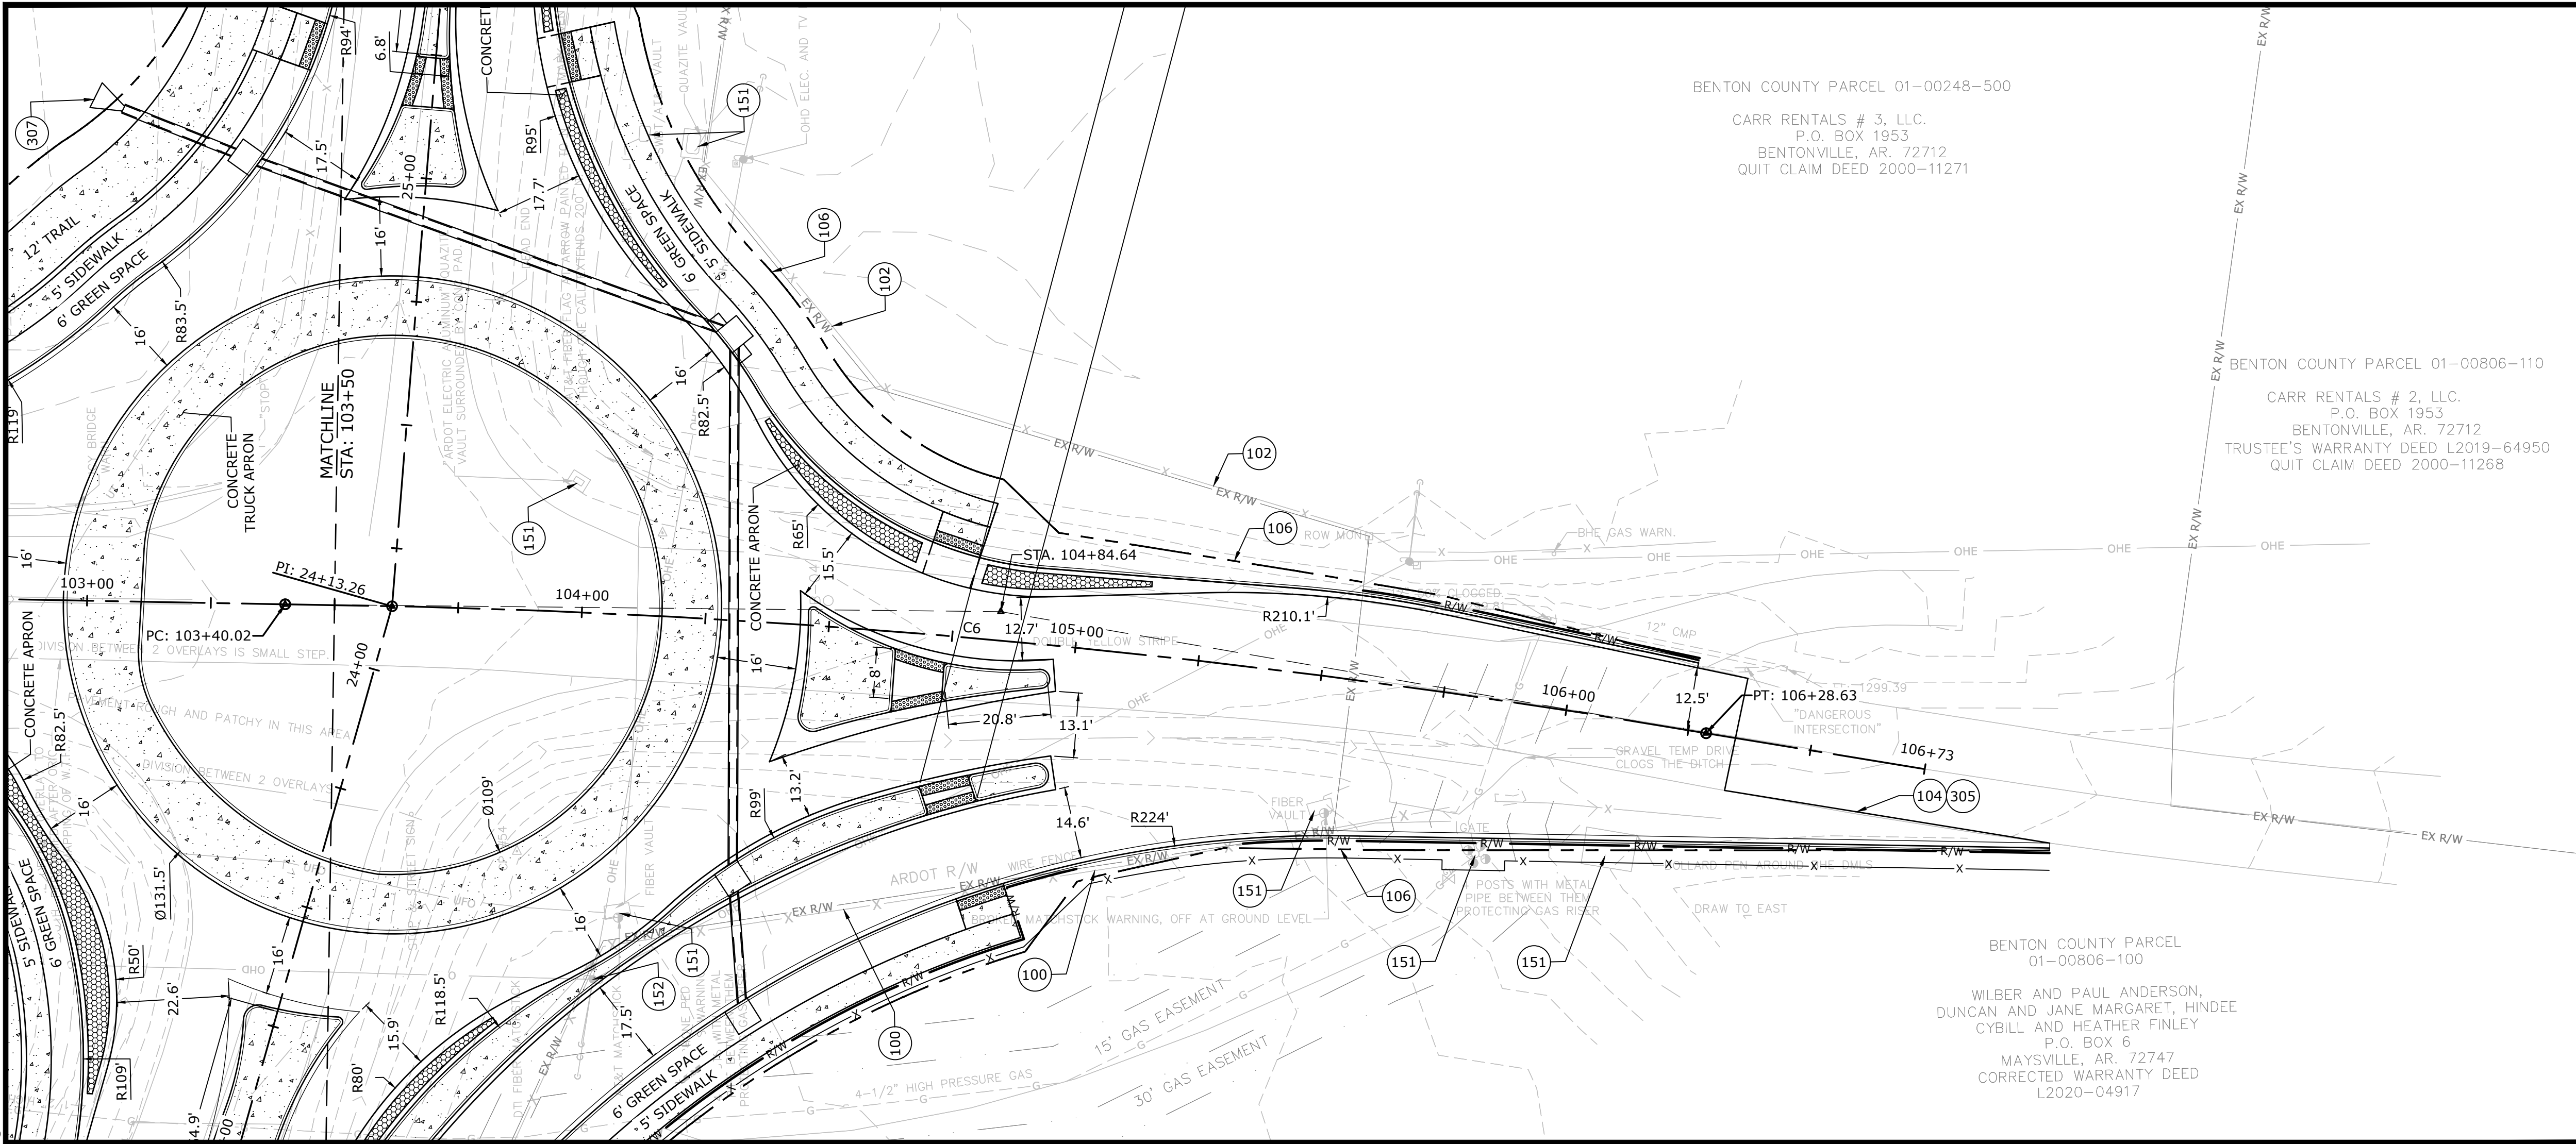


- PROPOSED LEGEND**
- CURB AND GUTTER
 - CONCRETE PAVEMENT, SIDEWALK, AND TRAIL
 - ASPHALT PAVEMENT
 - GRAVEL DRIVEWAY
 - STORM DRAIN STRUCTURE
 - FLARED END SECTION
 - STORM DRAIN
 - CENTERLINE
 - CATCHLINE / LIMIT OF GRADING
 - BARBED WIRE FENCE
 - RIGHT OF WAY
 - UTILITY EASEMENT

- EXISTING LEGEND**
- SS - SANITARY SEWER LINE
 - WA - WATER LINE
 - GAS - GAS LINE
 - UGT - UNDERGROUND TELEPHONE
 - UGE - UNDERGROUND ELECTRIC
 - UGTV - UNDERGROUND TELEVISION
 - UFO - UNDERGROUND FIBER
 - OHE - OVERHEAD ELECTRIC
 - SDP - STORM DRAINAGE PIPE
 - FENCE
 - ROAD CENTERLINE
 - DITCH FLOWLINE
 - EASEMENT LINE
 - GRAVEL LINE
 - PHASE 1 CENTERLINE
 - FIRE HYDRANT
 - WATER METER
 - WATER VALVE
 - WT - WATER FAUCET
 - SMH - SANITARY SEWER MH
 - CO - CLEAN-OUT
 - DMH - DRAINAGE MH
 - PP - POWER POLE
 - GWA - GUY WIRE W/ ANCHOR
 - GM - GAS METER
 - GR - GAS RISER
 - SLLP - STREET LIGHT POLE
 - TP - TELEPHONE PEDESTAL
 - CTP - CABLE TV PEDESTAL
 - SN - SIGN (AS NOTED)
 - PS - POST (AS NOTED)
 - B - BENCHMARK
 - FIP - FOUND IRON PIN (AS NOTED)
 - CP - CONTROL POINT
 - RS - RR SPIKE
 - B - BUSH
 - T - TREE

- KEYNOTES**
- 100 EXISTING TO BE REMOVED AND / OR DEMOLISHED
 - 101 EXISTING TO BE SALVAGED AND RETURNED TO THE OWNER
 - 102 EXISTING TO REMAIN
 - 103 EXISTING TO BE RELOCATED
 - 104 LIMITS OF SAWCUT AND PAVEMENT REMOVAL
 - 106 LIMITS OF DISTURBANCE
 - 150 UTILITY LINE TO BE RELOCATED
 - 151 UTILITY FACILITY TO BE RELOCATED
 - 152 UTILITY POLE TO BE RELOCATED
 - 305 MATCH EXISTING ELEVATION
 - 307 FLARED END SECTION (TO MATCH PIPE MATERIAL)

ALIGNMENT CURVE TABLE				
CURVE #	RADIUS	CL	TL	DELTA
C1	333.00'	142.07'	72.13'	24°26'41"
C2	510.00'	43.06'	21.54'	4°50'16"
C3	200.00'	87.17'	44.29'	24°58'24"
C4	510.00'	364.19'	190.25'	40°54'53"
C5	200.00'	92.45'	47.07'	26°29'09"
C6	1797.97'	288.61'	144.61'	9°11'49"
C7	1485.00'	229.16'	114.81'	8°50'30"
C8	205.50'	144.87'	75.59'	40°23'25"
C9	205.50'	49.66'	24.95'	13°50'44"

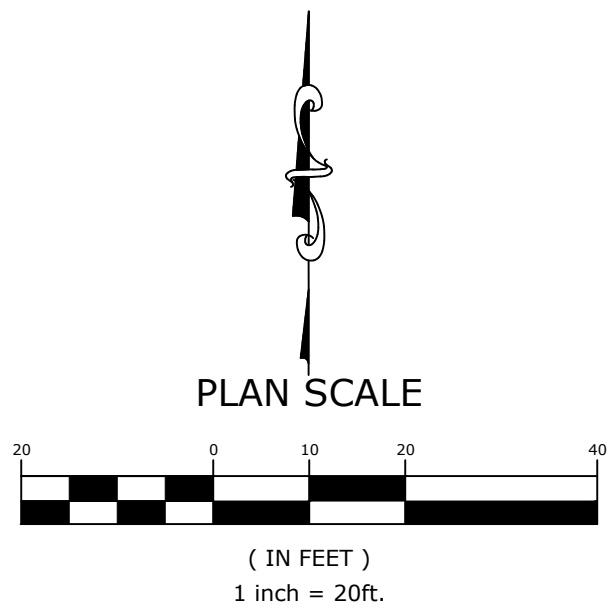

MCE McCLELLAND CONSULTING ENGINEERS, INC.
DESIGNED TO SERVE
1580 E. STEARNS ST.
FAYETTEVILLE, ARKANSAS 72703
(479) 443-2377
HTTP://WWW.MCE.US.COM

PRELIMINARY
NOT FOR
CONSTRUCTION

ORIGINAL SIGNATURE ON FILE

WATER TOWER RD. PH. 3
SE. 6TH ST. TO BATTLEFIELD BLVD.
BENTONVILLE, AR



811
Know what's below.
Call before you dig.










REVIEWS		DESCRIPTION	
REV	DATE		

**PLAN AND PROFILE
BATTLEFIELD
BLVD.- STA.
103+50 TO
STA. 106+73**

DESIGNED BY: ELA	DRAWN BY: WAS
DATE: 2/2/2022	REVISION: 30%
SCALE: 1" = 20'	JOB NUMBER: 21-2147

PP-10

W:\2021\21-2147 - Water Tower Road Phase III. 8th St. To E. Battlfield Blvd\Design Drawings\Sheets\21-2147- Cross Sections.dwg, PRINTED ON: January 31, 2022 @ 12:26 PM

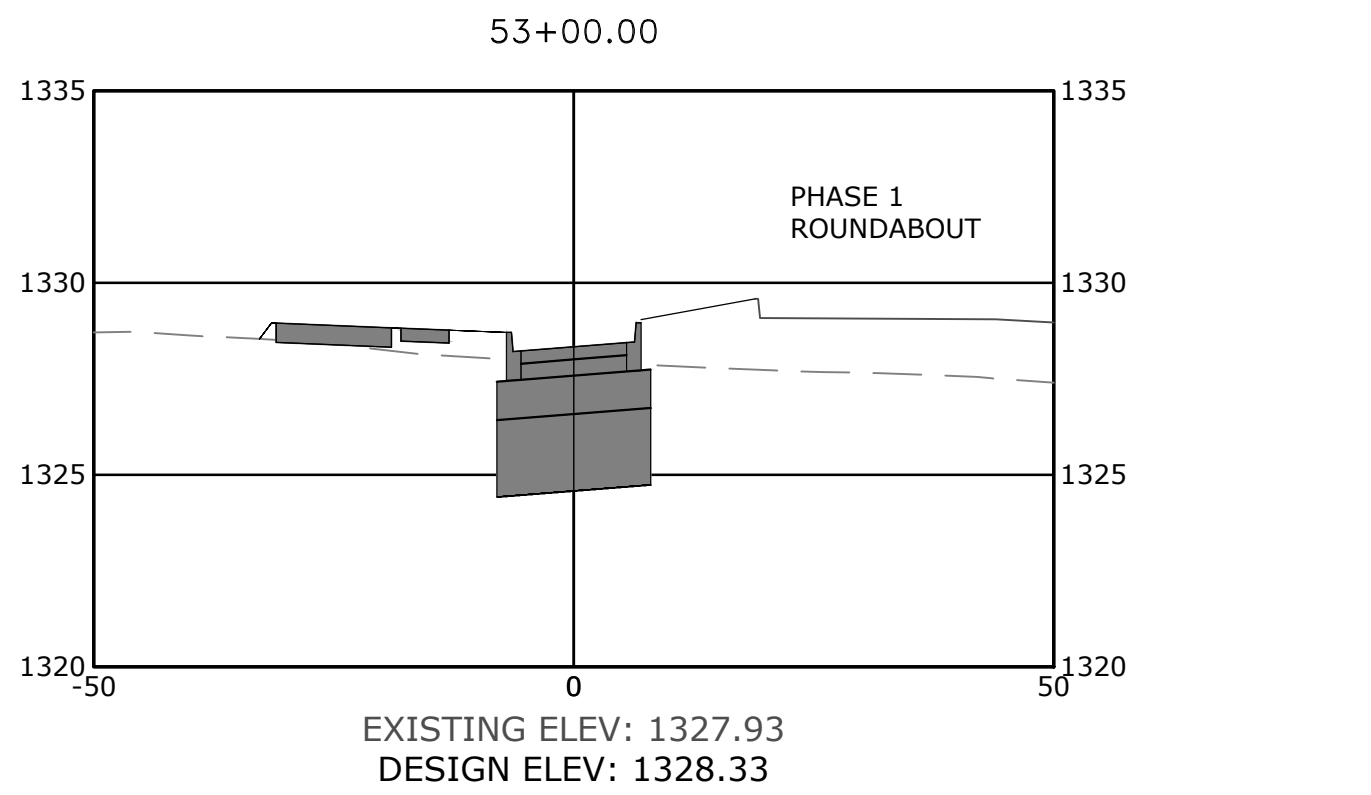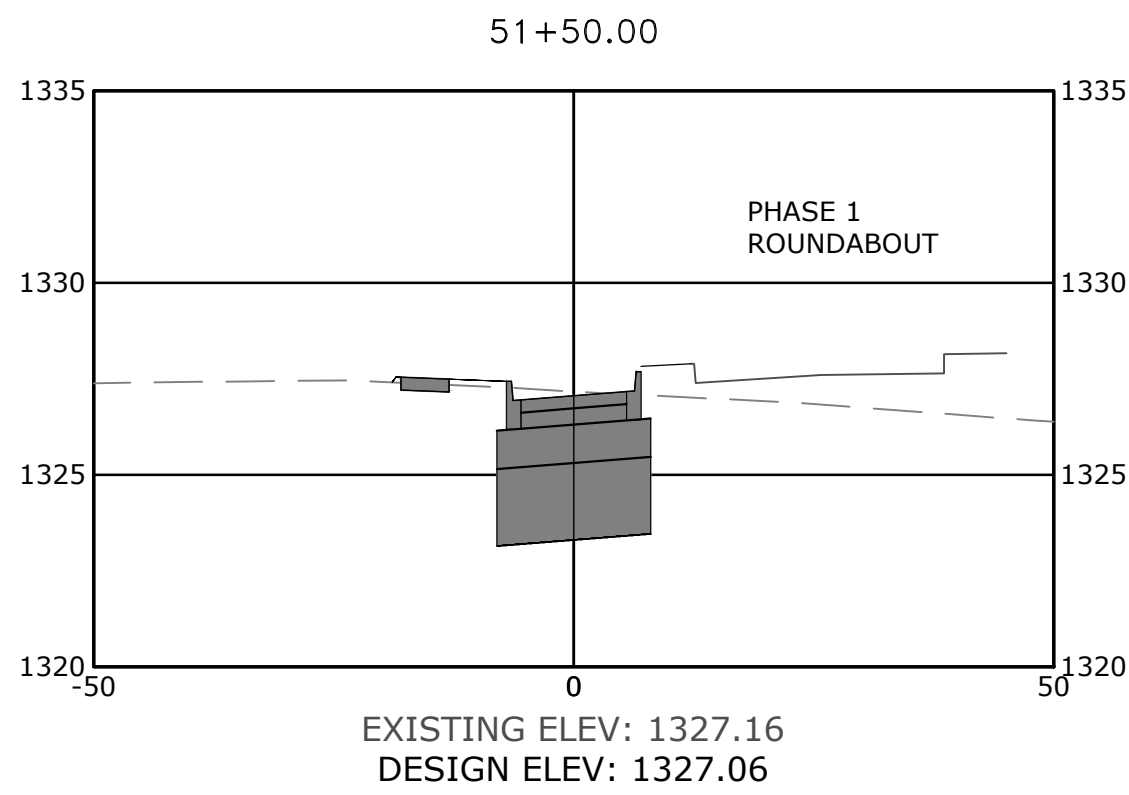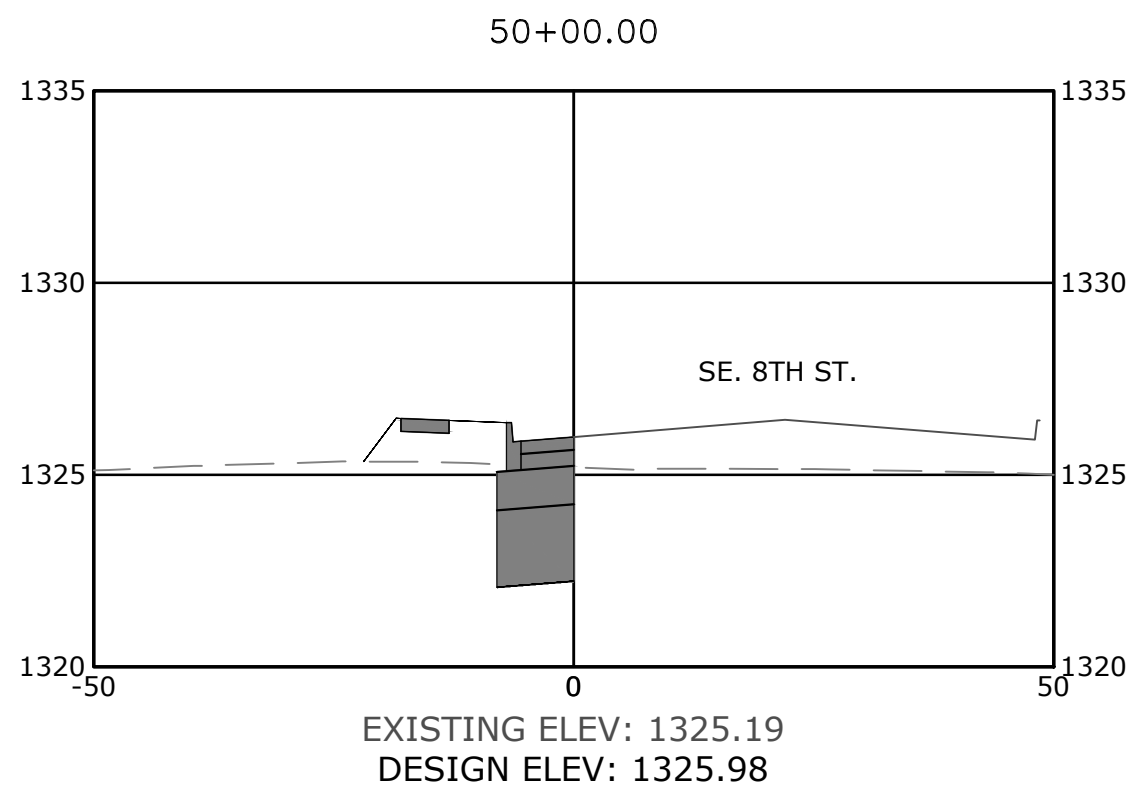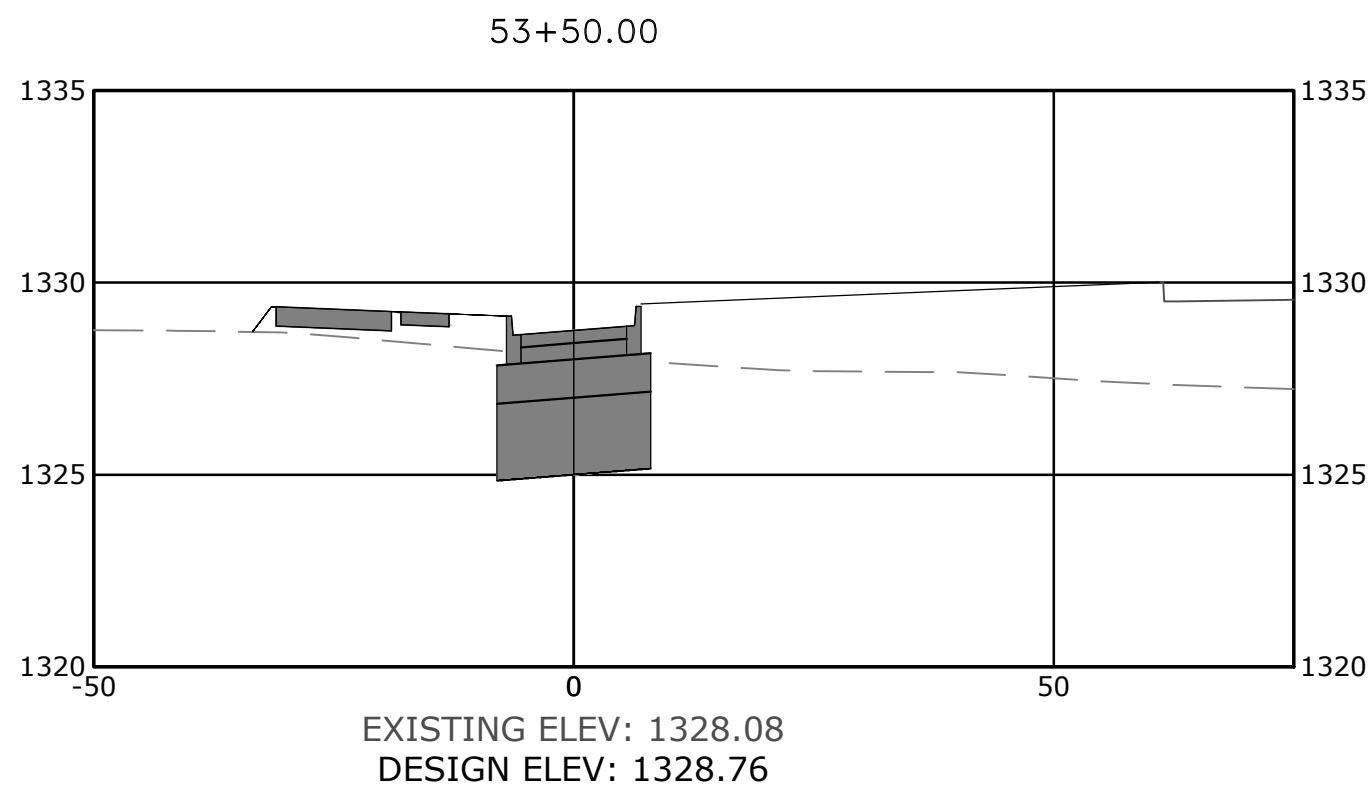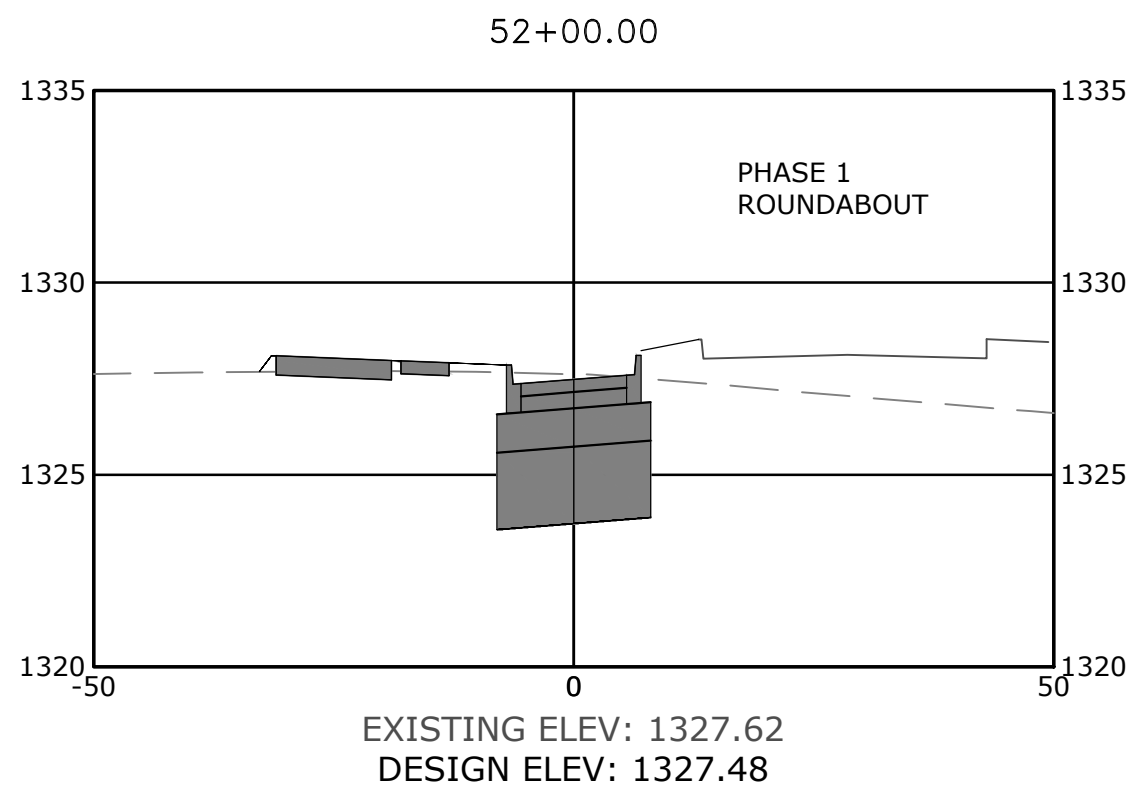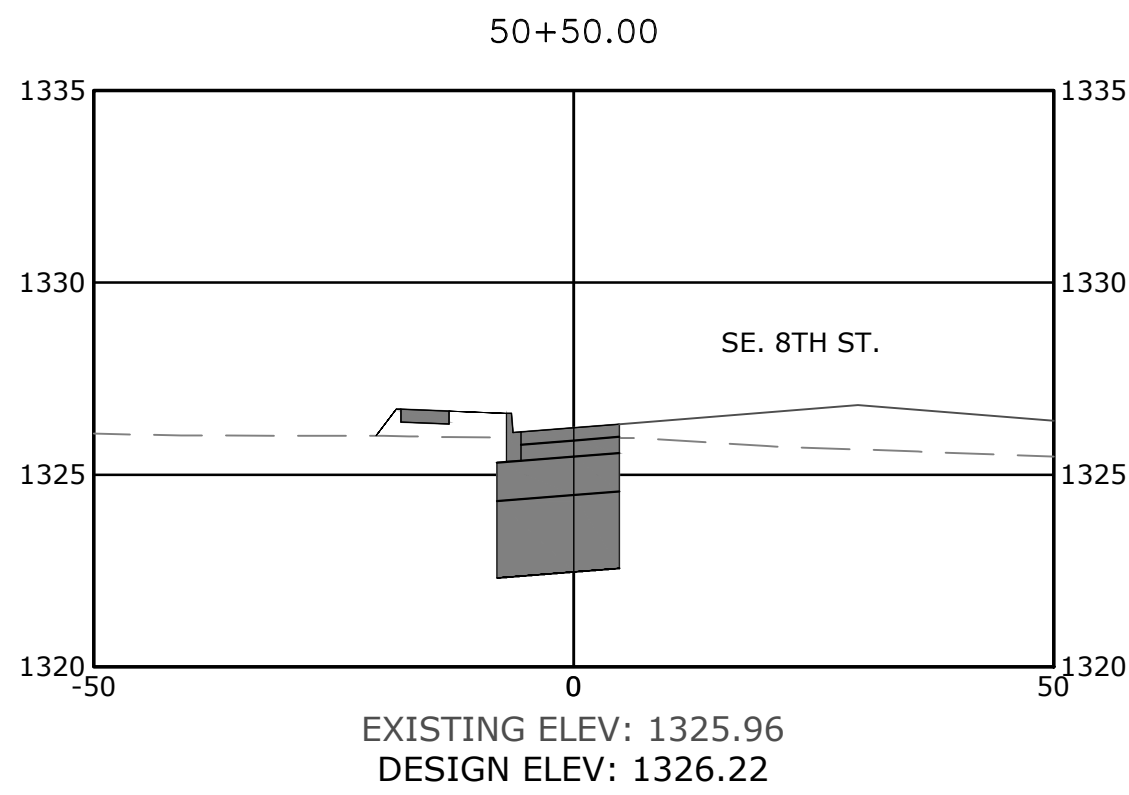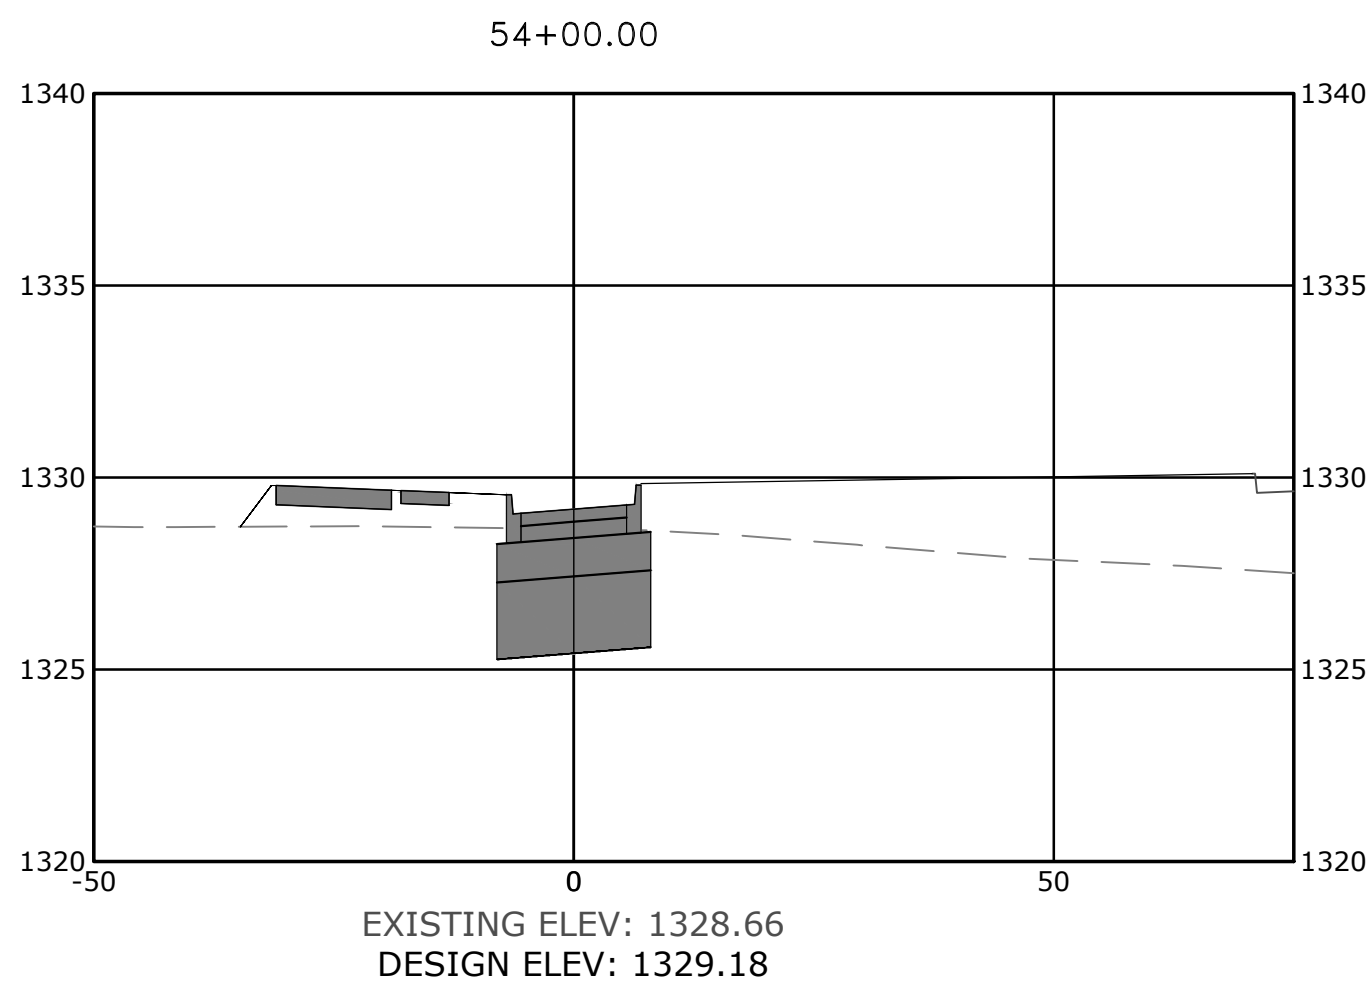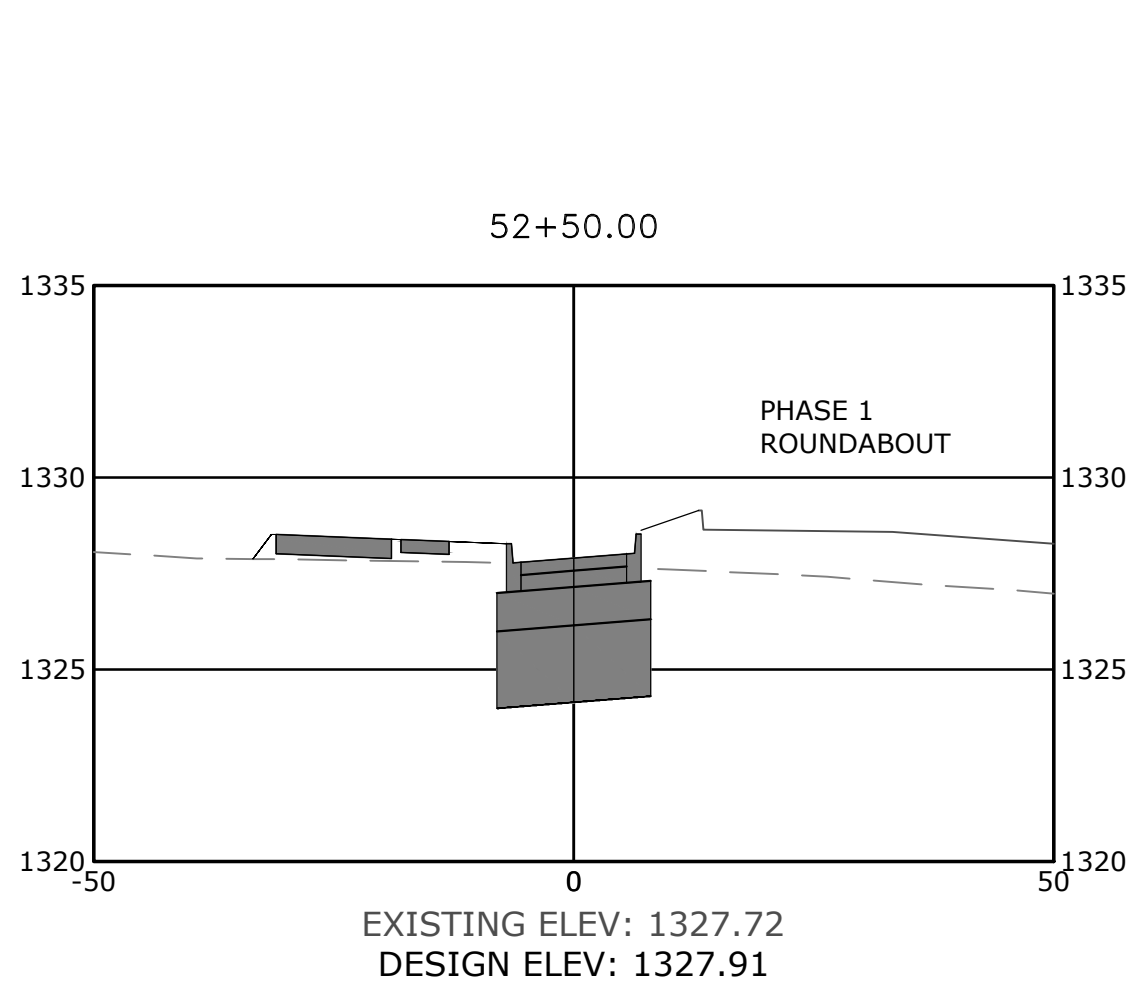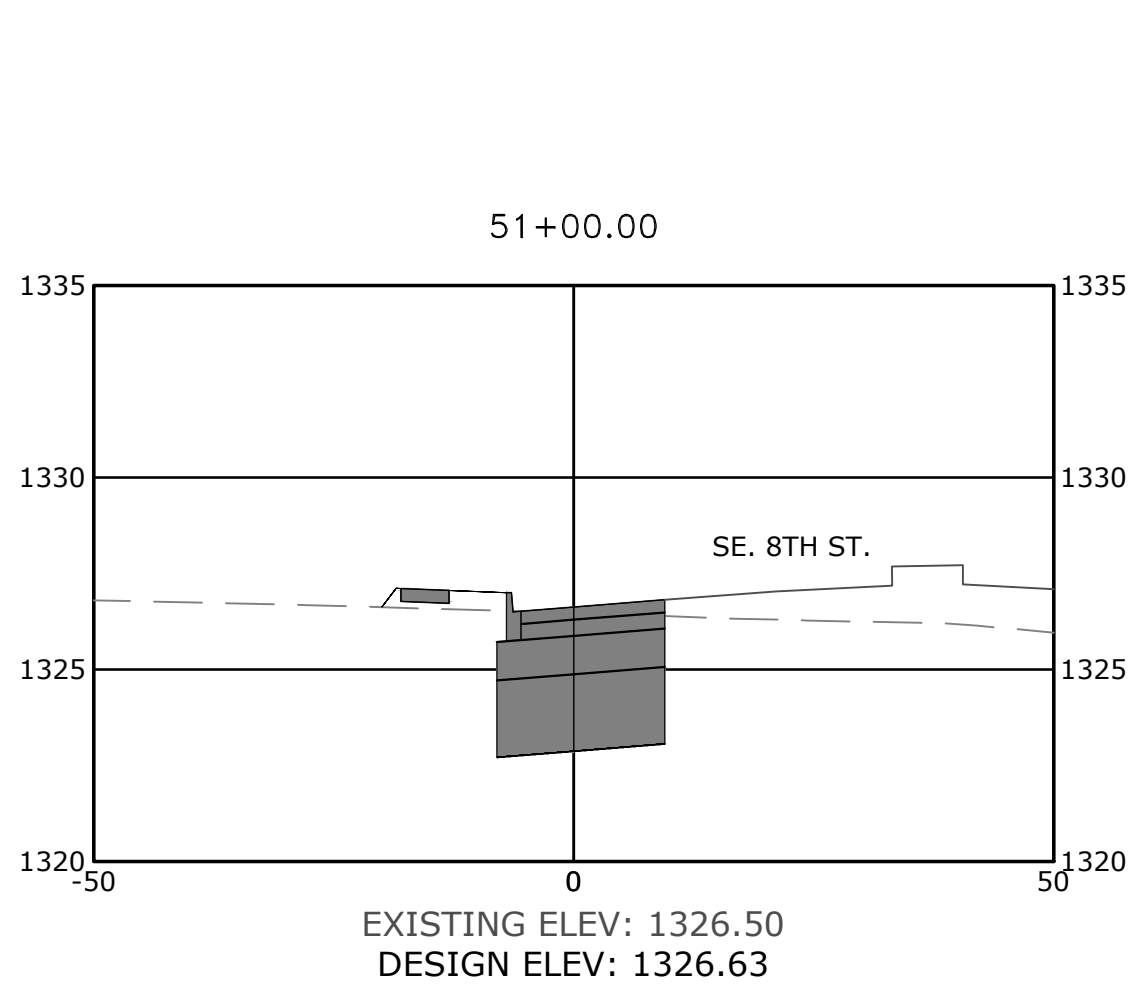

MCE McClelland Consulting Engineers, Inc.
DESIGNED TO SERVE
1580 E. STEARNS ST.
FAYETTEVILLE, ARKANSAS 72703
(479) 443-2377
HTTP://WWW.MCE.US.COM

PRELIMINARY
NOT FOR
CONSTRUCTION

ORIGINAL SIGNATURE ON FILE

WATER TOWER RD. PH.3
SE. 6TH ST. TO BATTLEFIELD BLVD.
BENTONVILLE, AR

BENTONVILLE

B

ENGINEERING

811

Know what's below.
Call before you dig.








REV	DATE	DESCRIPTION

CROSS
SECTIONS SE.
8TH ST.
BYPASS- STA.
50+00 TO STA.
54+00

DESIGNED BY: ELA	DRAWN BY : WAS
DATE: 1/31/2022	REVISION: 30%
SCALE: NTS	JOB NUMBER: 21-2147

XS-1


W:\2021\21-2147 - Water Tower Road Phase III. 8th St. To E. Battlfield Blvd\Design Drawings\Sheets\21-2147- Cross Sections.dwg, PRINTED ON: January 31, 2022 @ 12:26 PM

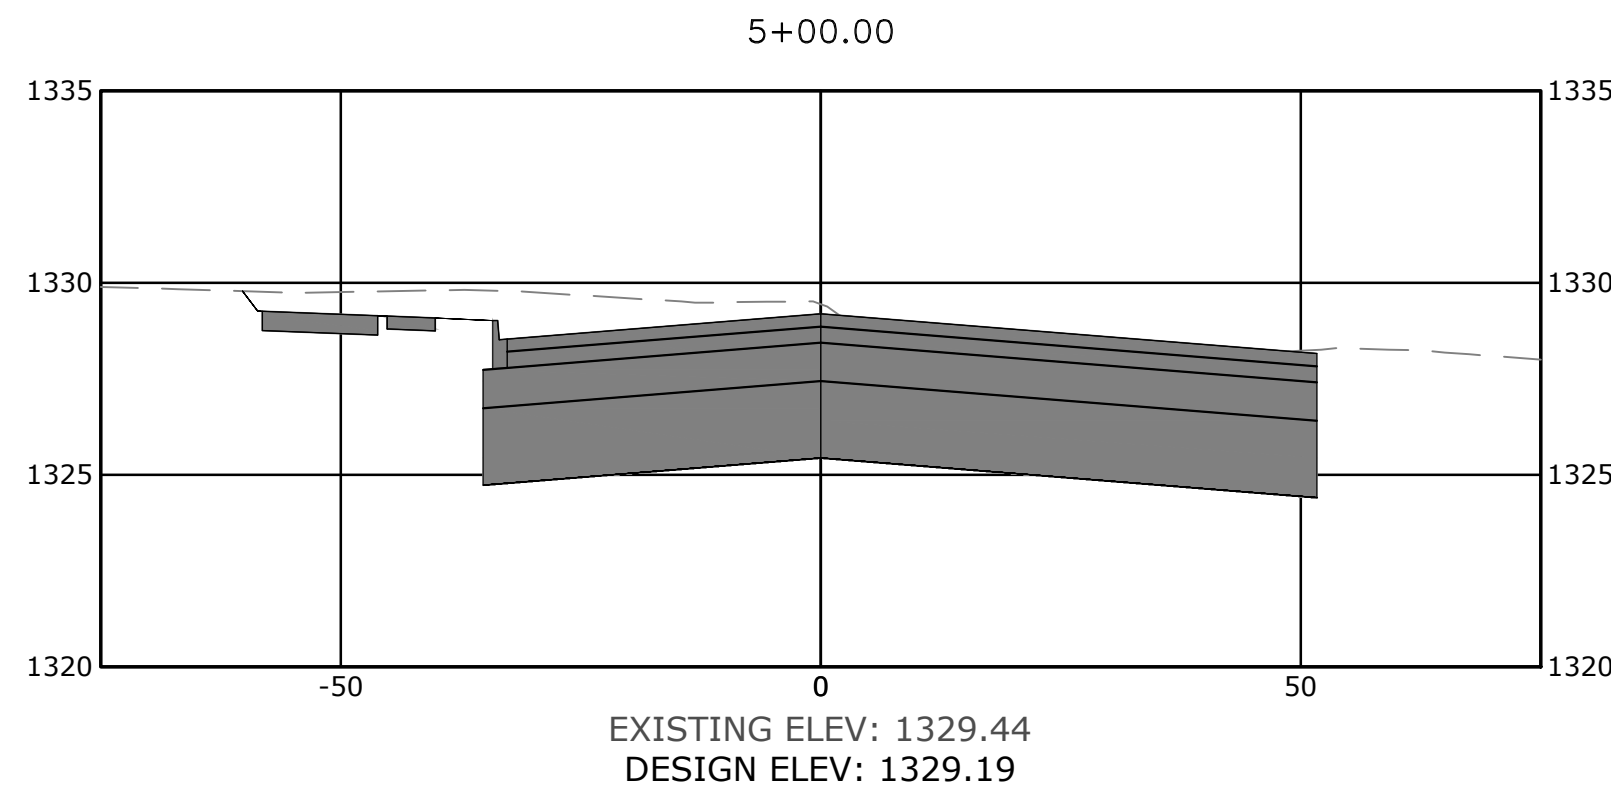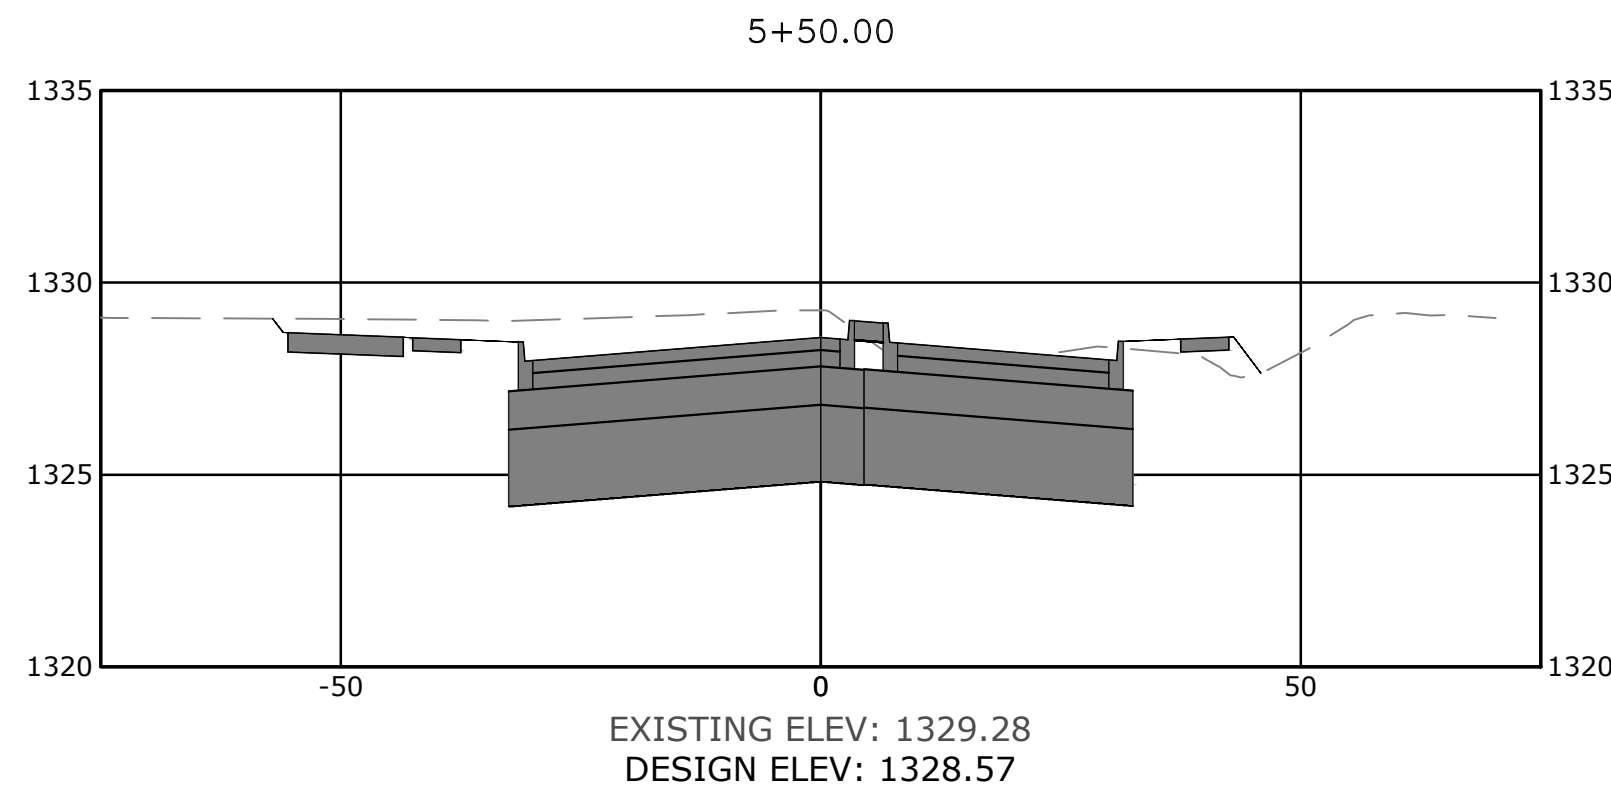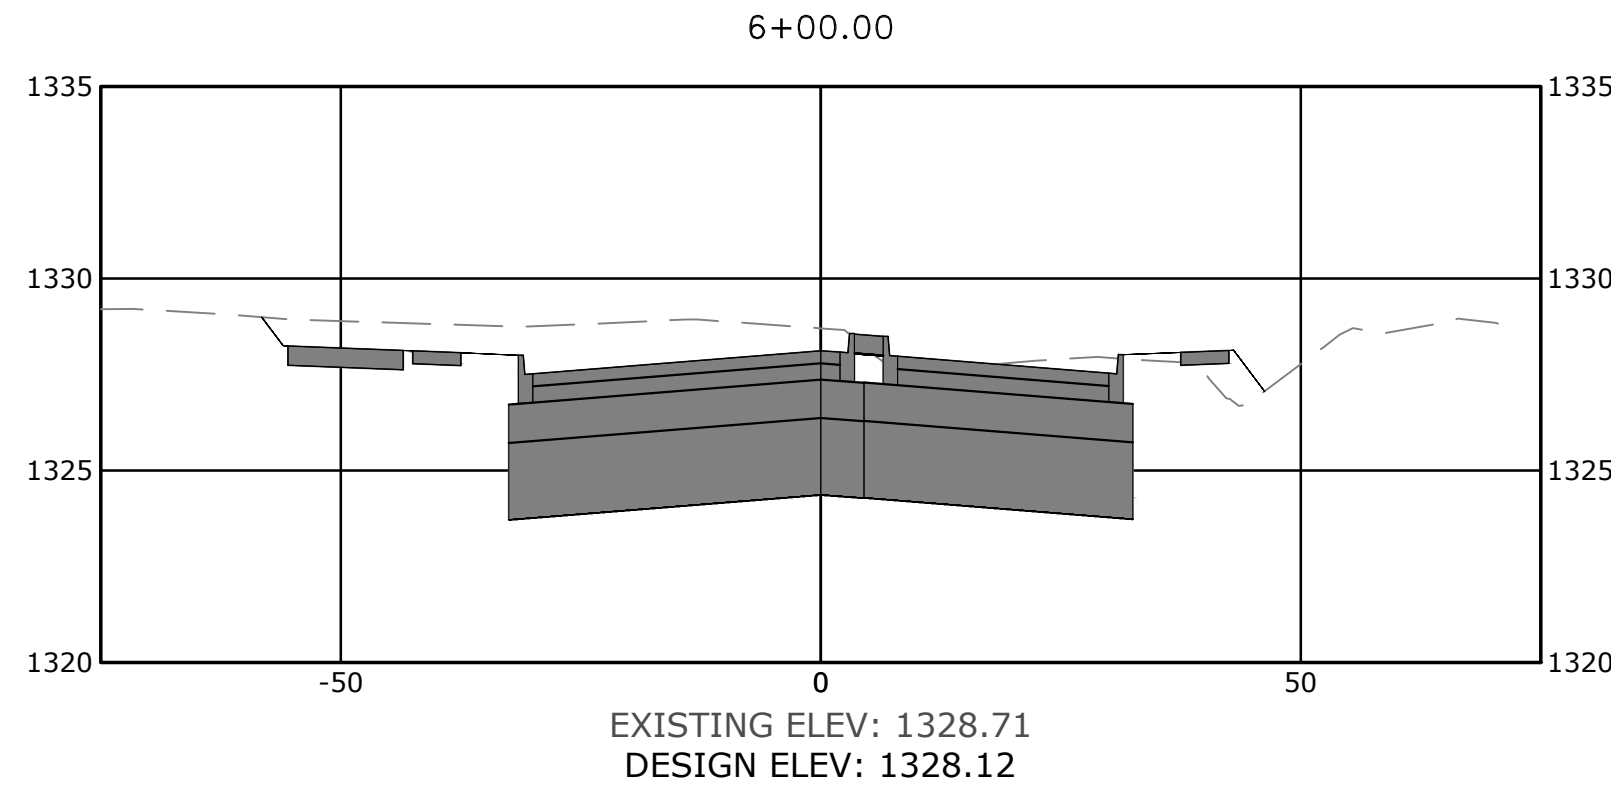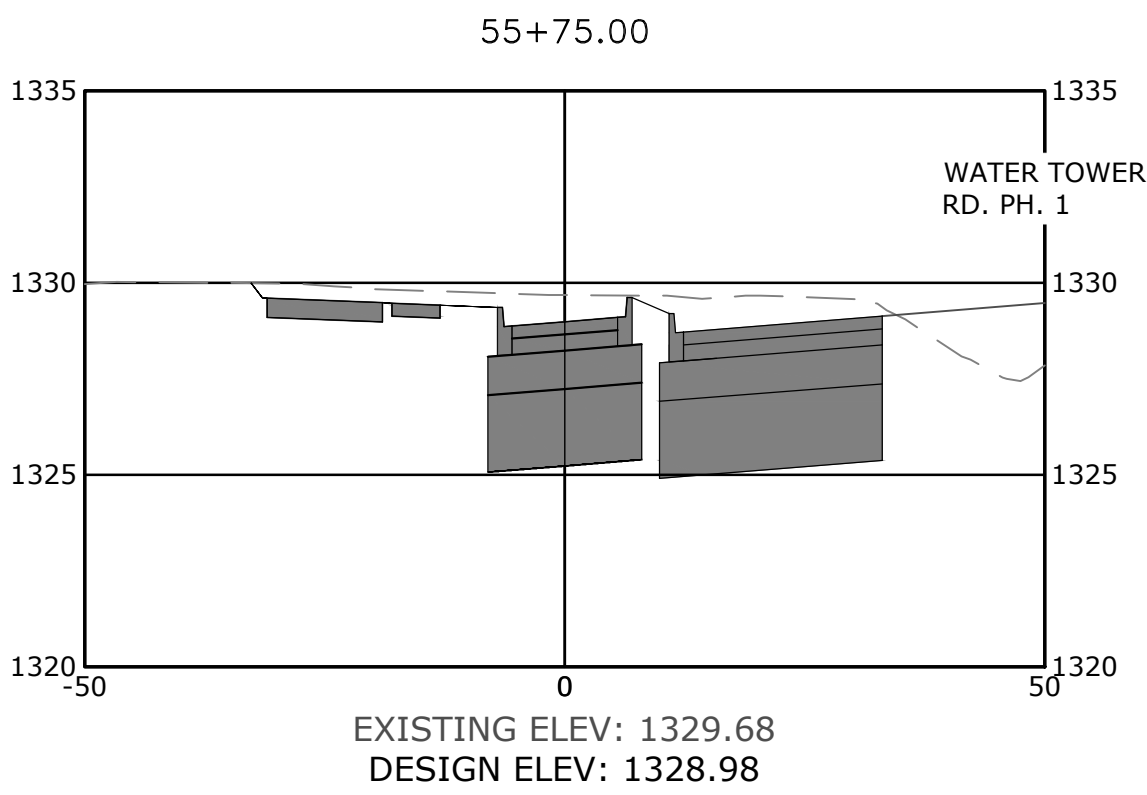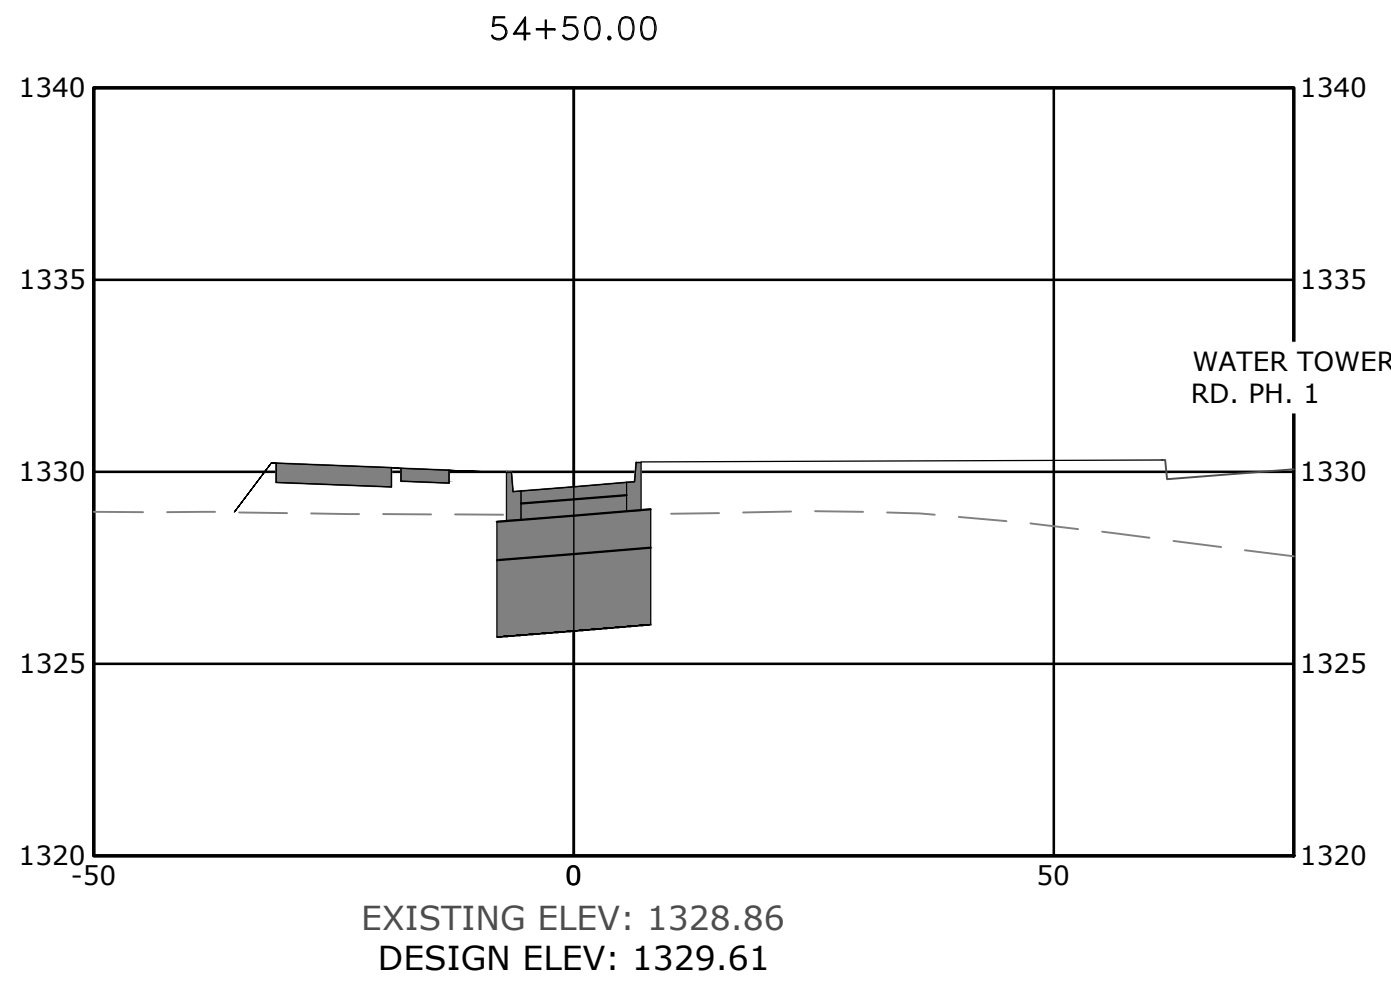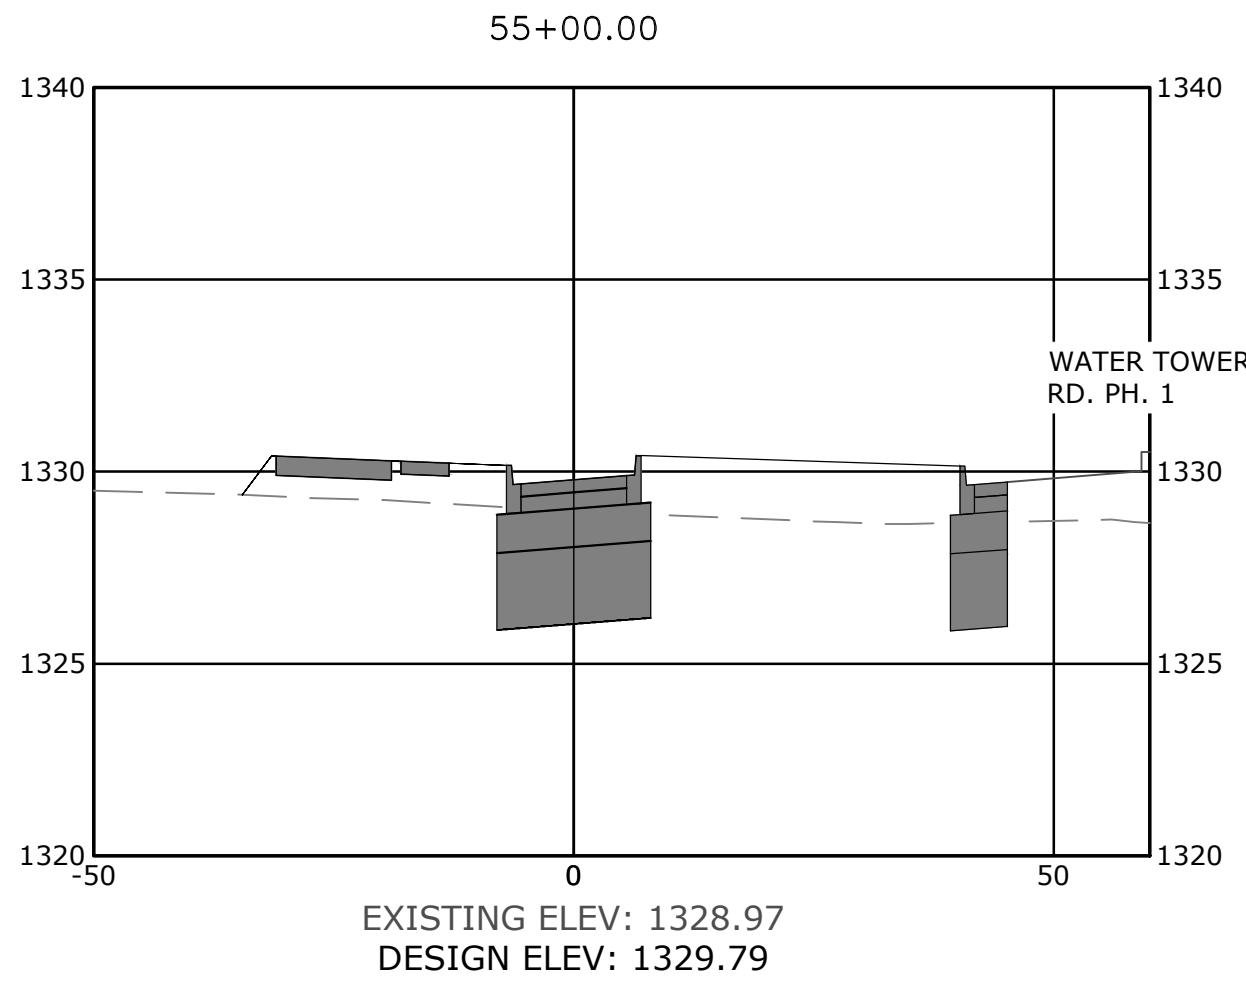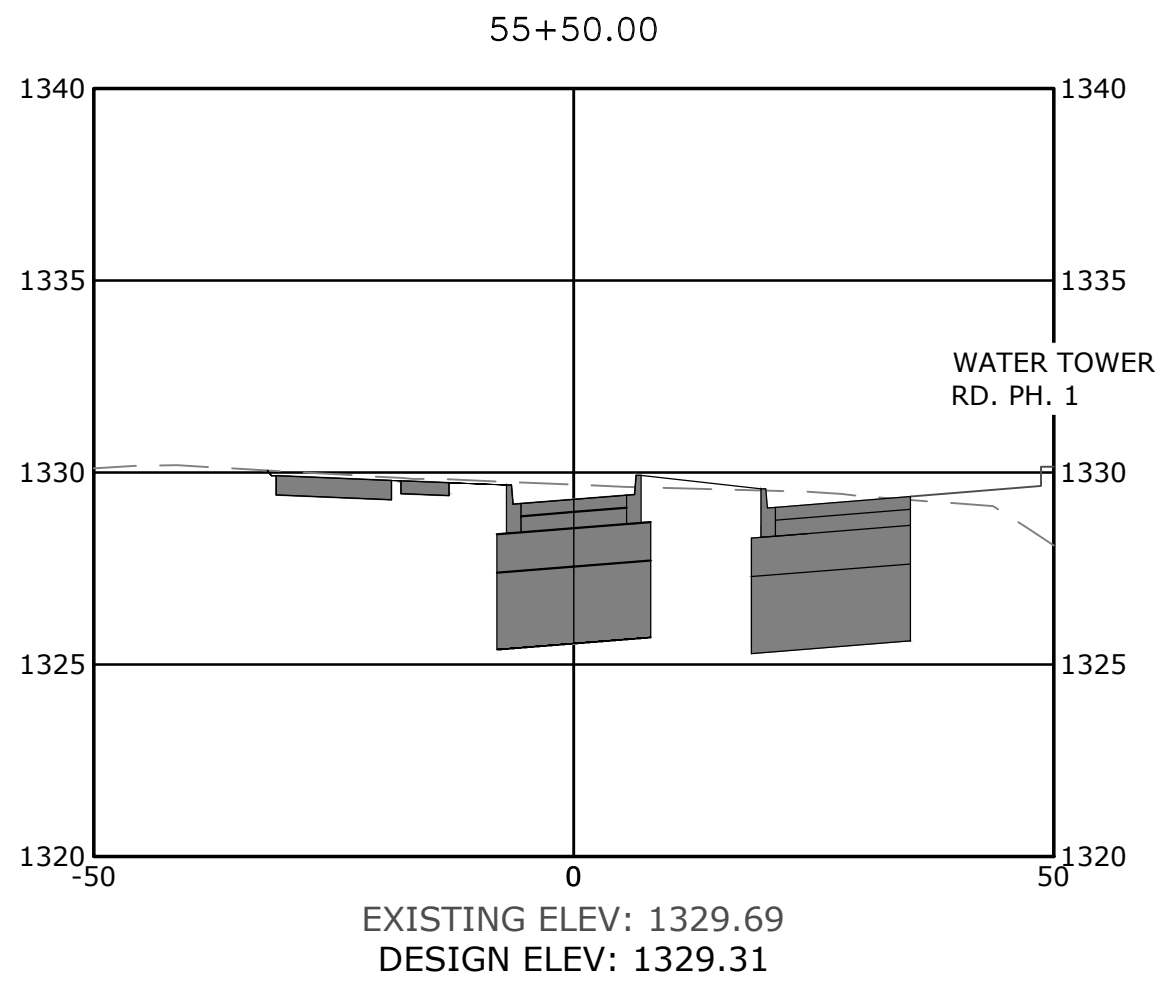

PRELIMINARY
NOT FOR
CONSTRUCTION

ORIGINAL SIGNATURE ON FILE

WATER TOWER RD. PH.13
SE. 6TH ST. TO BATTLEFIELD BLVD.
BENTONVILLE, AR

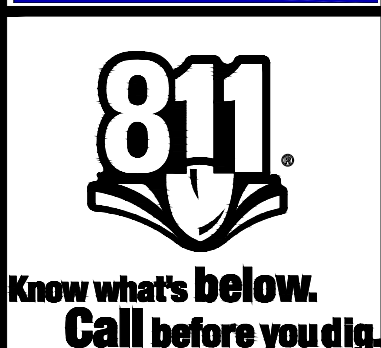







REVISONS		DESCRIPTION
REV	DATE	

CROSS
SECTION
BYPASS STA.
55+75 TO
WATER TOWER
RD. STA. 5+00

DESIGNED BY: ELA	DRAWN BY : WAS
DATE: 1/31/2022	REVISION: 30%
SCALE: NTS	JOB NUMBER: 21-2147

XS-2

W:\2021\21-2147 - Water Tower Road Phase III. 8th St. To E. Battlfield Blvd\Design Drawings\Sheets\21-2147- Cross Sections.dwg, PRINTED ON: January 31, 2022 @ 12:26 PM

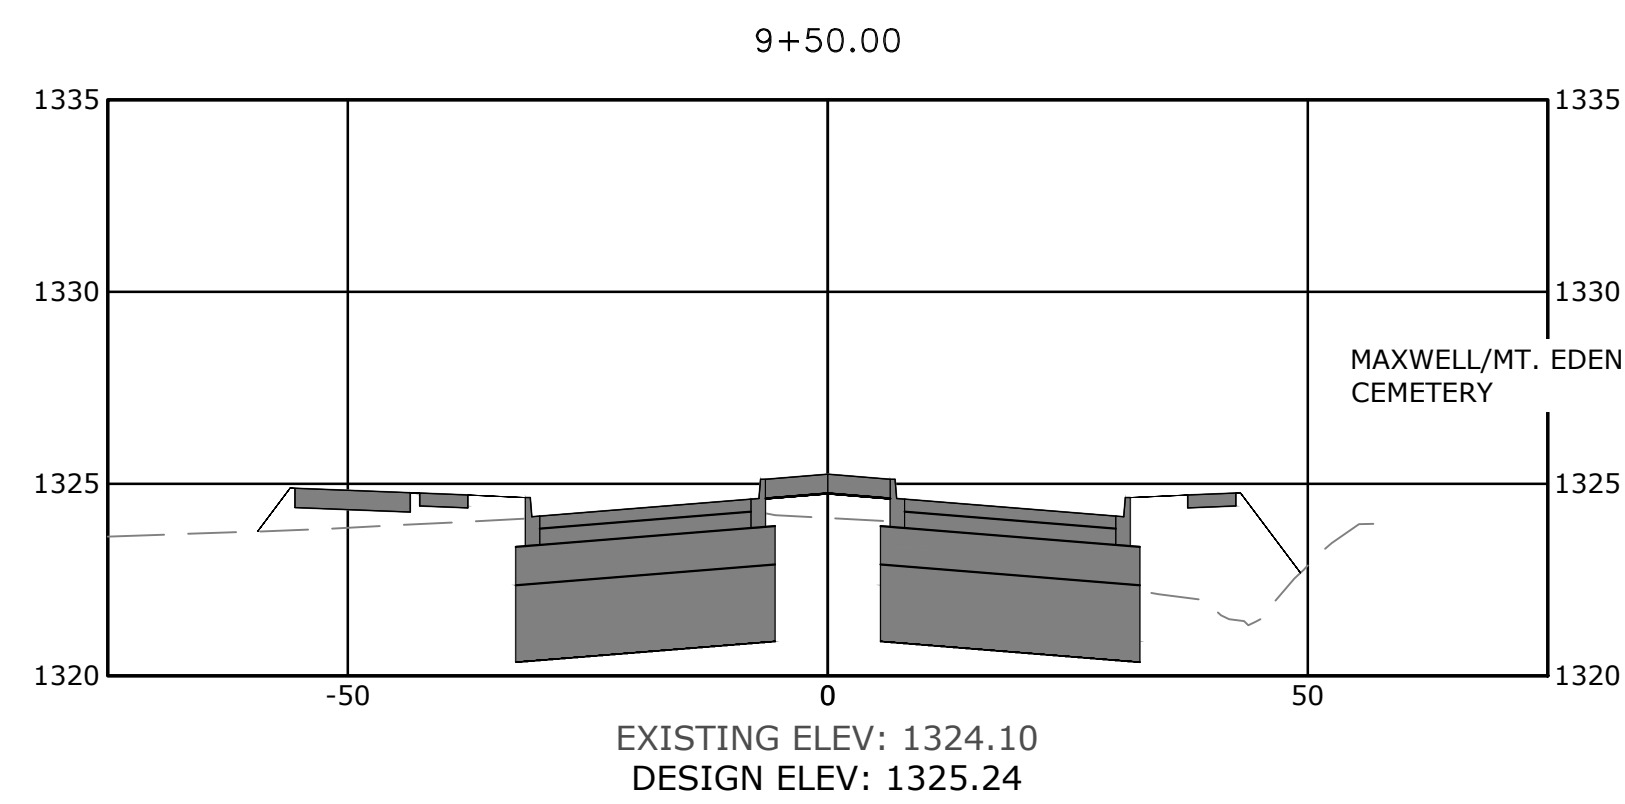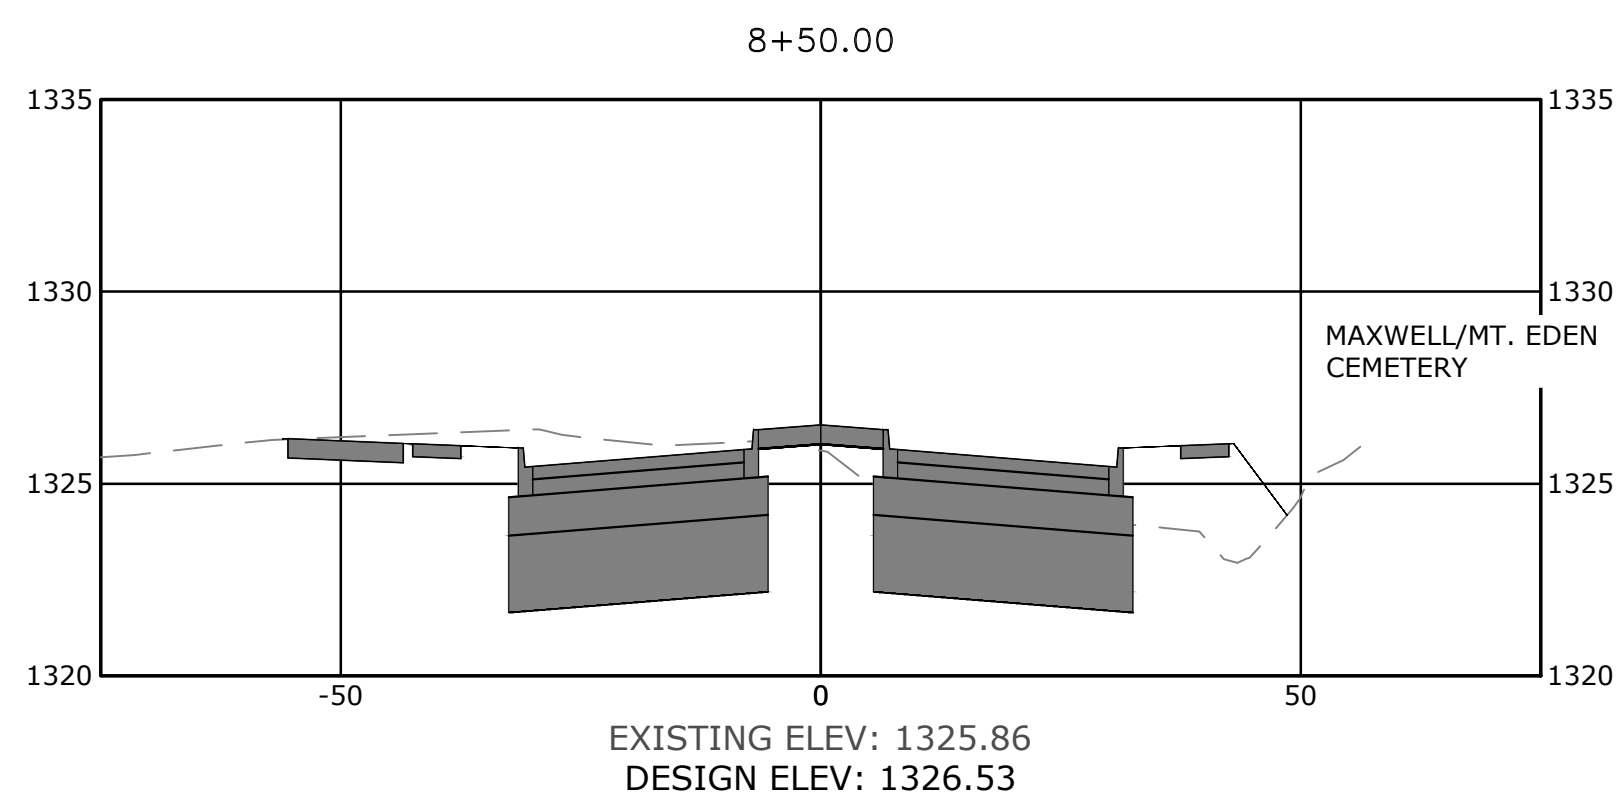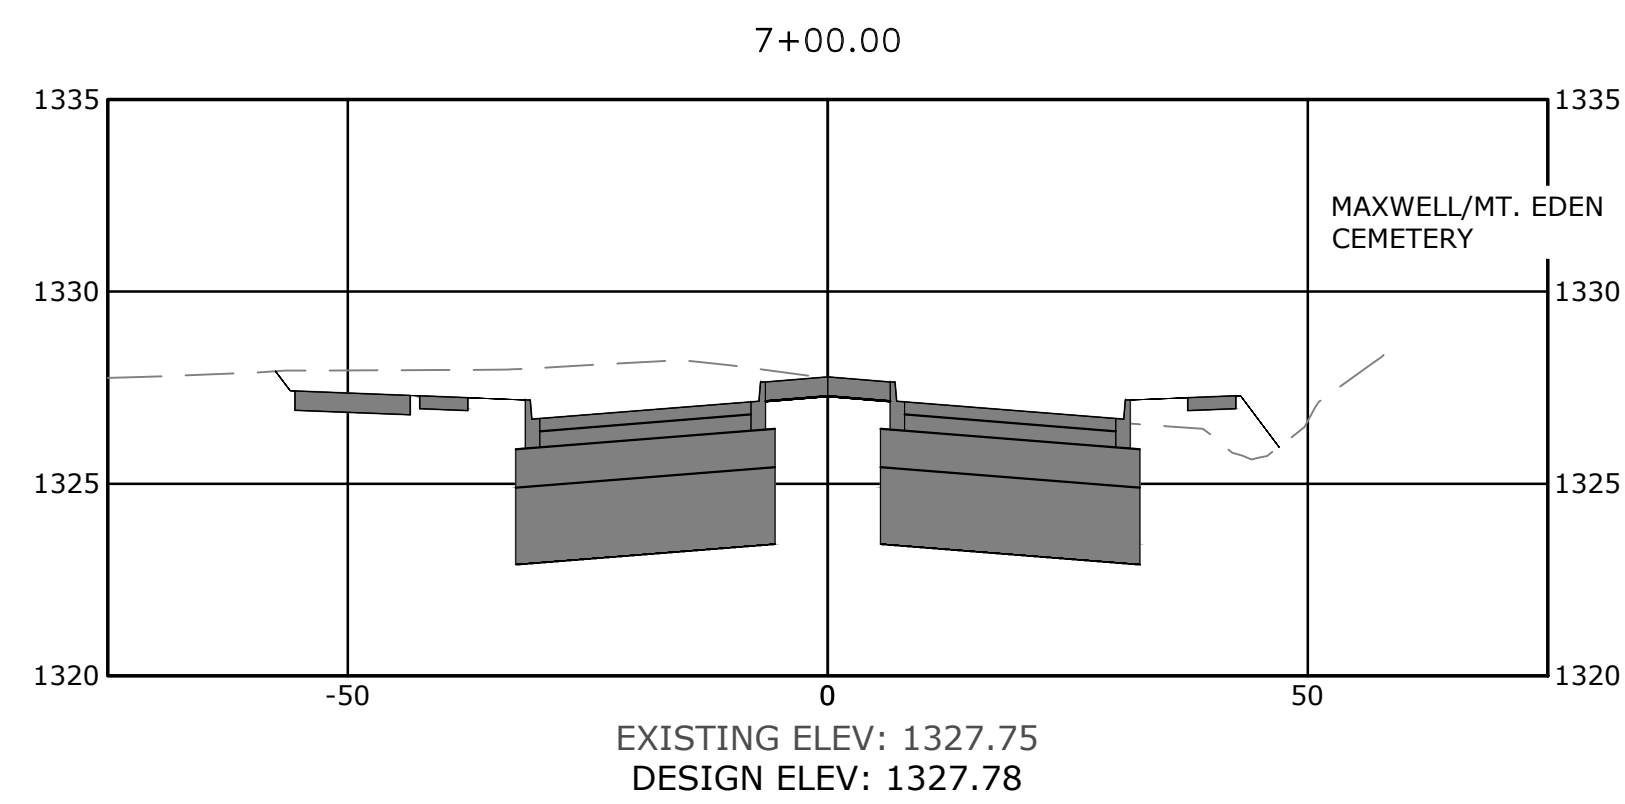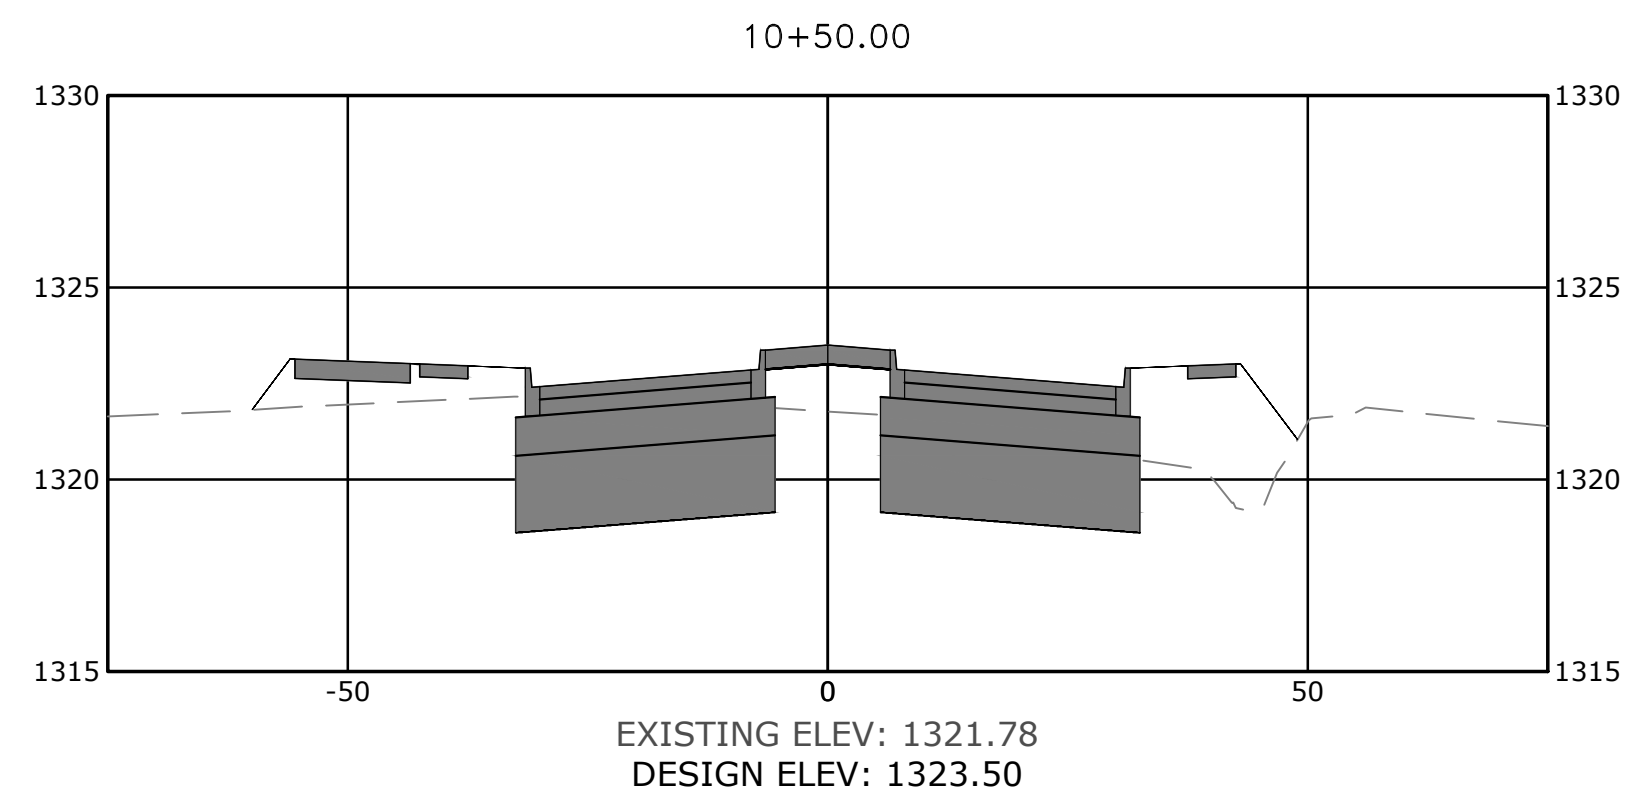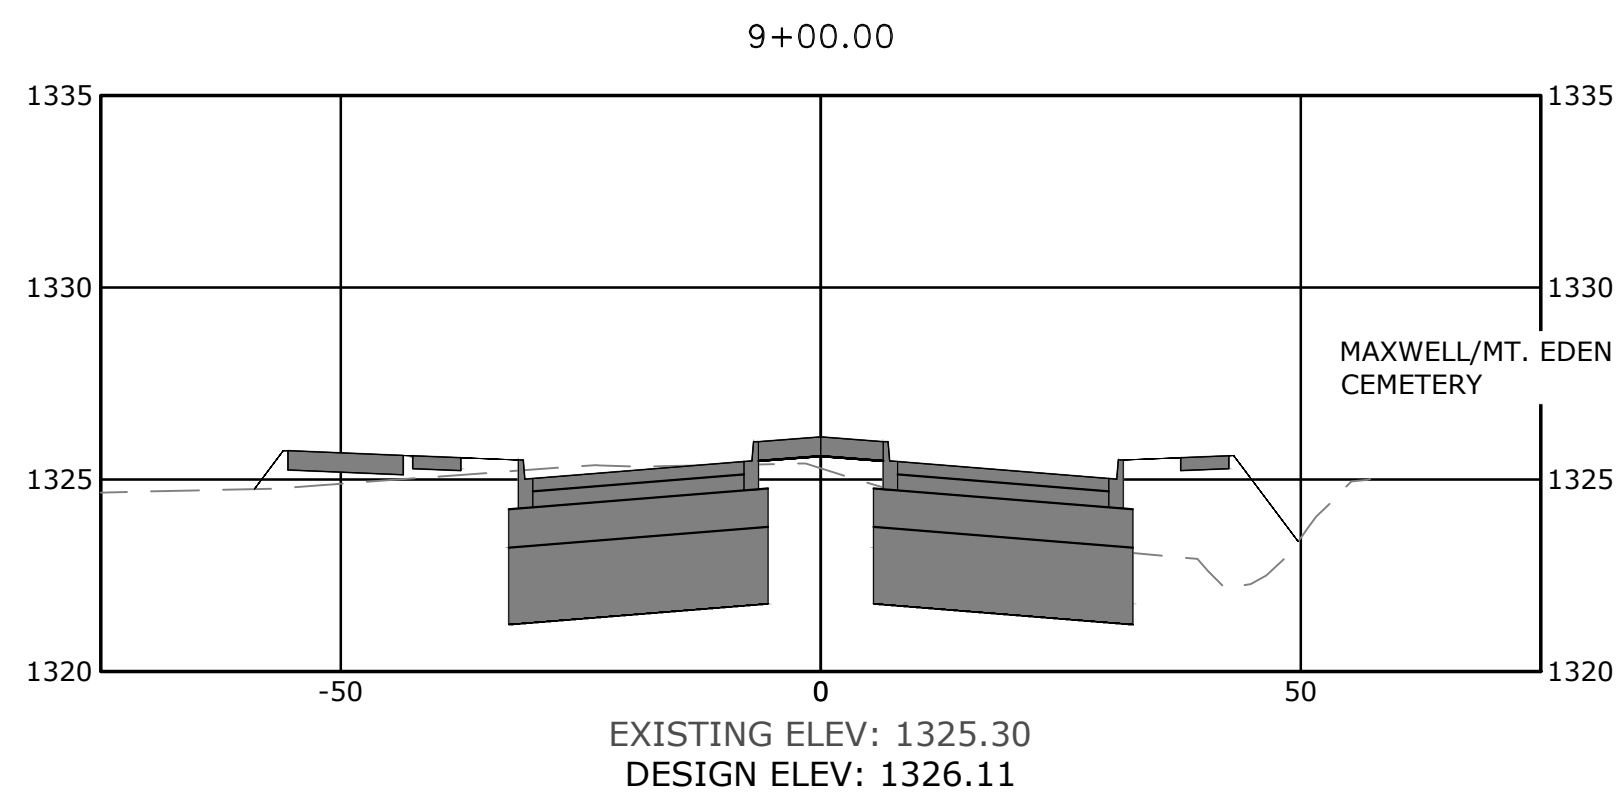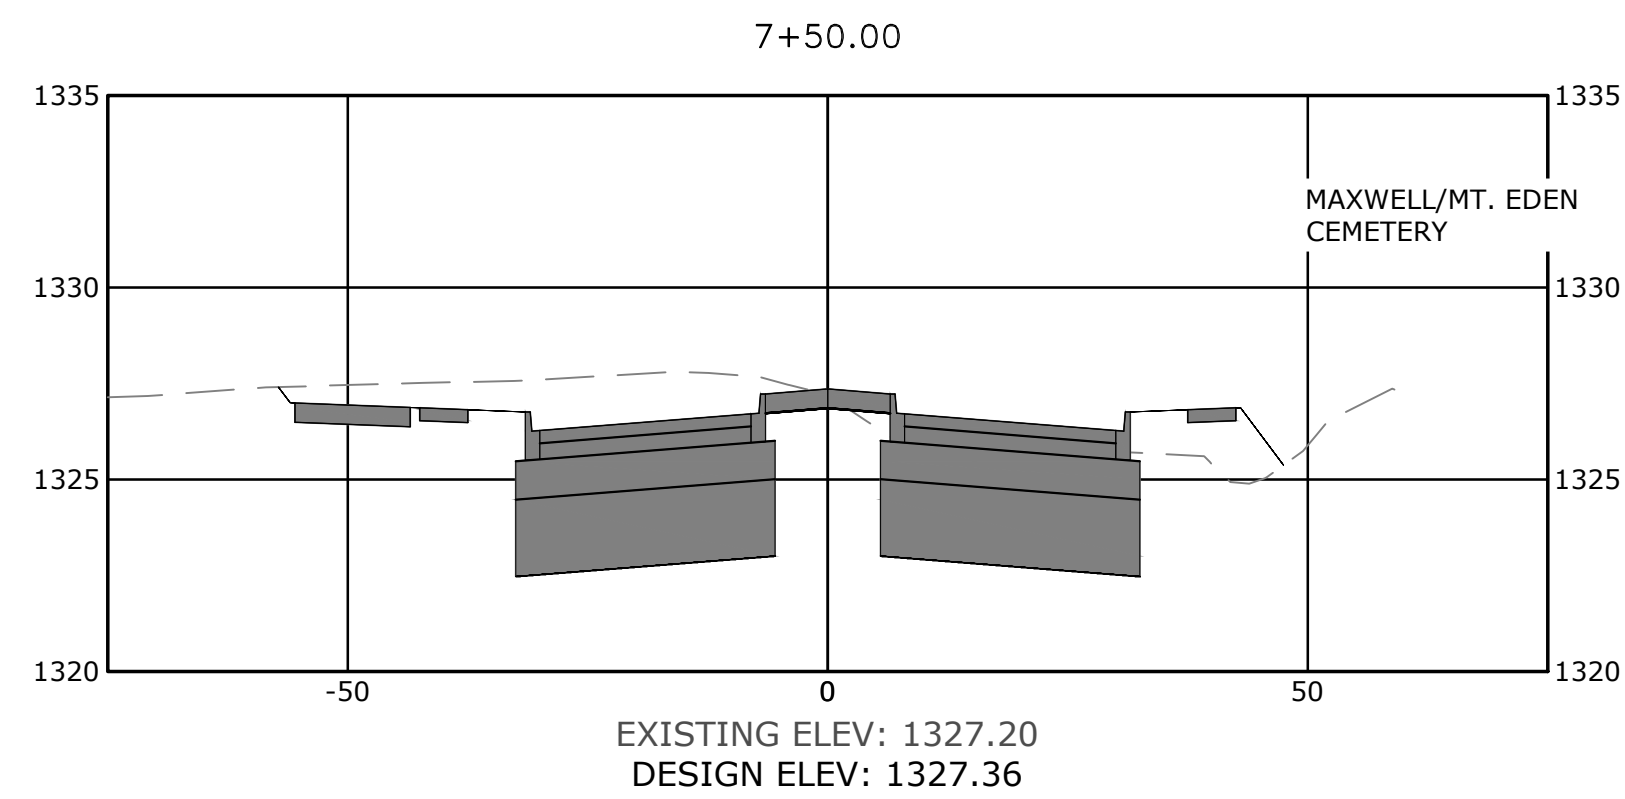

PRELIMINARY
NOT FOR
CONSTRUCTION

ORIGINAL SIGNATURE ON FILE

WATER TOWER RD. PH.3
SE. 6TH ST. TO BATTLEFIELD BLVD.
BENTONVILLE, AR









REVISONS		DESCRIPTION
REV	DATE	

CROSS
SECTIONS
WATER TOWER
RD.- STA.
6+50 TO STA.
10+50

DESIGNED BY: ELA	DRAWN BY : WAS
DATE: 1/31/2022	REVISION: 30%
SCALE: NTS	JOB NUMBER: 21-2147

XS-3

W:\2021\21-2147 - Water Tower Road Phase III. 8th St. To E. Battlfield Blvd\Design Drawings\Sheets\21-2147- Cross Sections.dwg, PRINTED ON: January 31, 2022 @ 12:26 PM

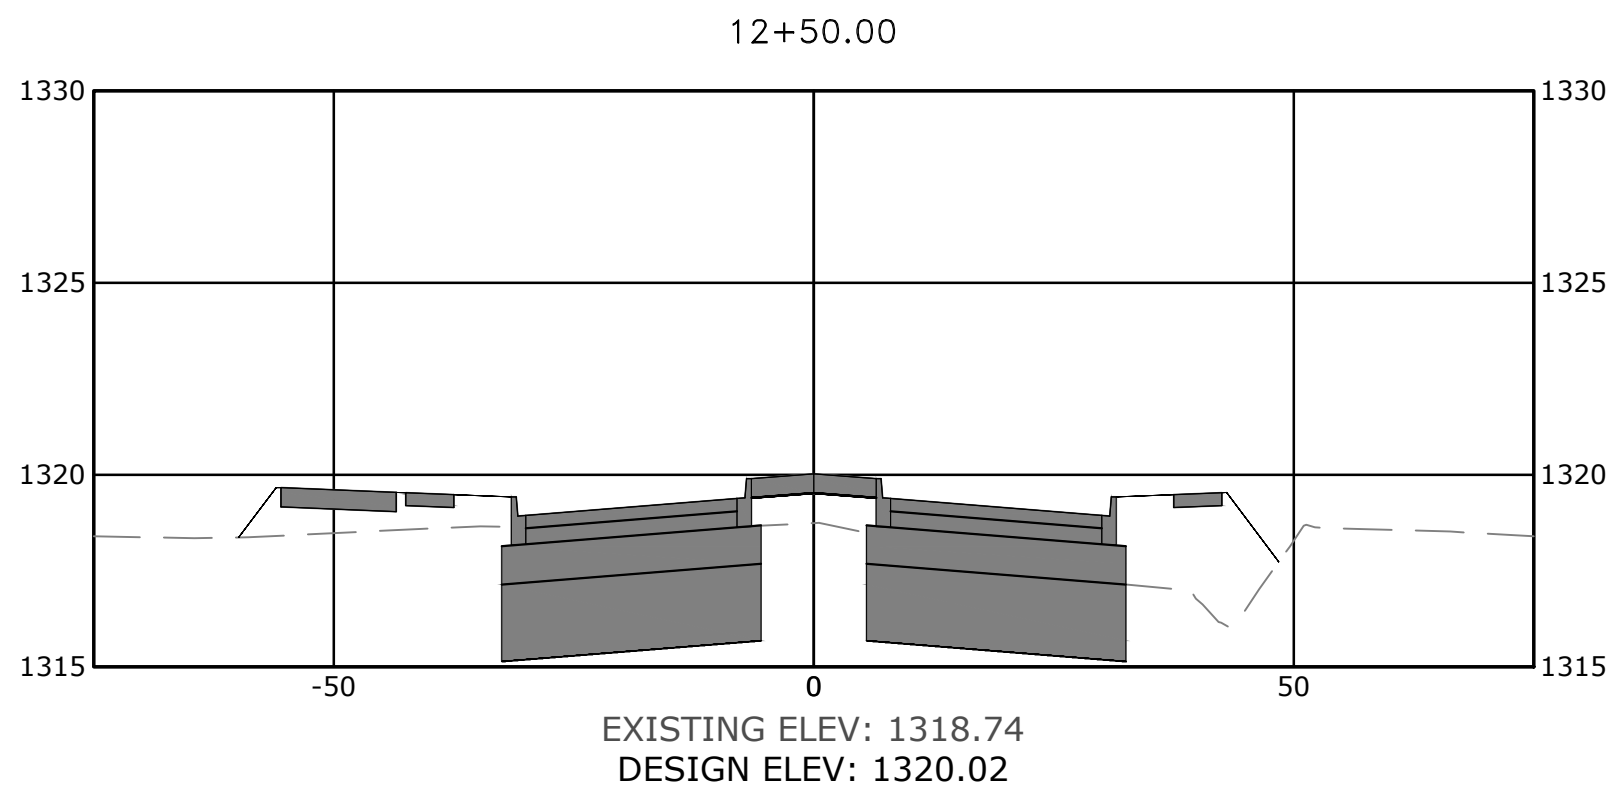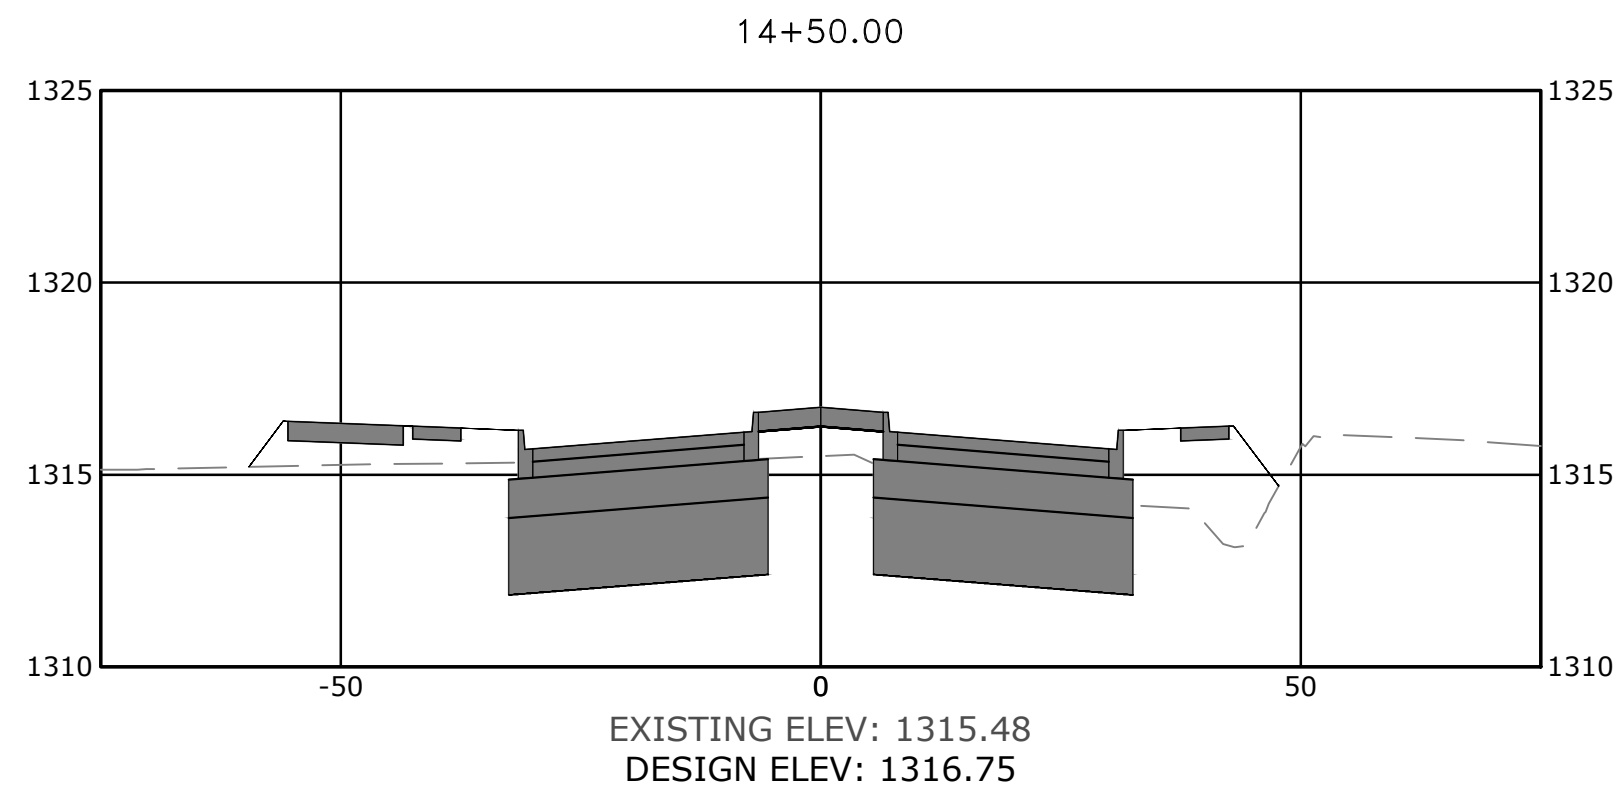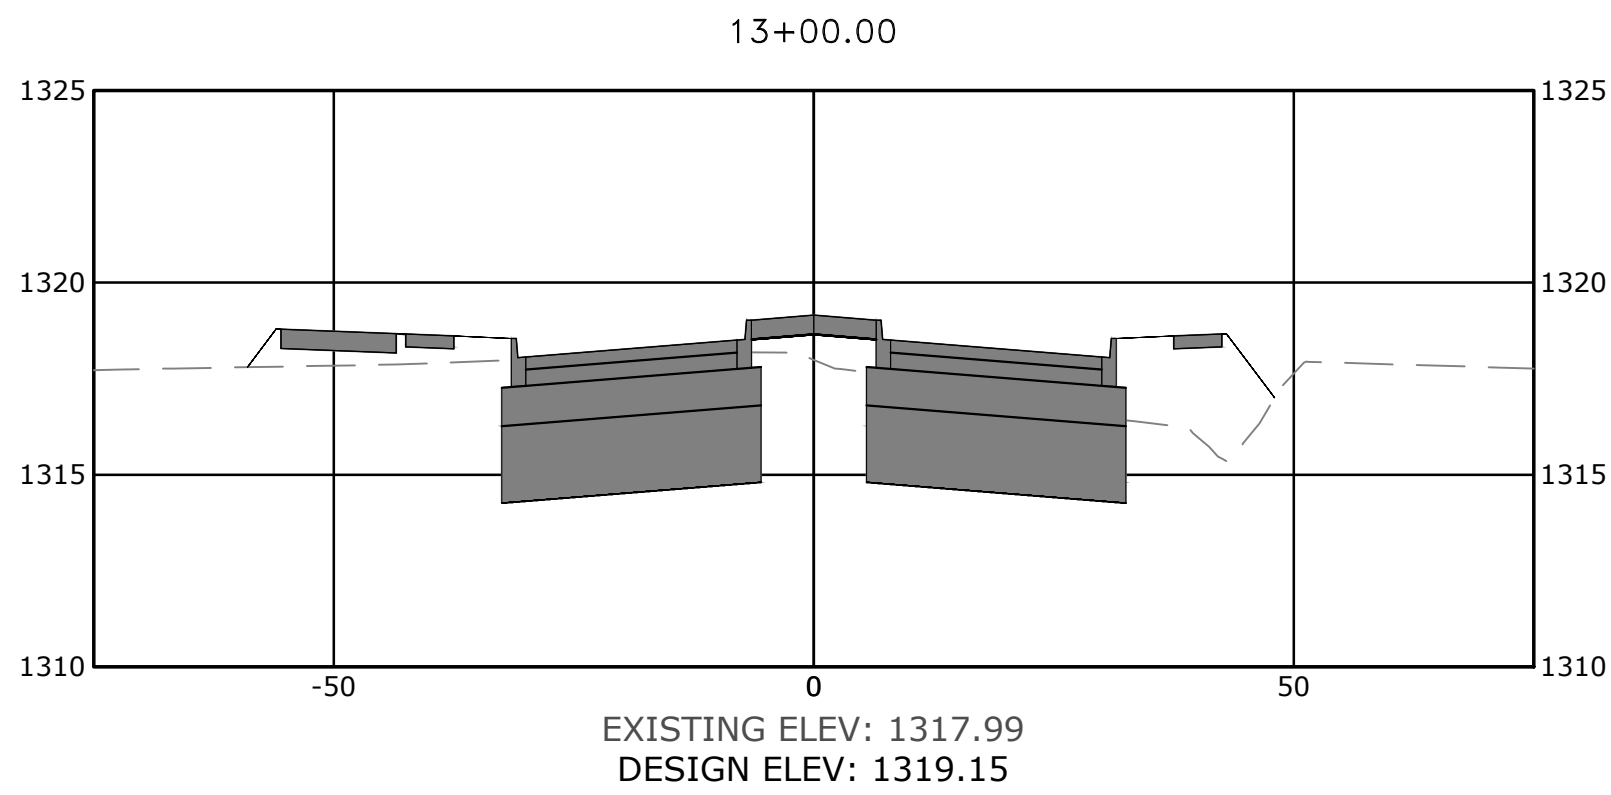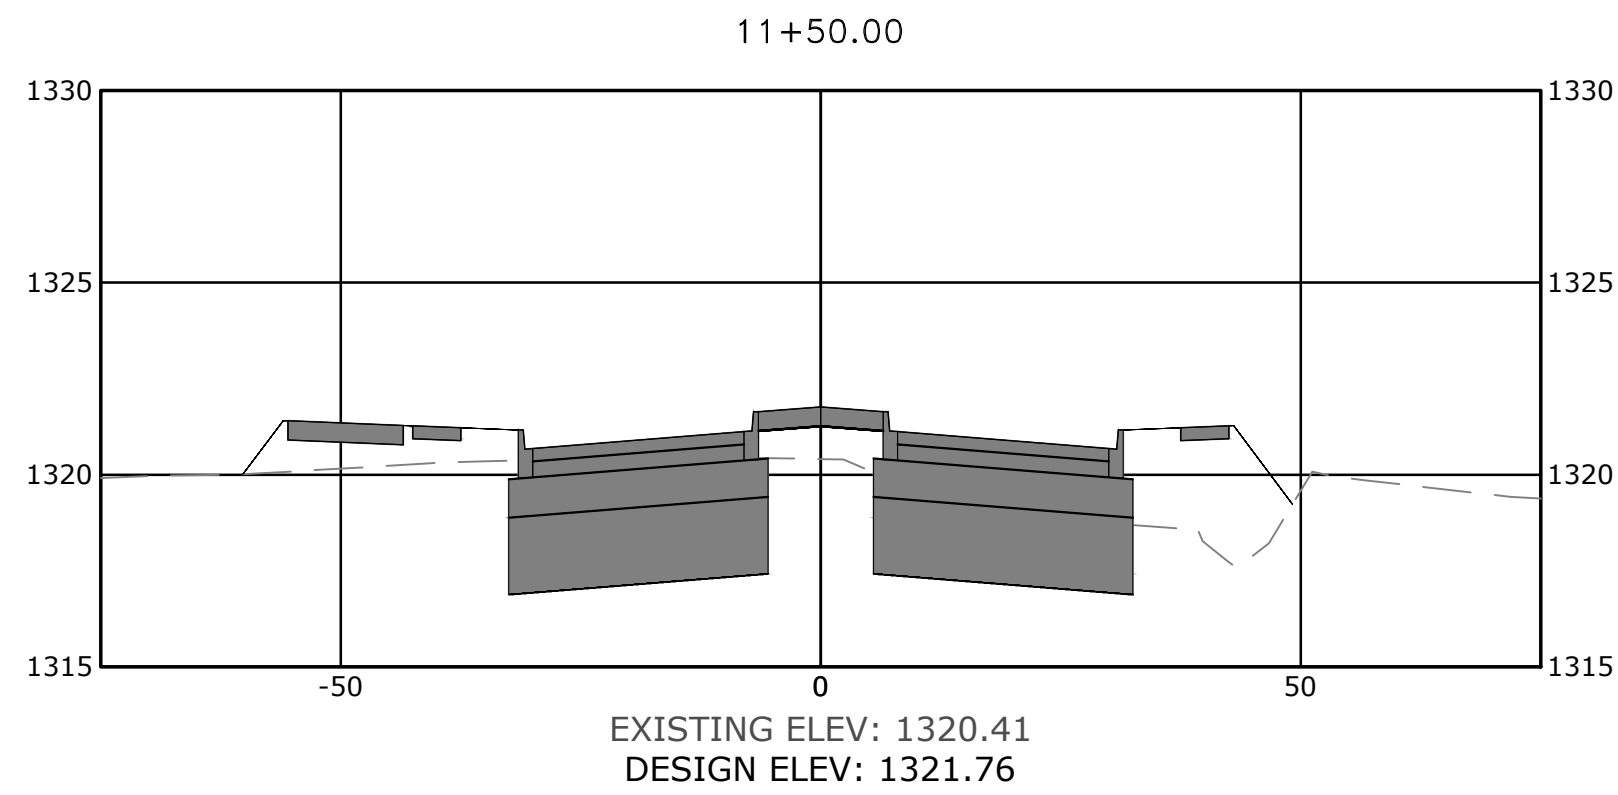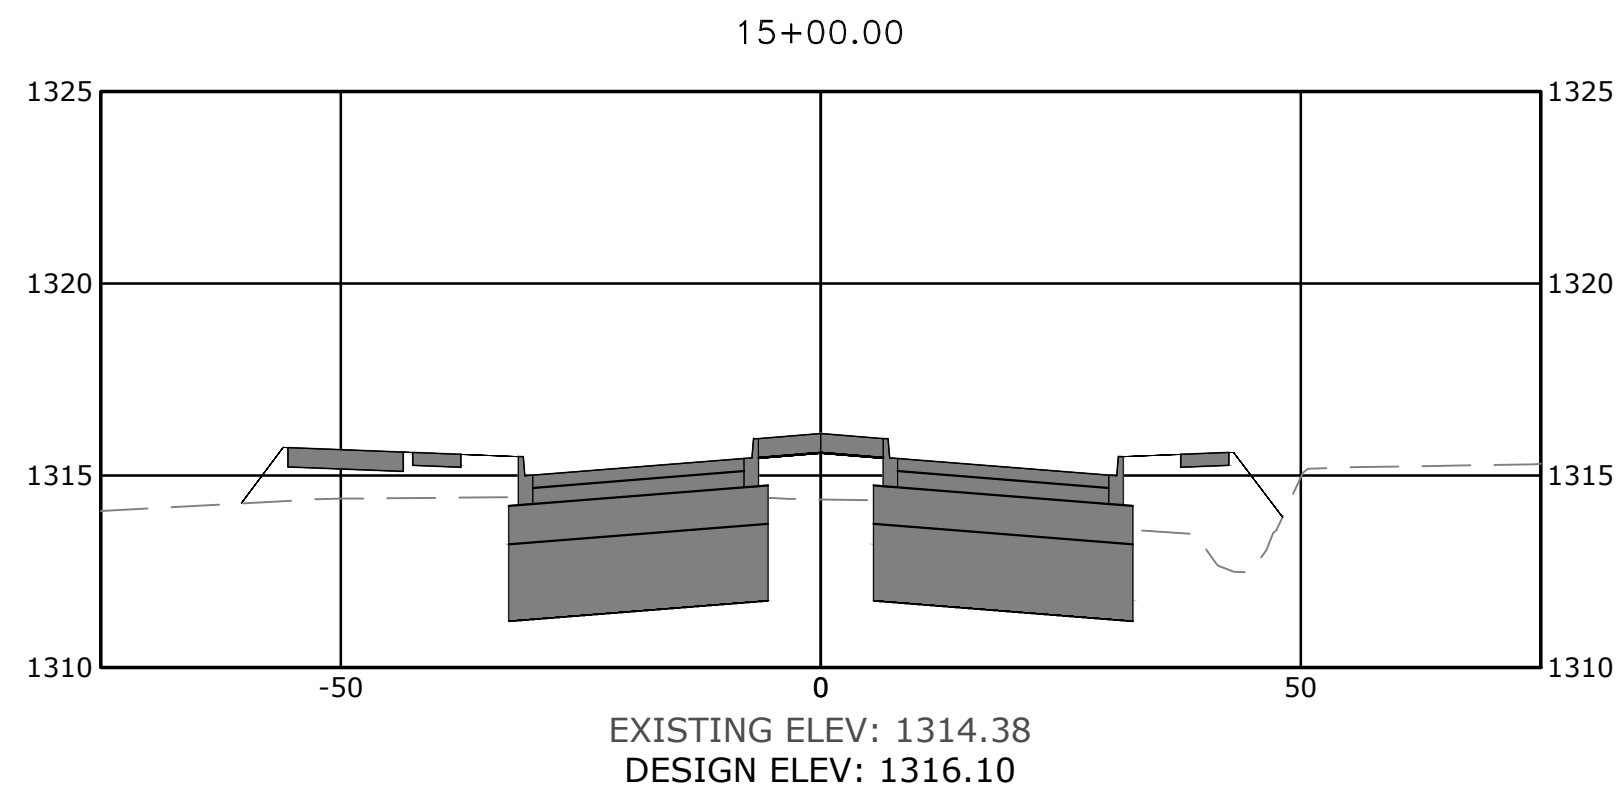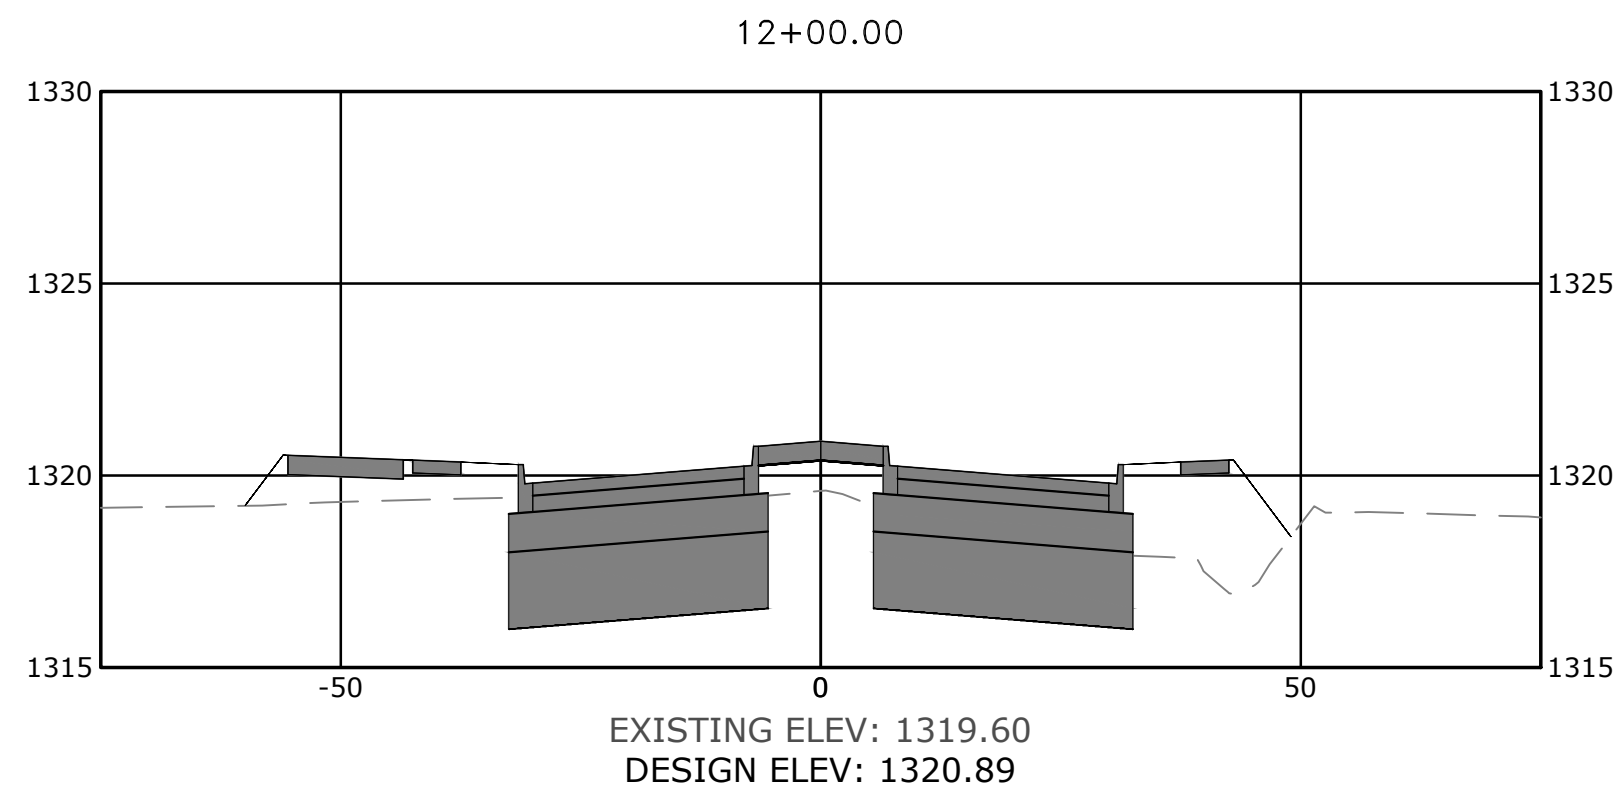

PRELIMINARY
NOT FOR
CONSTRUCTION

ORIGINAL SIGNATURE ON FILE

WATER TOWER RD. PH.3
SE. 6TH ST. TO BATTLEFIELD BLVD.
BENTONVILLE, AR











REV/ISIONS		DESCRIPTION
REV	DATE	

CROSS
SECTIONS
WATER TOWER
RD.- STA.
11+00 TO STA.
15+00

DESIGNED BY: ELA	DRAWN BY : WAS
DATE: 1/31/2022	REVISION: 30%
SCALE: NTS	JOB NUMBER: 21-2147

W:\2021\21-2147 - Water Tower Road Phase III. 8th St. To E. Battlfield Blvd\Design Drawings\Sheets\21-2147- Cross Sections.dwg, PRINTED ON: January 31, 2022 @ 12:26 PM

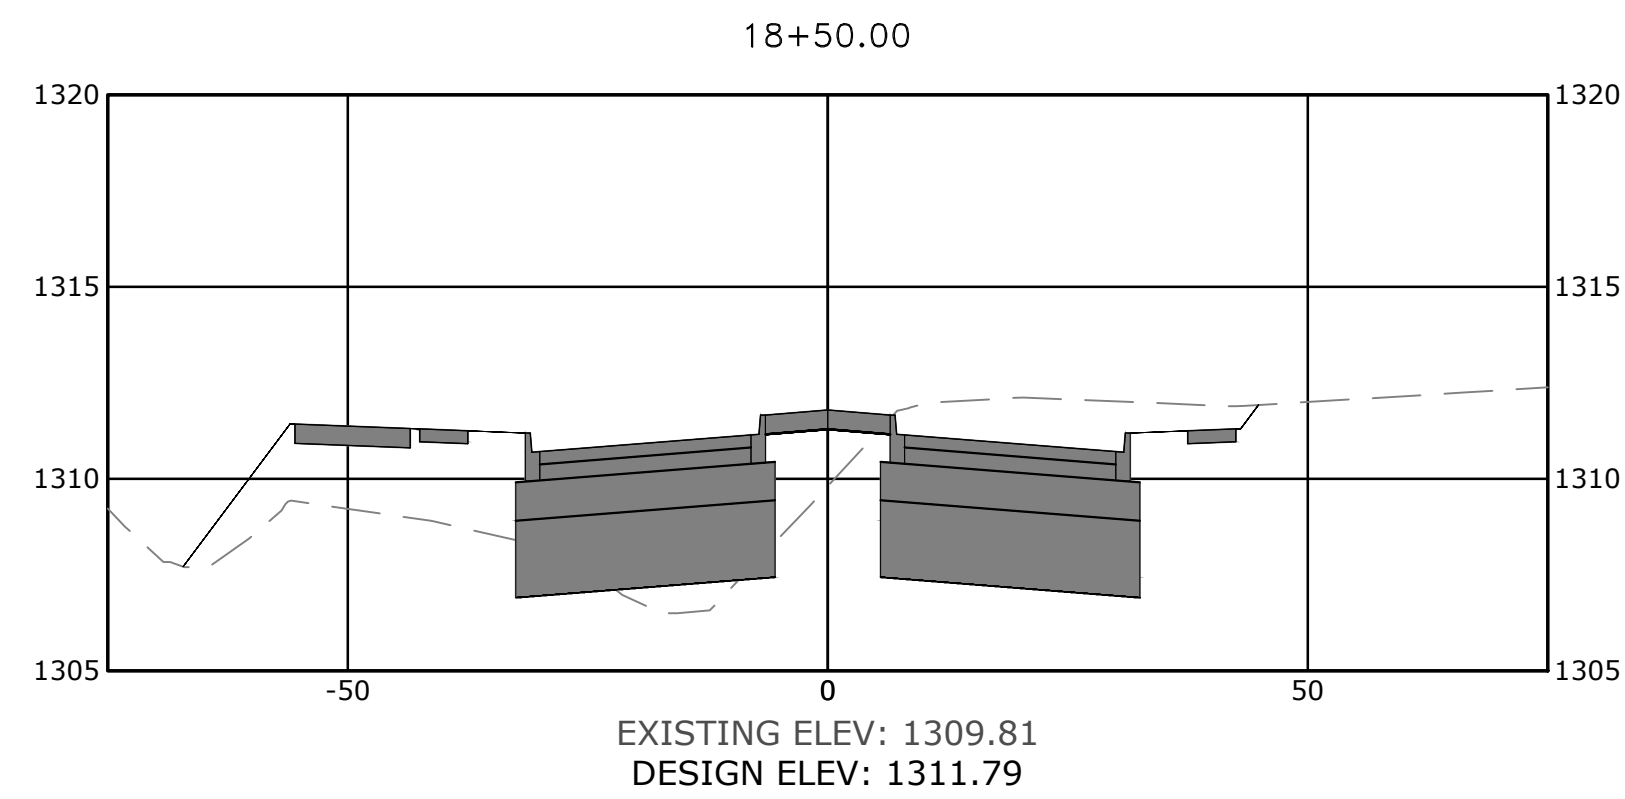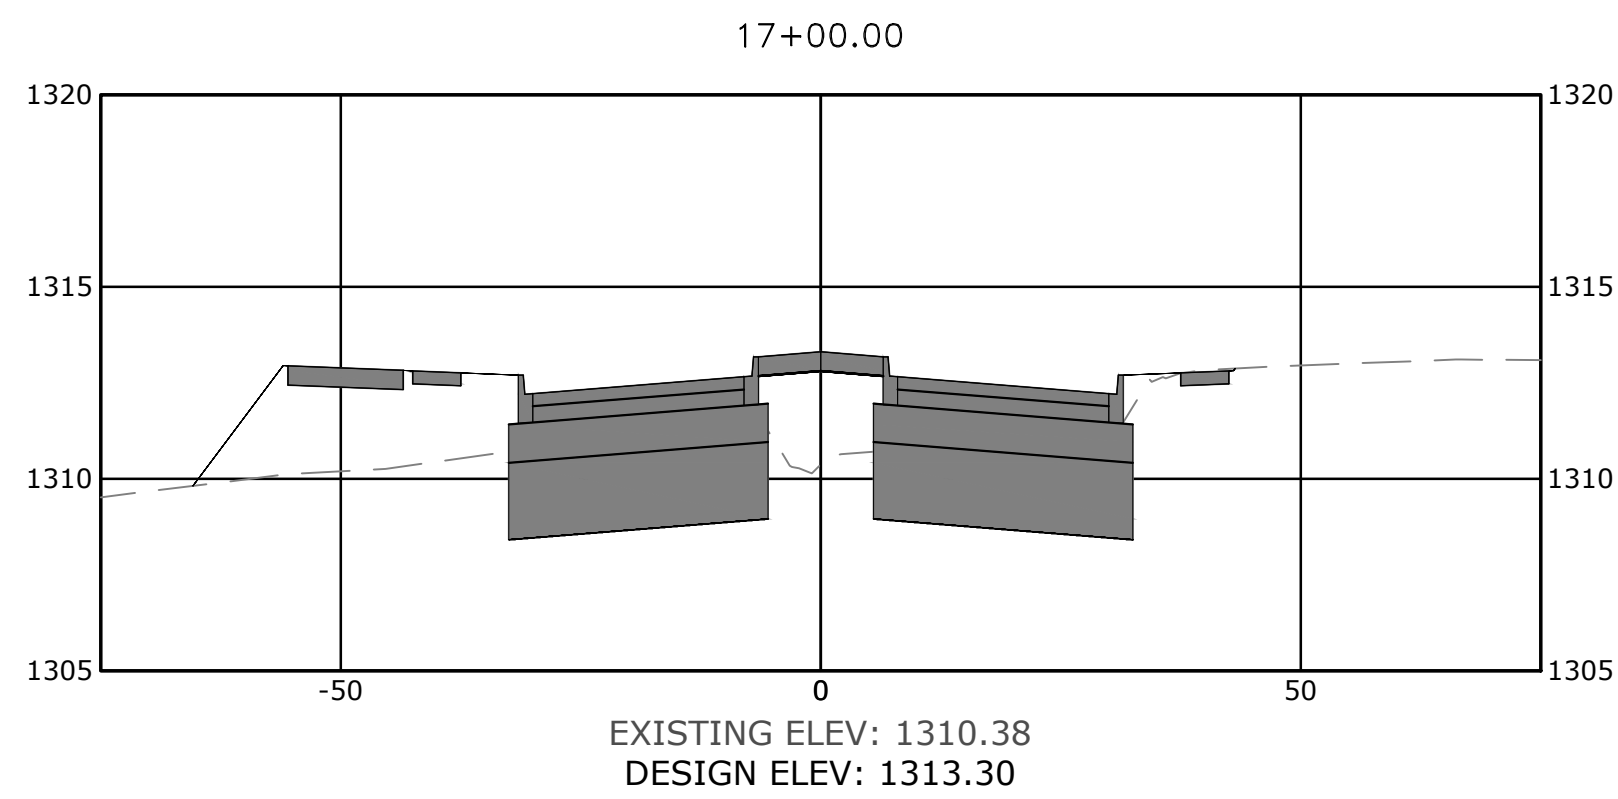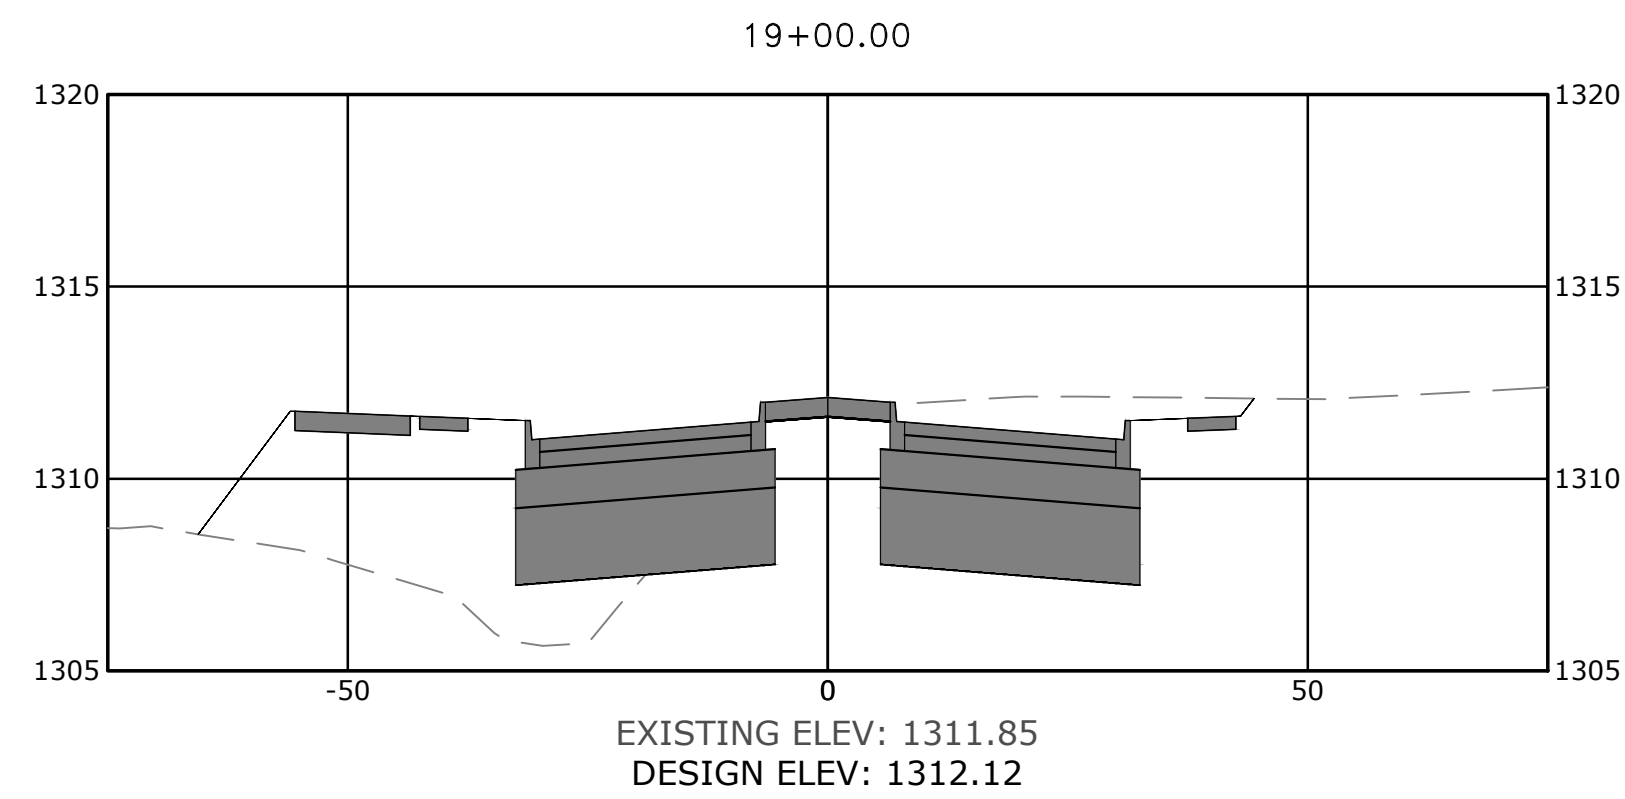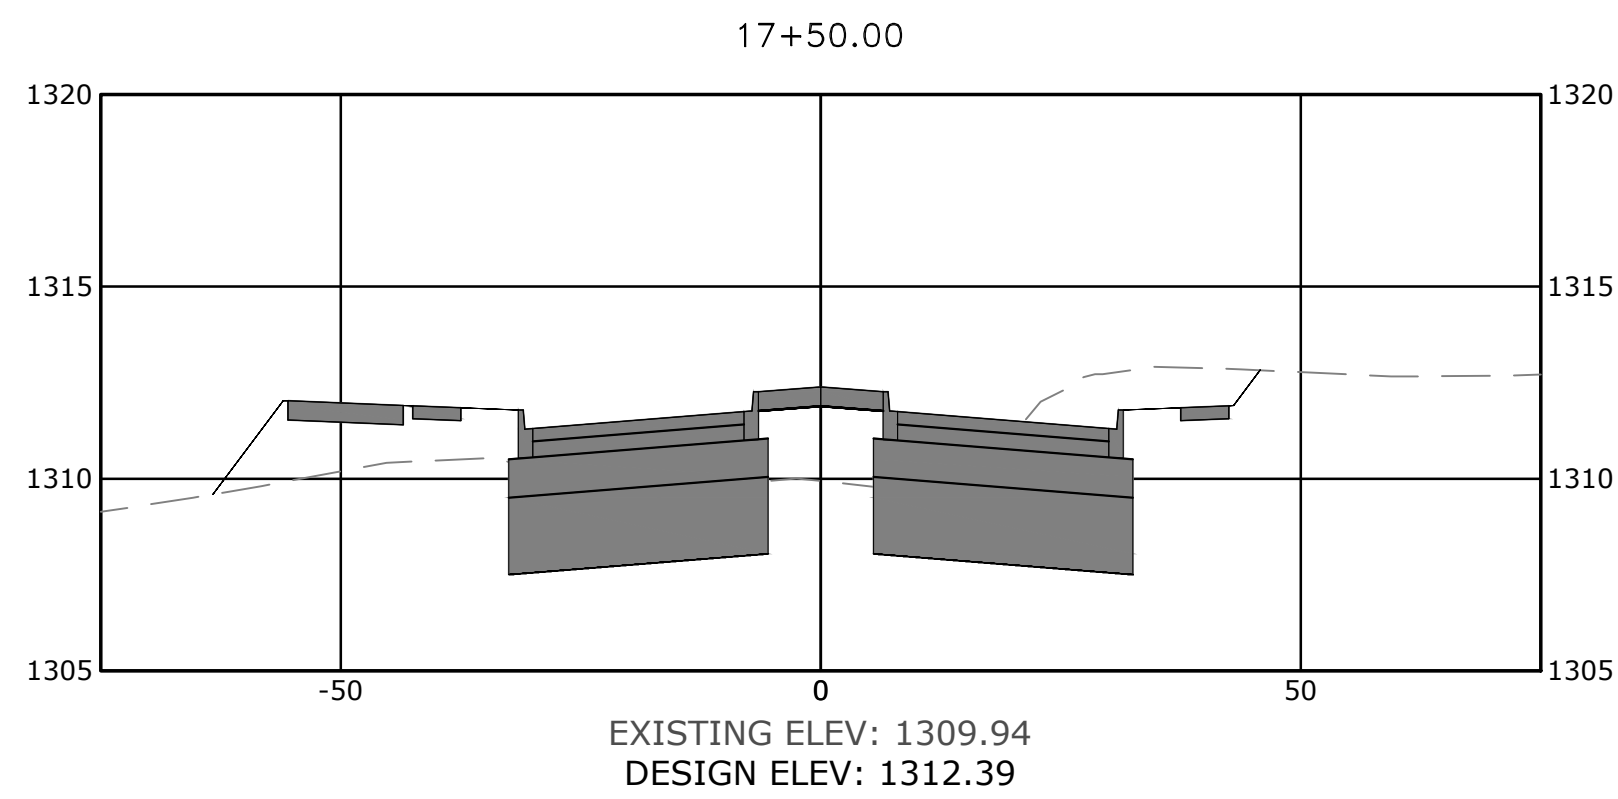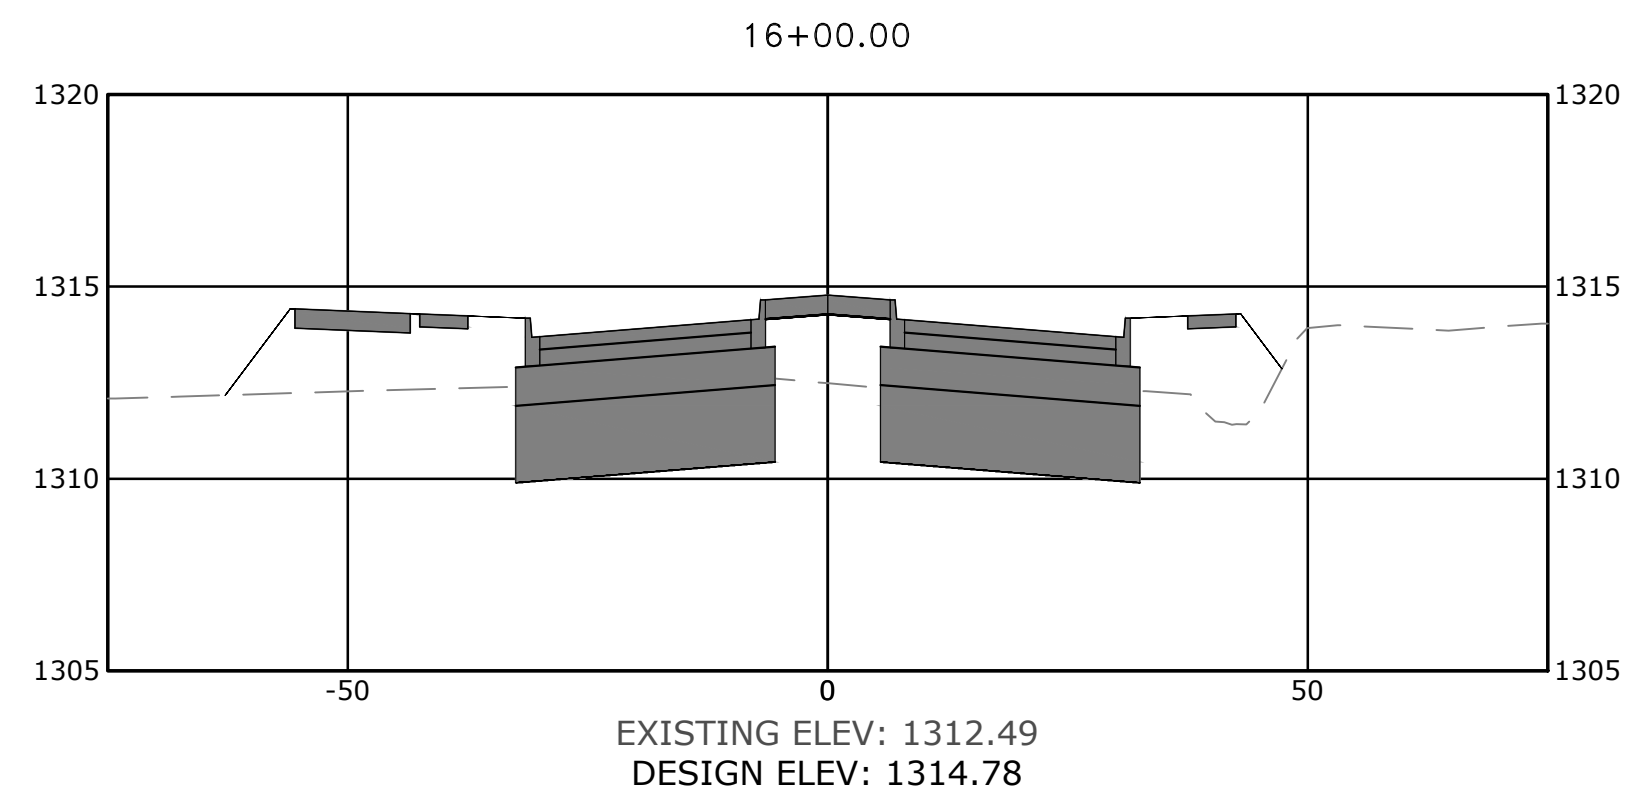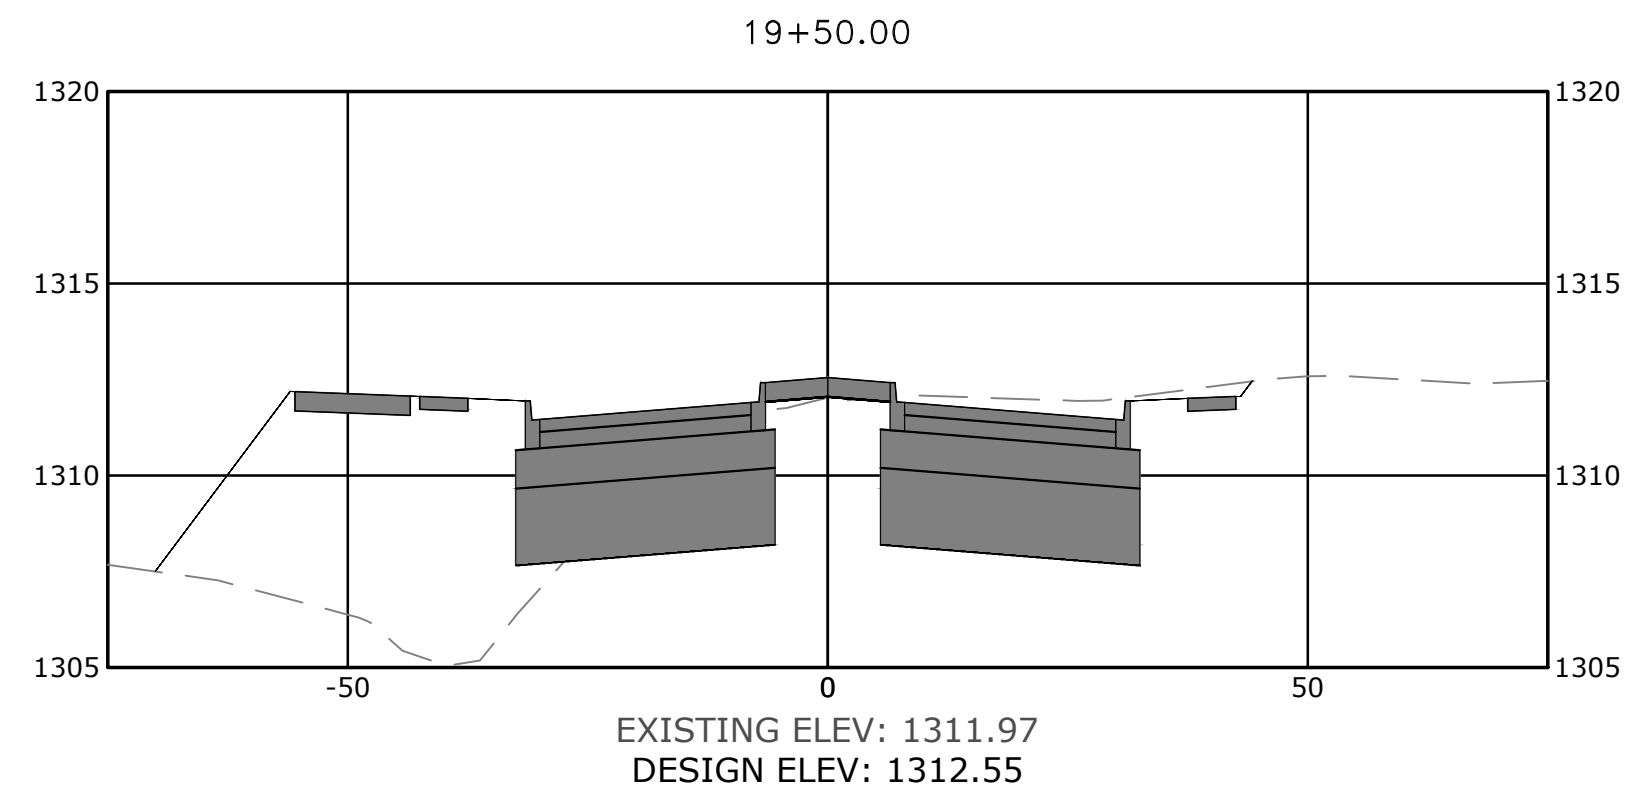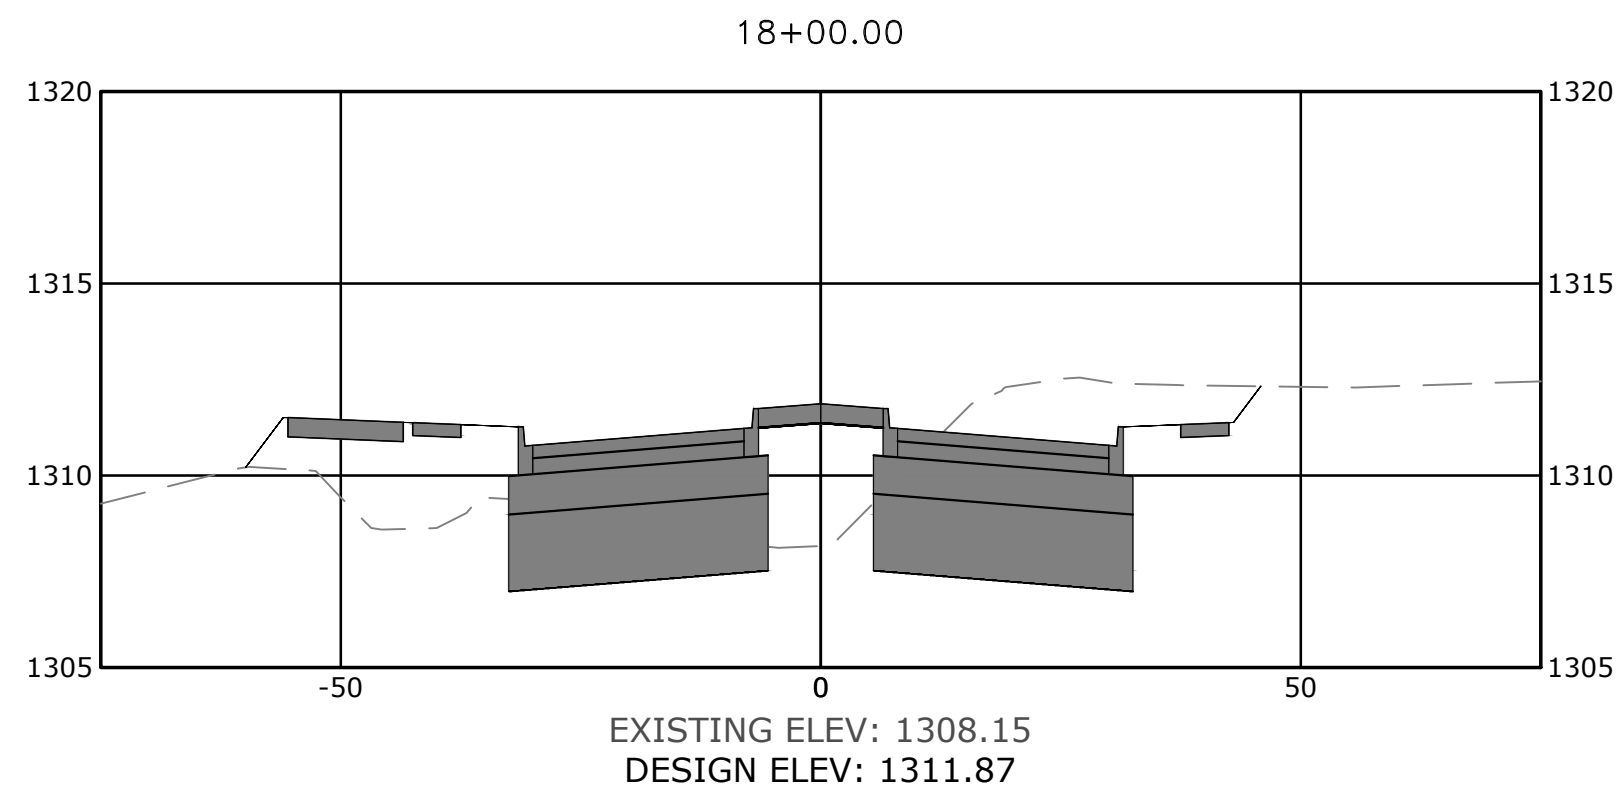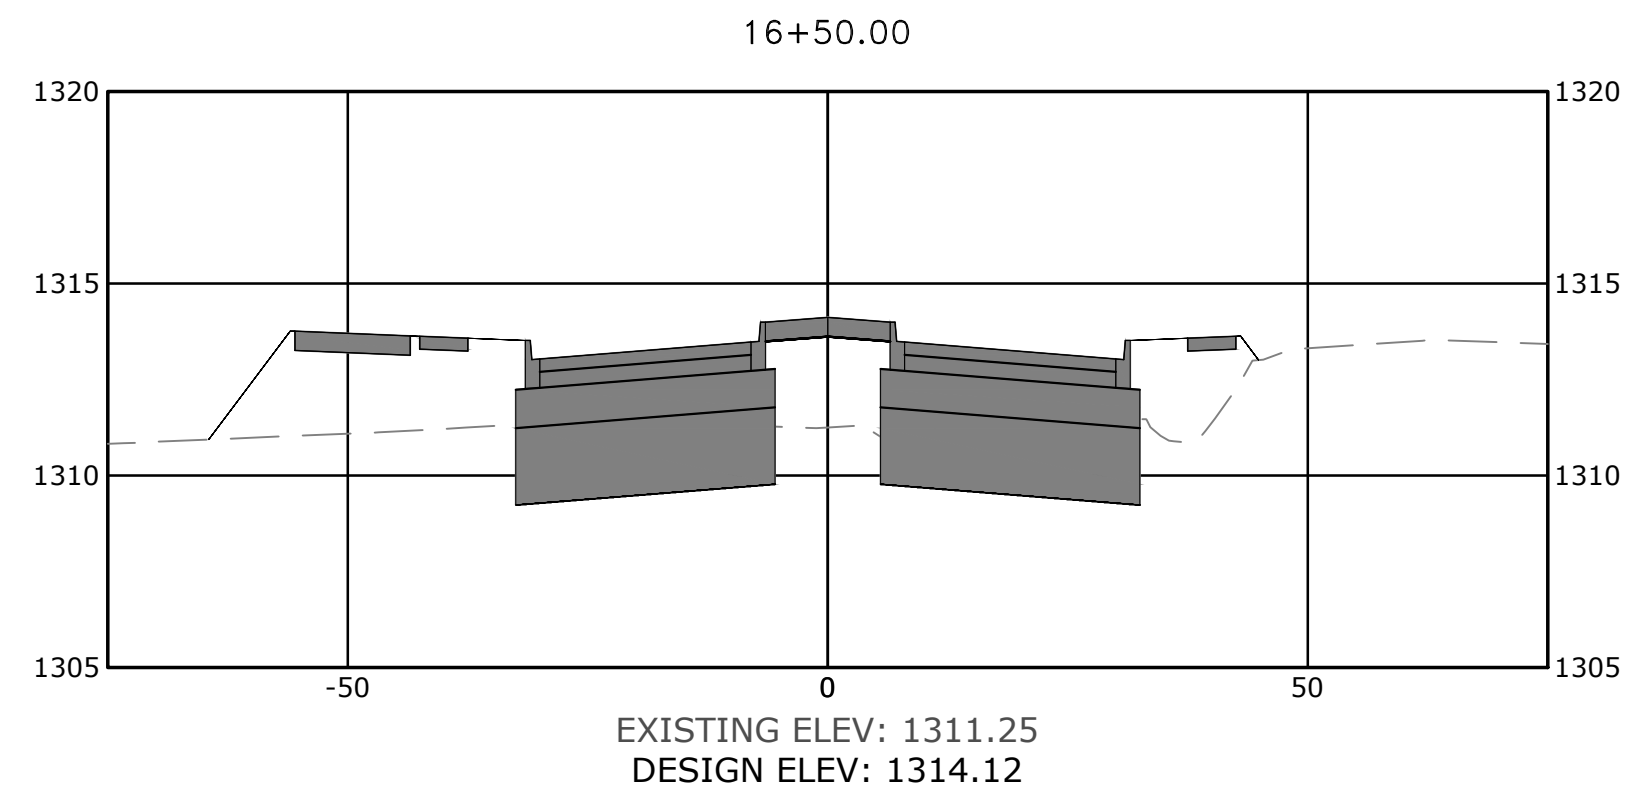

PRELIMINARY
NOT FOR
CONSTRUCTION

ORIGINAL SIGNATURE ON FILE

WATER TOWER RD. PH.3
SE. 6TH ST. TO BATTLEFIELD BLVD.
BENTONVILLE, AR







REV	DATE	DESCRIPTION

CROSS
SECTIONS
WATER TOWER
RD.- STA.
15+50 TO STA.
19+50




DESIGNED BY: ELA	DRAWN BY : WAS
DATE: 1/31/2022	REVISION: 30%
SCALE: NTS	JOB NUMBER: 21-2147

XS-5

W:\2021\21-2147 - Water Tower Road Phase III. 8th St. To E. Battlfield Blvd\Design Drawings\Sheets\21-2147- Cross Sections.dwg, PRINTED ON: January 31, 2022 @ 12:26 PM

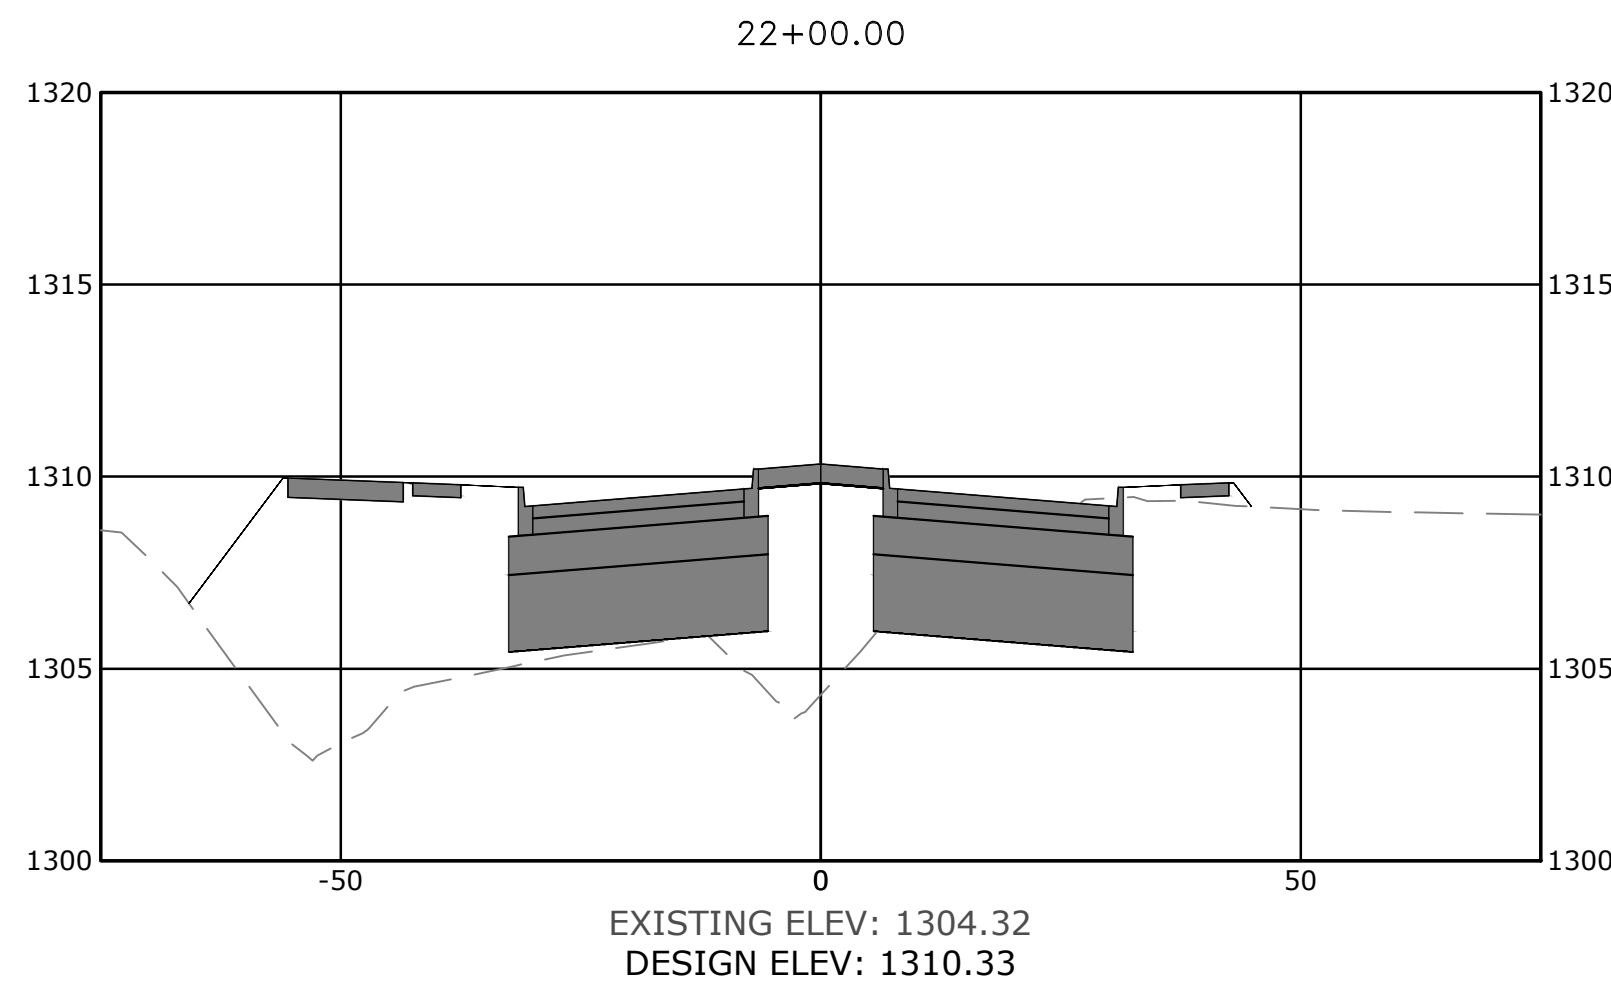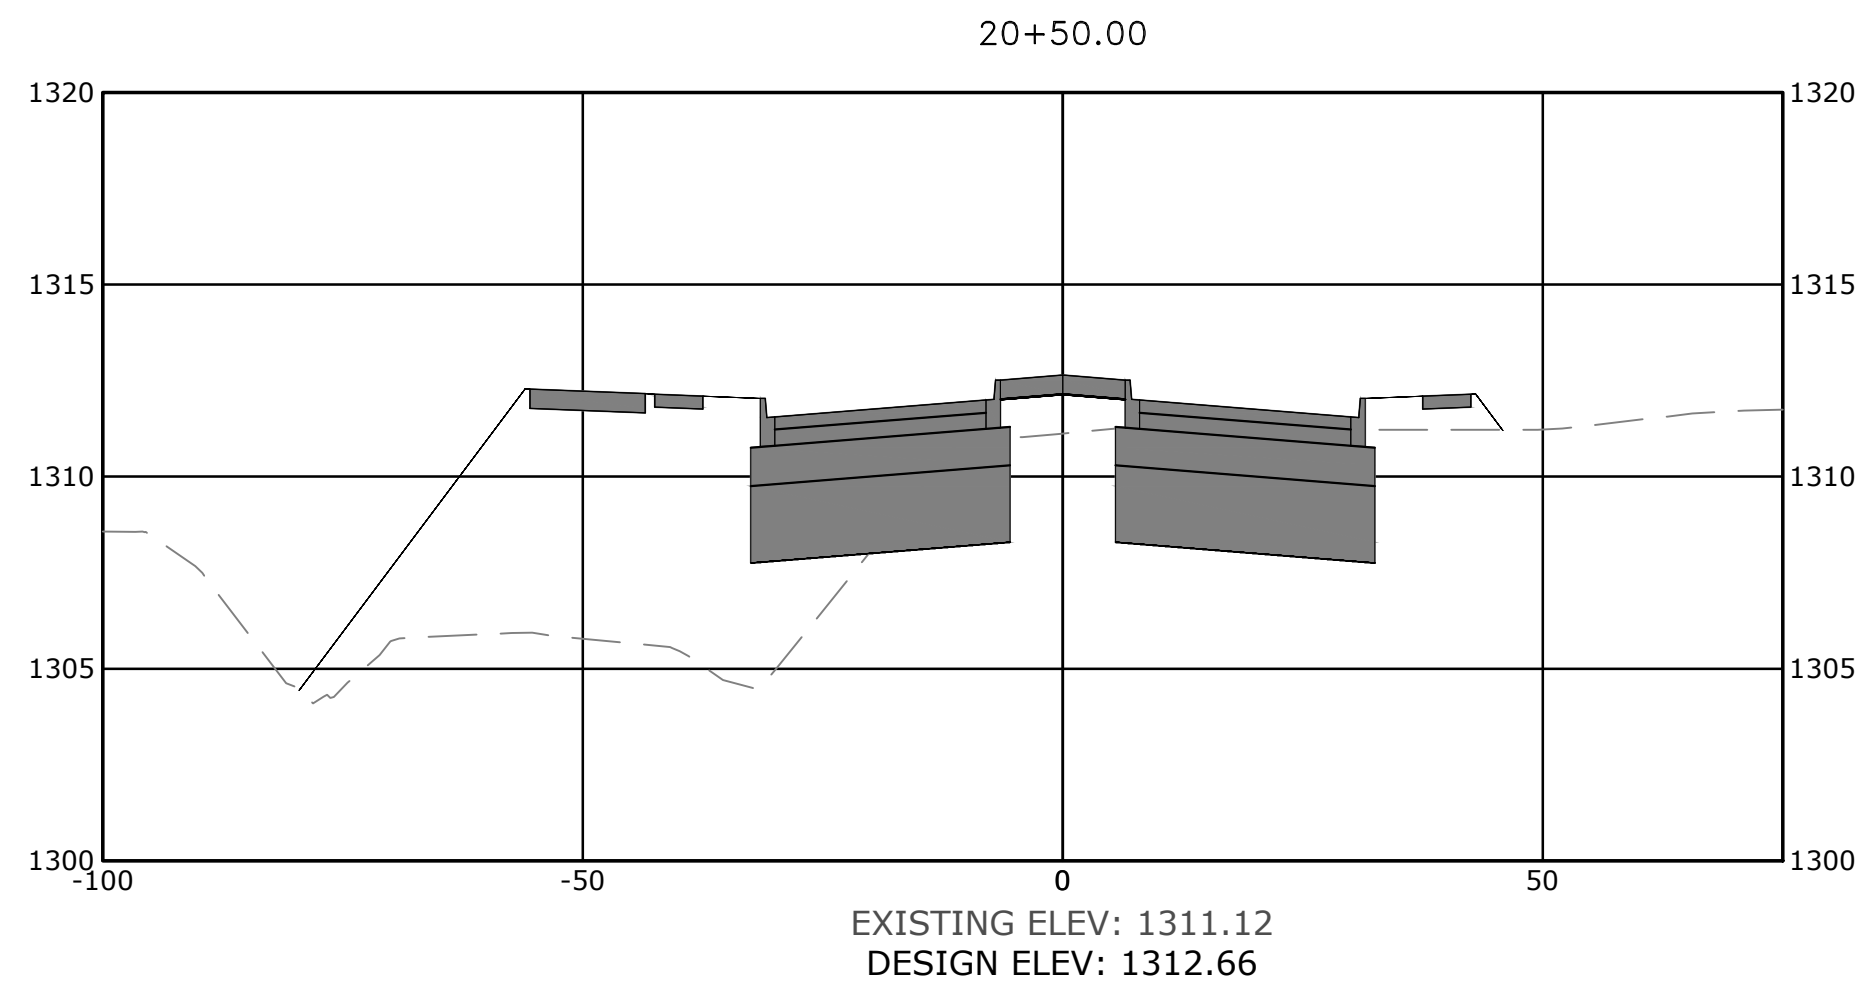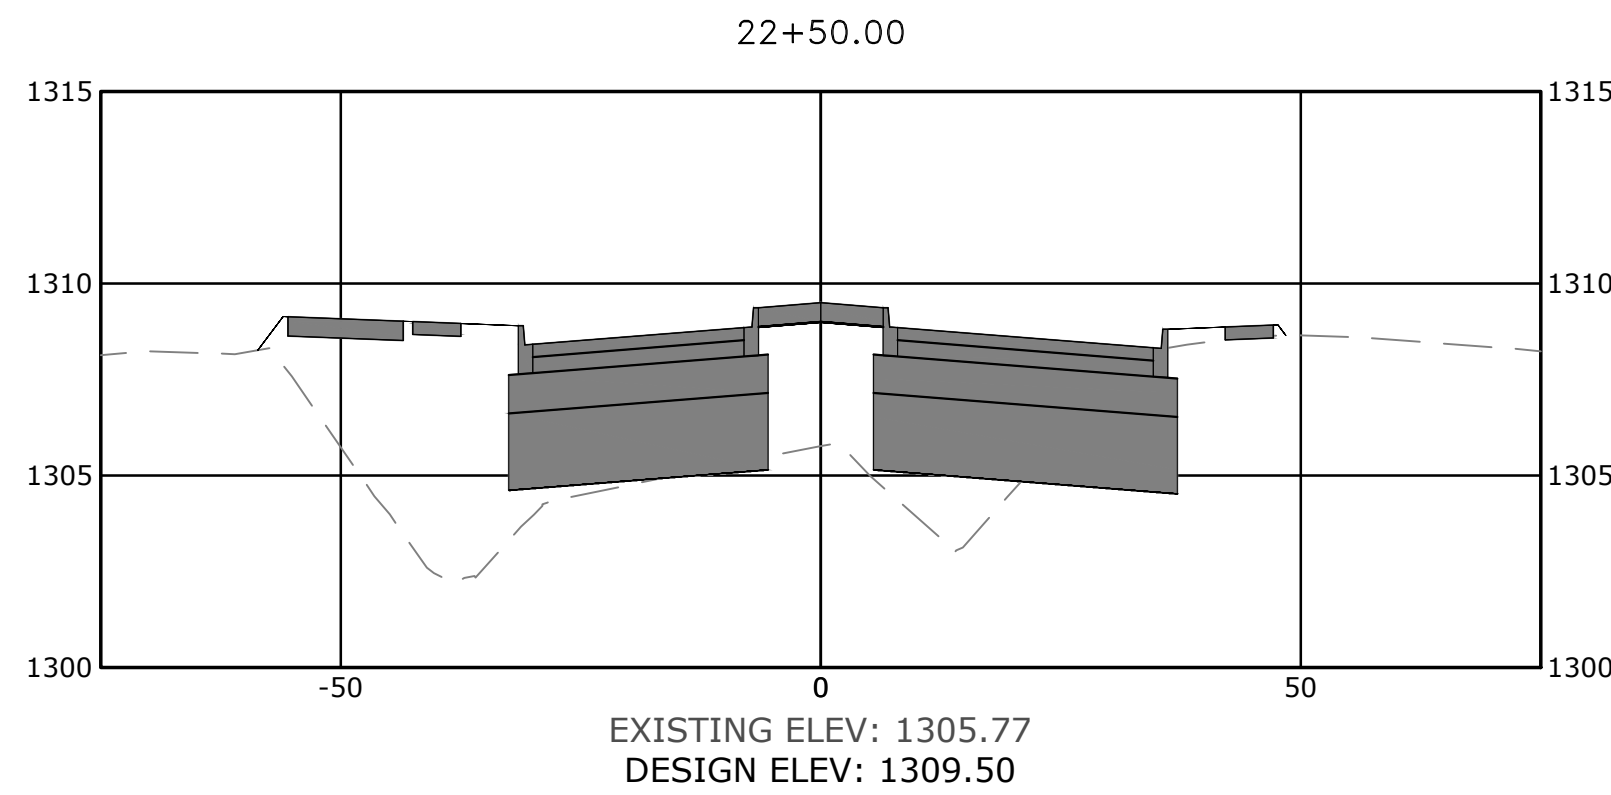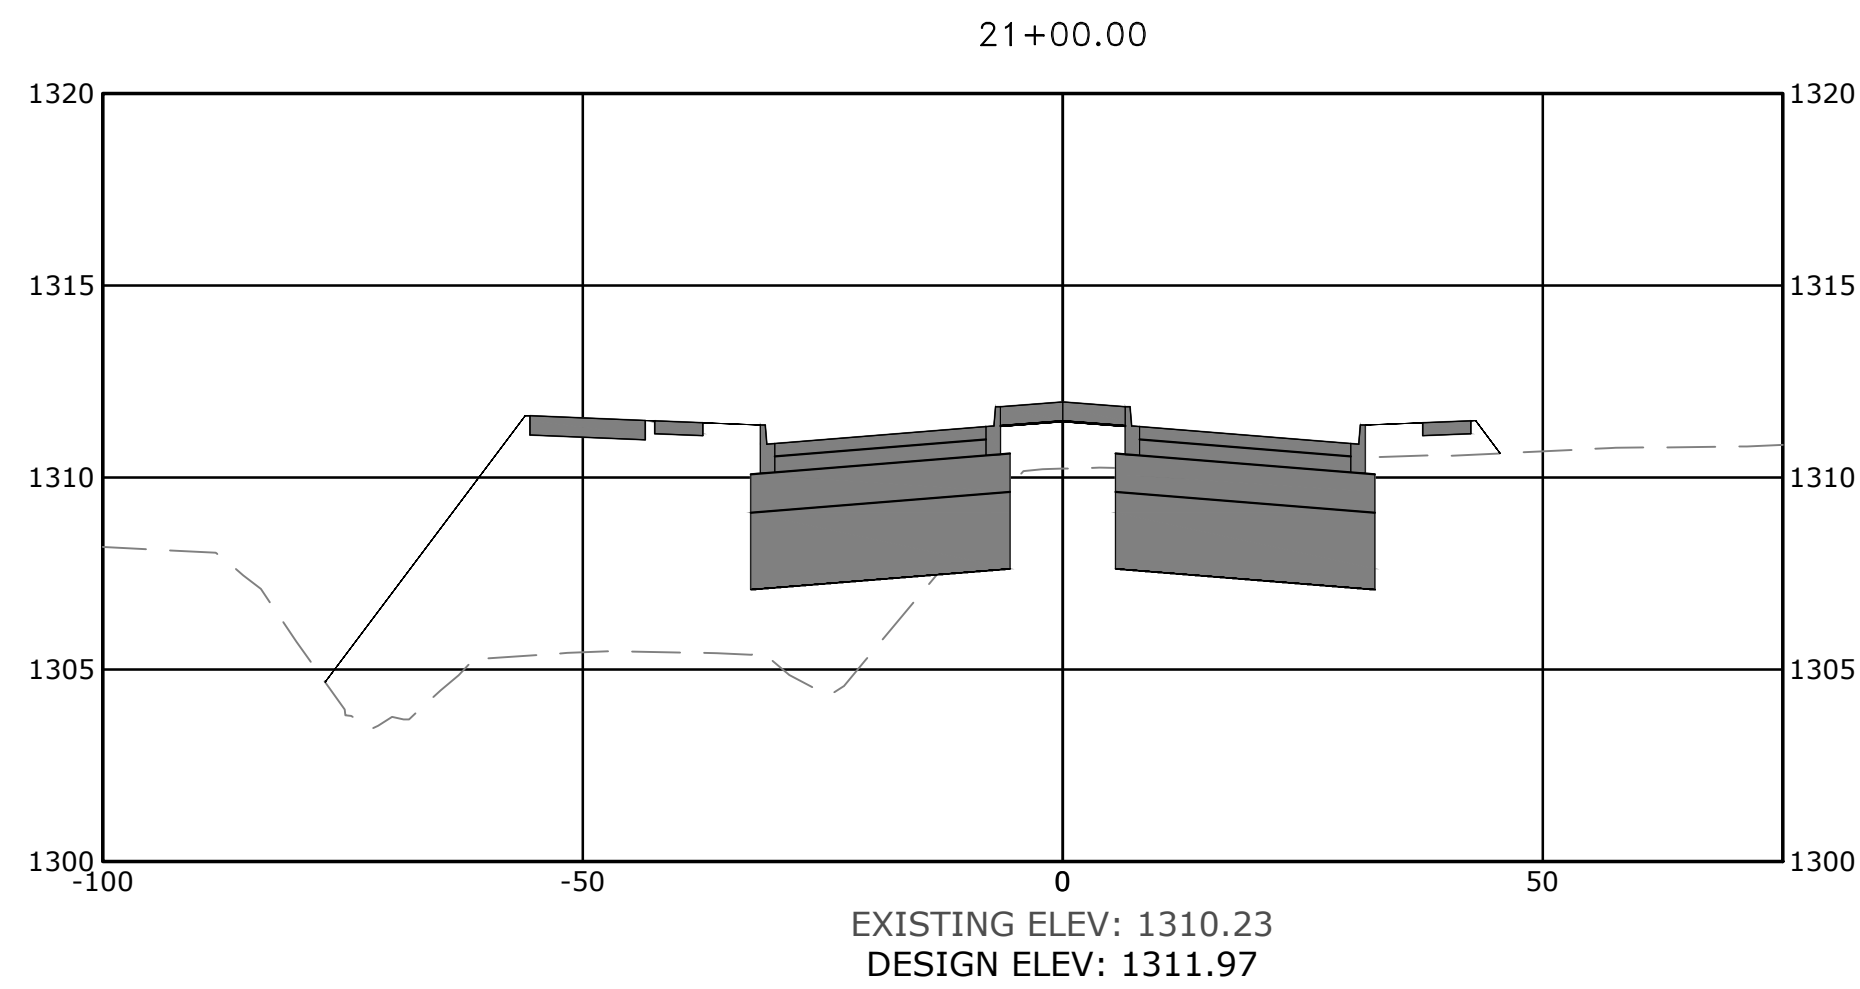


SEE SHEET PP-6 FOR DESIGN OF ROUNDABOUT FROM STA. 23+00 TO STA. 27+08. SEE SHEETS PP-9 AND PP-10 FOR DESIGN OF ROUNDABOUT FROM STA. 100+00 TO STA. 106+73. GRADING OF ROUNDABOUT SHALL BE COMPLETED AS PART OF 60% SUBMITTAL PLAN SET.

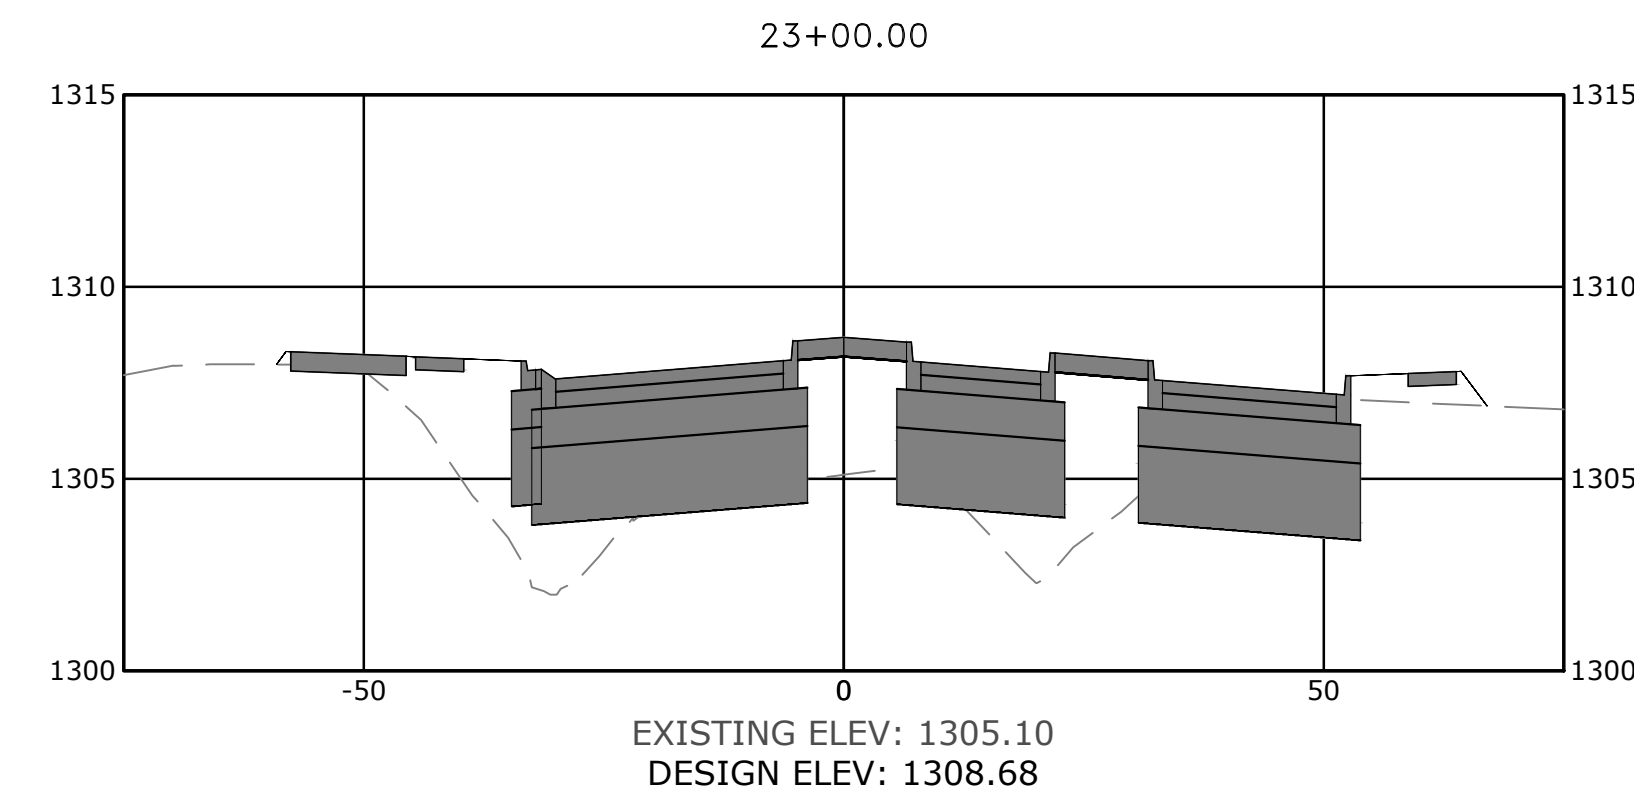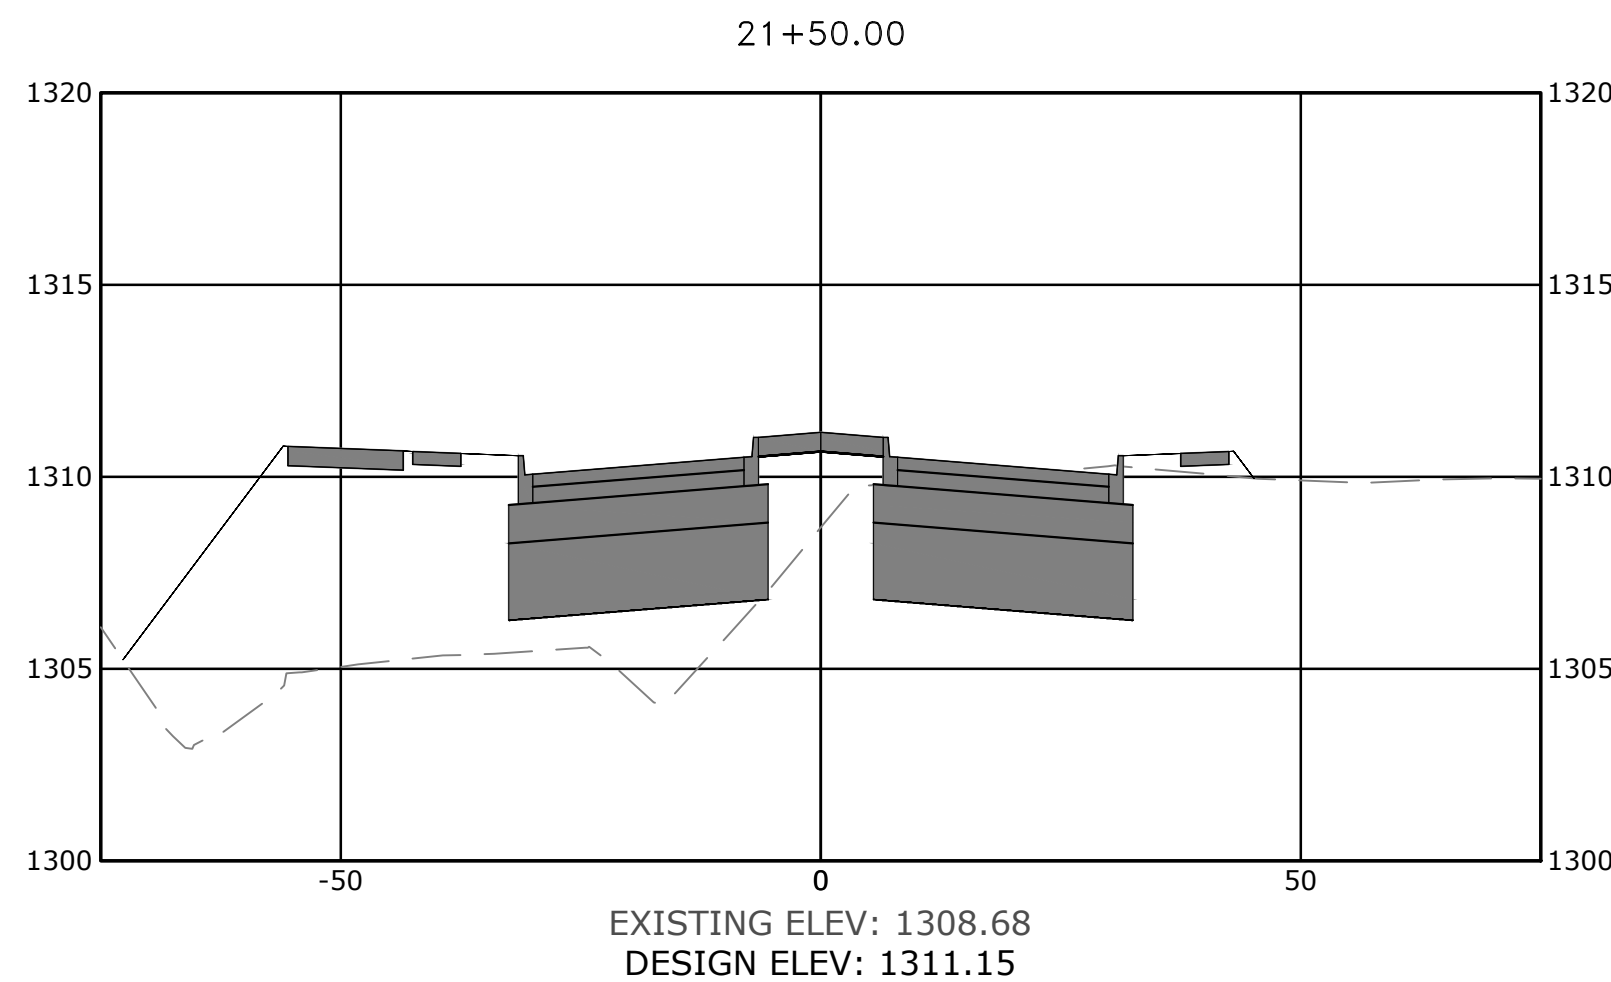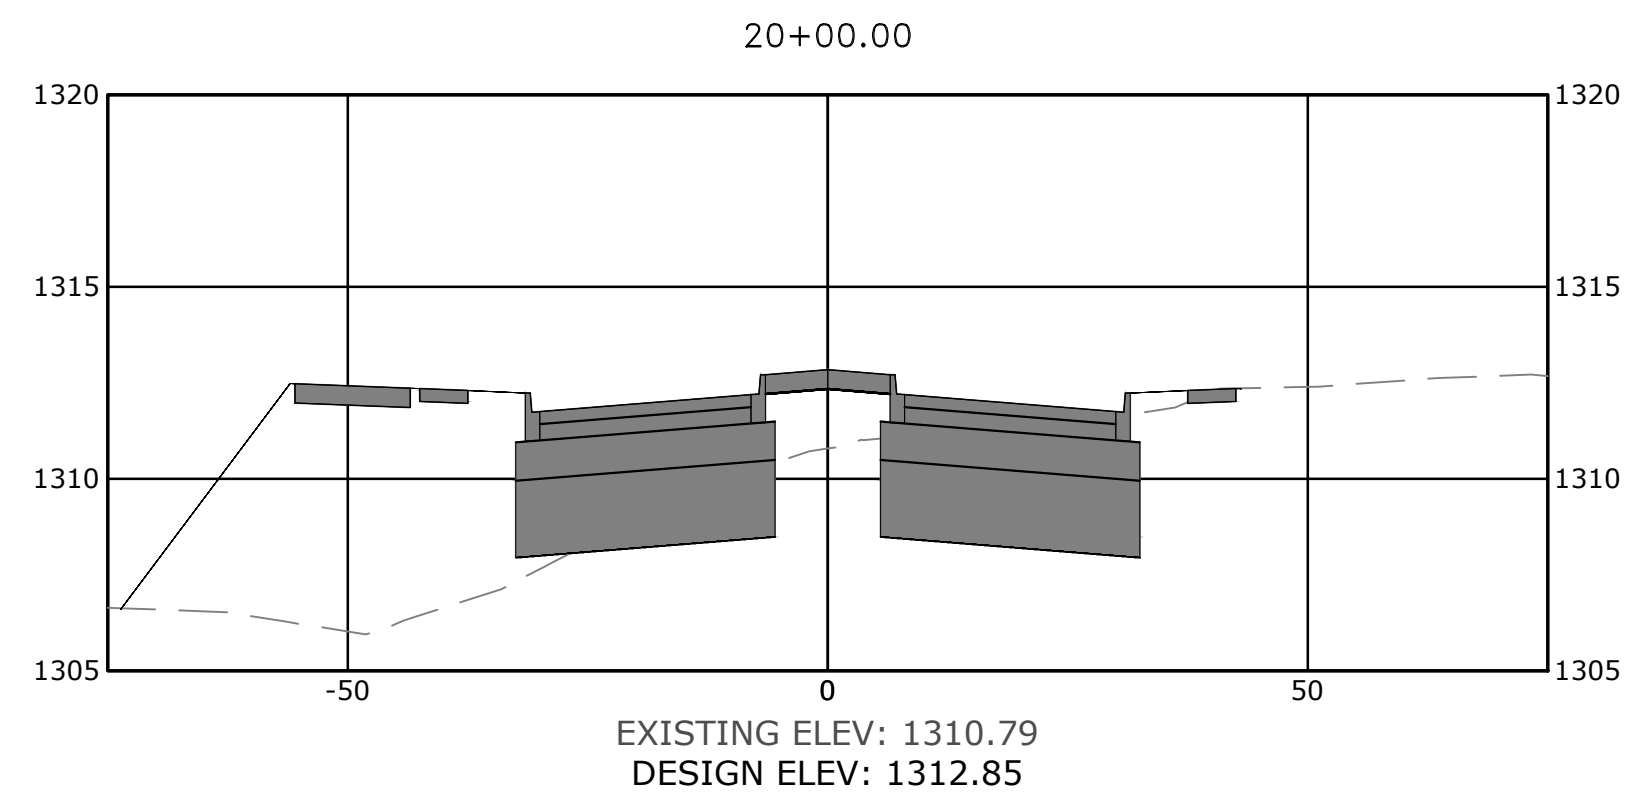

PRELIMINARY
NOT FOR
CONSTRUCTION

ORIGINAL SIGNATURE ON FILE

WATER TOWER RD. PH.3
SE. 6TH ST. TO BATTLEFIELD BLVD.
BENTONVILLE, AR

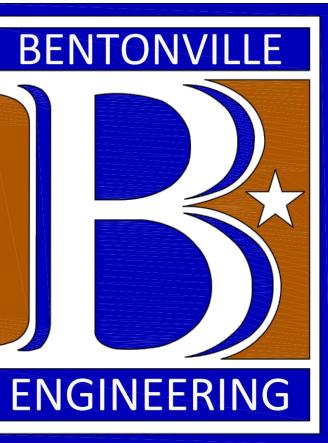


REV		DATE	DESCRIPTION

CROSS
SECTIONS
WATER TOWER
RD.- STA.
20+00 TO STA.
23+00


DESIGNED BY: ELA	DRAWN BY : WAS
DATE: 1/31/2022	REVISION: 30%
SCALE: NTS	JOB NUMBER: 21-2147

XS-6

W:\2021\21-2147 - Water Tower Road Phase III. 8th St. To E. Battfield Blvd\Design Drawings\Sheets\21-2147- Pavement Marking & Signage.dwg, PRINTED ON: January 31, 2022 @ 2:59 PM

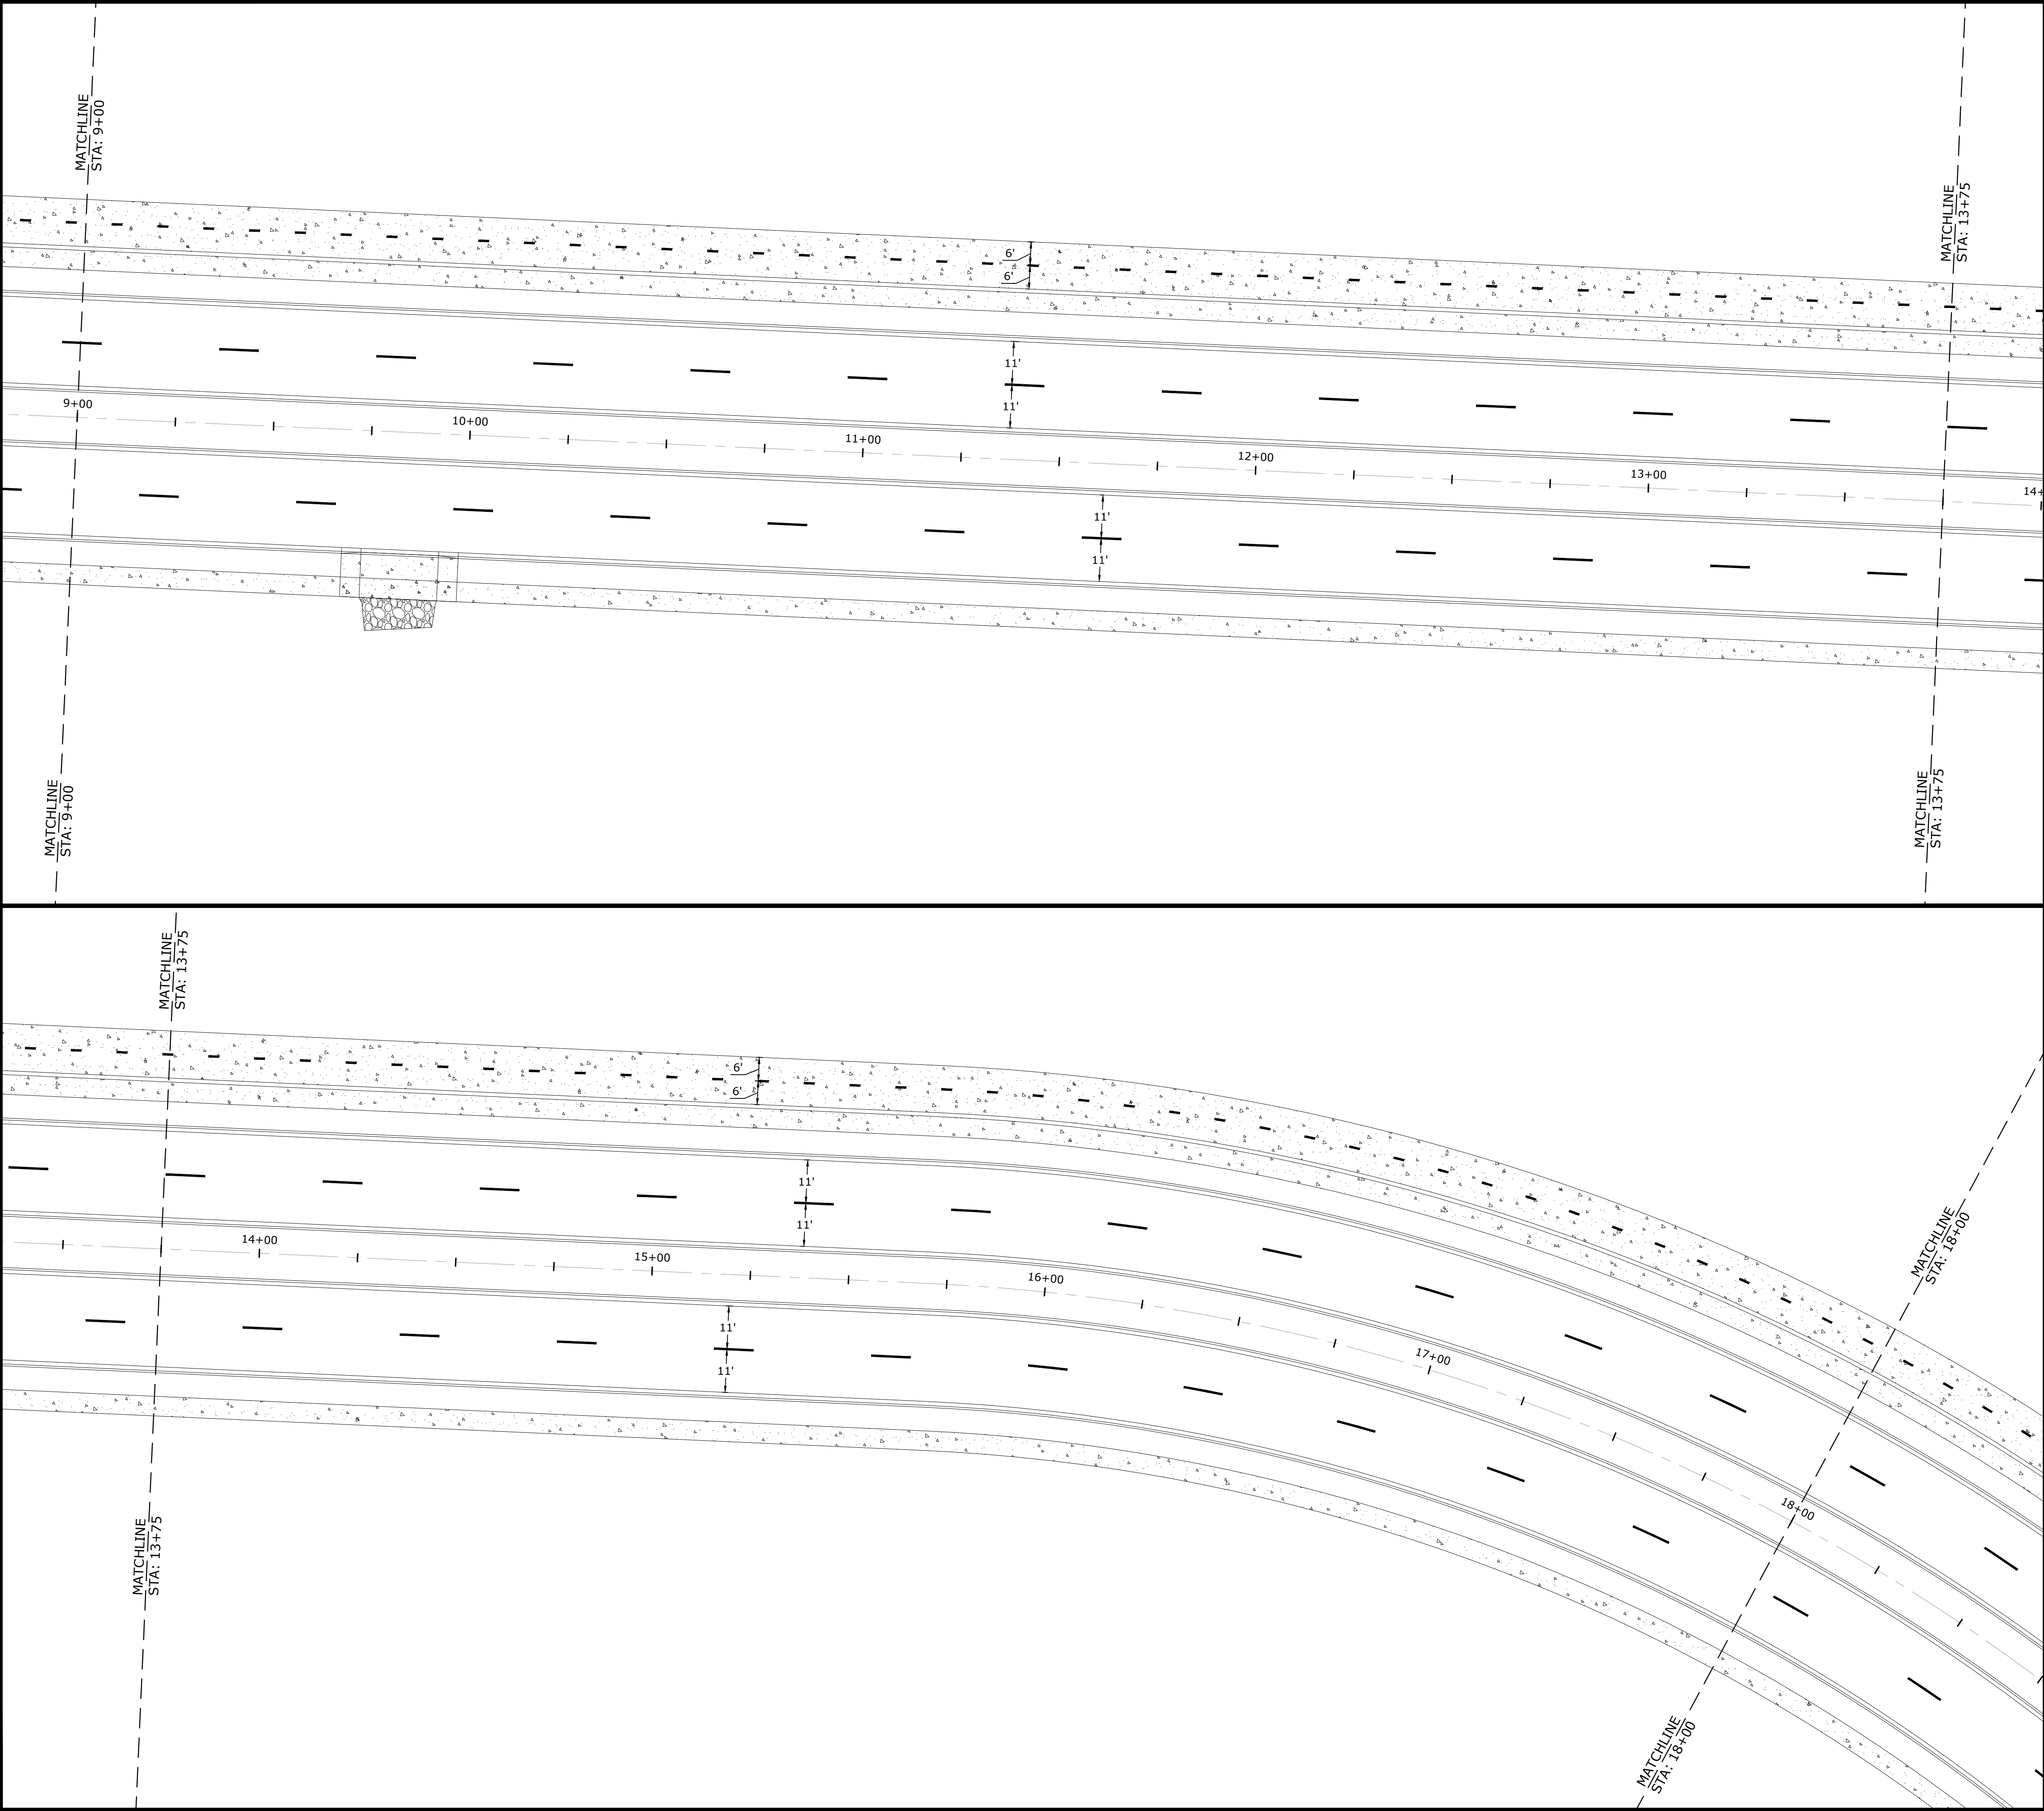

PROPOSED LEGEND

 

CURB AND GUTTER

PAVEMENT MARKING SYMBOL (AS INDICATED)

SOLID STRIPING

SKIP STRIPING

CROSSWALK STRIPING

PROPOSED CENTERLINE


YIELD LINE, WHITE THERMOPLASTIC

DASHED ENTRY STRIPING

DASHED EXIT STRIPING


PLAN SCALE

(IN FEET)
1 inch = 20ft.

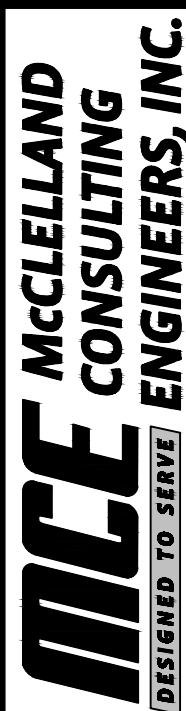

DESIGNED TO SERVE
MCE McClelland
CONSULTING
ENGINEERS, INC.
1580 E. STEARNS ST.
FAYETTEVILLE, ARKANSAS 72703
(479) 443-2377
HTTP://WWW.MCE.US.COM

PRELIMINARY
NOT FOR
CONSTRUCTION

ORIGINAL SIGNATURE ON FILE

WATER TOWER RD. PH. 3
SE. 6TH ST. TO BATTLEFIELD BLVD.
BENTONVILLE, AR



Know what's below.
Call before you dig.

REVISIONS		DESCRIPTION	
REV	DATE	DESCRIPTION	


PAVEMENT
MARKING AND
SIGNAGE
PLAN- STA.
9+00 TO STA.
18+00

DESIGNED BY: ELA	DRAWN BY : WAS
DATE: 1/31/2022	REVISION: 30%
SCALE: 1" = 20'	JOB NUMBER: 21-2147


PM-2

©2022

W:\2021\21-2147 - Water Tower Road Phase III. 8th St. To E. Battiefeld Blvd\Design Drawings\Sheets\21-2147- Pavement Marking & Signage.dwg, PRINTED ON: January 31, 2022 @ 2:59 PM

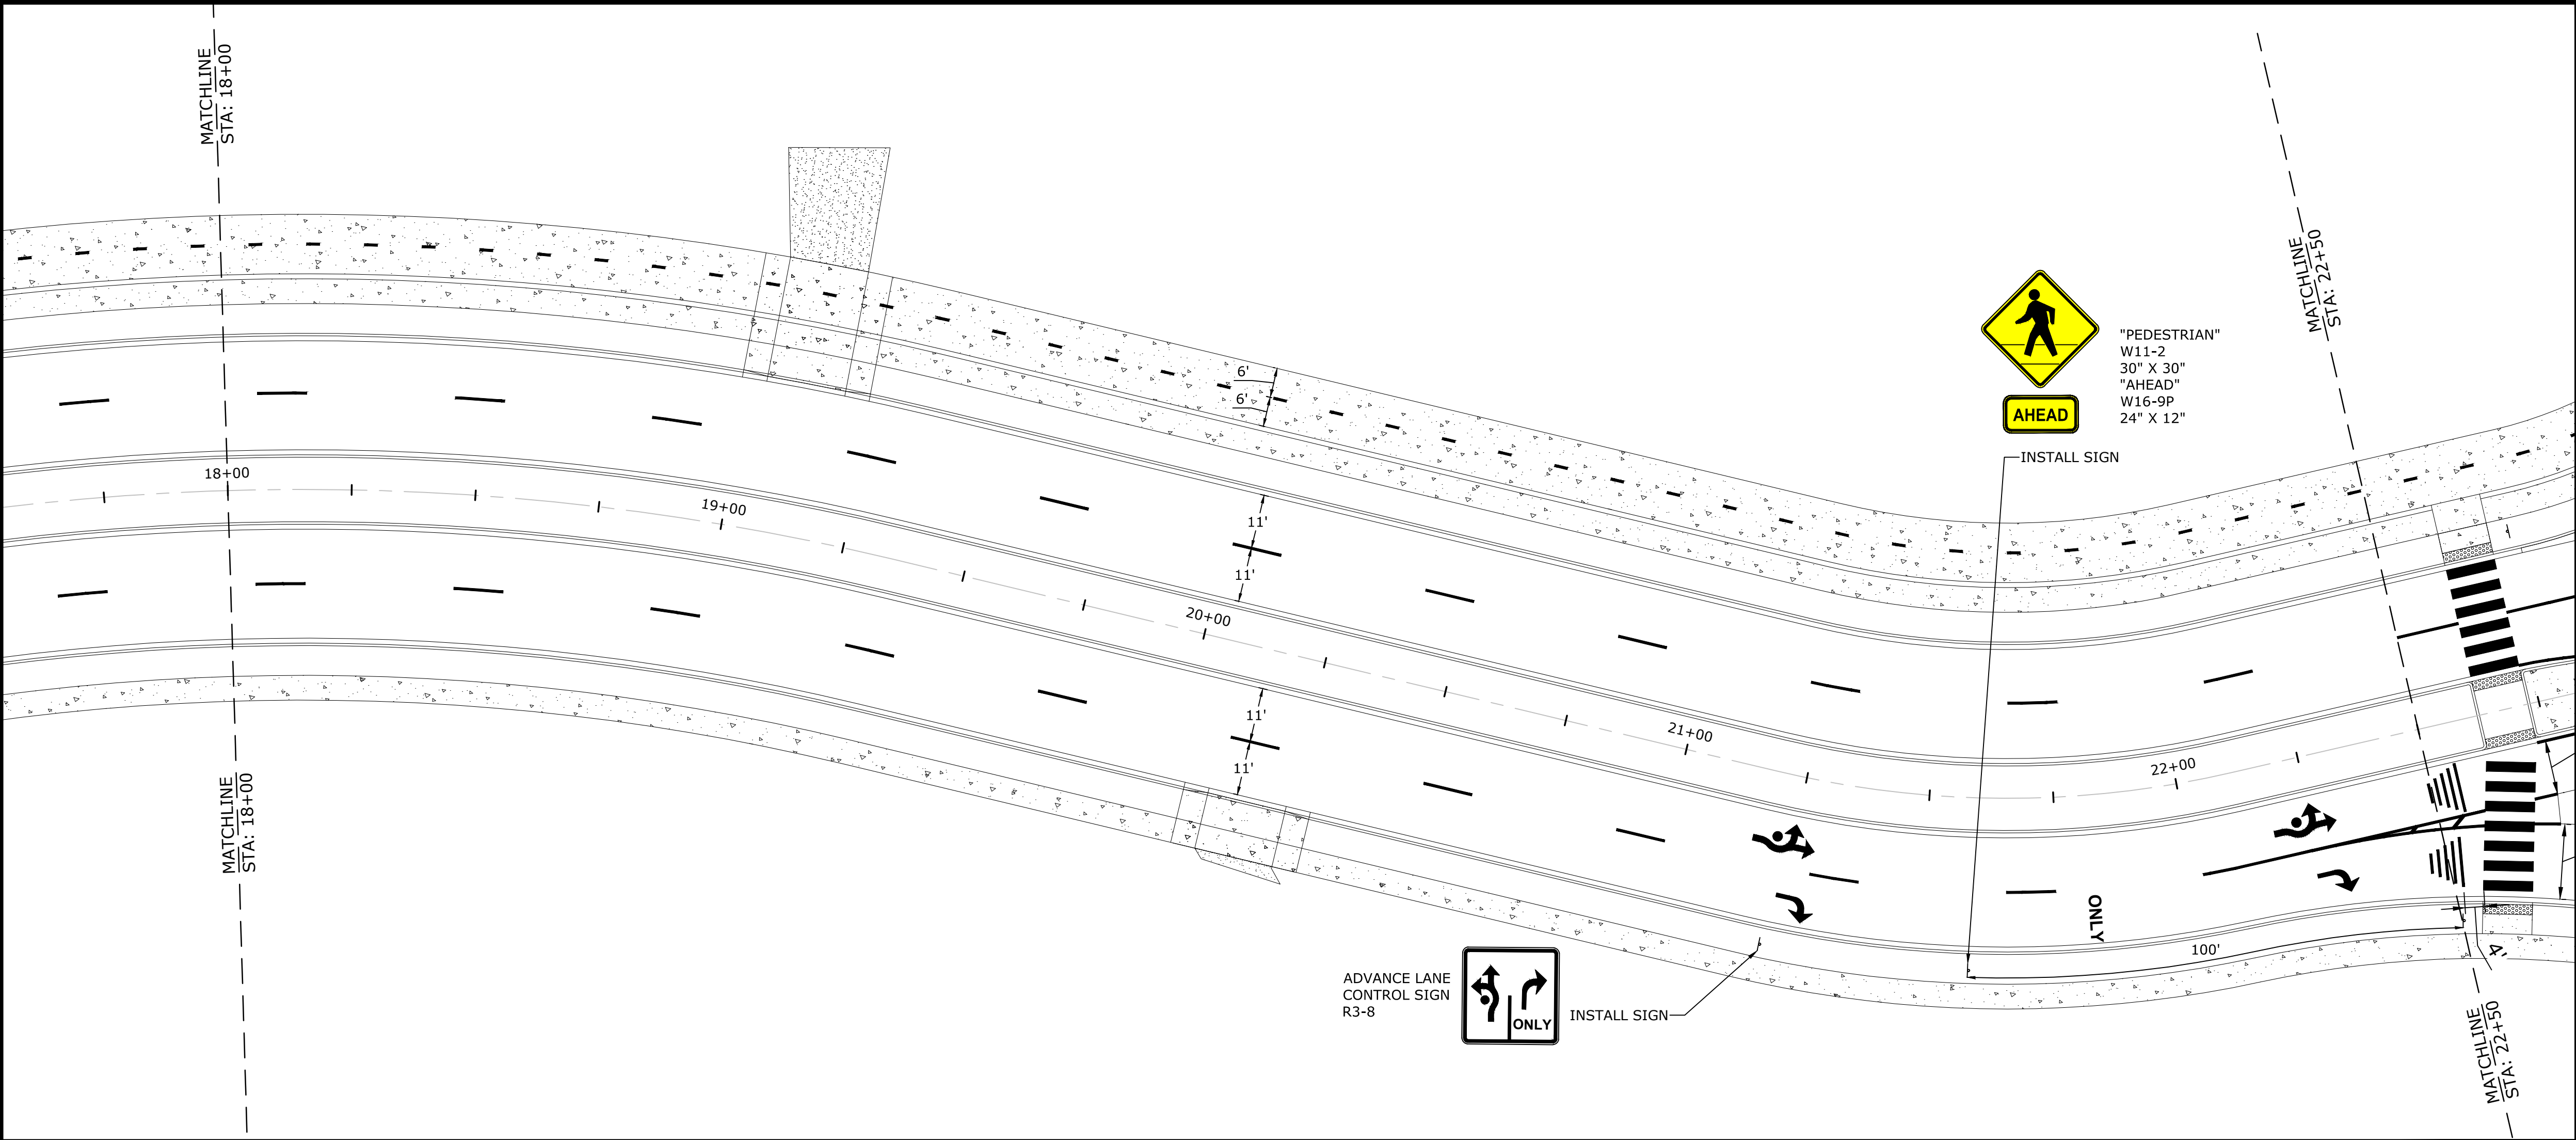

PROPOSED LEGEND	
	CURB AND GUTTER
	PAVEMENT MARKING SYMBOL (AS INDICATED)
	SOLID STRIPING
	SKIP STRIPING
	CROSSWALK STRIPING
	PROPOSED CENTERLINE
	YIELD LINE, WHITE THERMOPLASTIC
	DASHED ENTRY STRIPING
	DASHED EXIT STRIPING

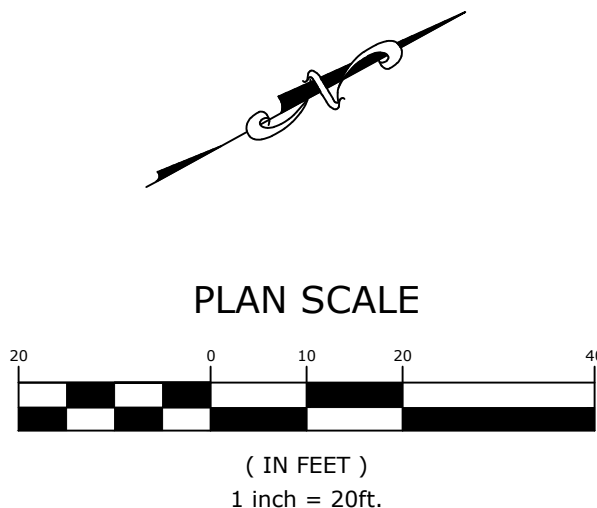

DESIGNED TO SERVE

1580 E. STEARNS ST.
FAYETTEVILLE, ARKANSAS 72703
(479) 443-2377
HTTP://WWW.MCE.US.COM

PRELIMINARY
NOT FOR
CONSTRUCTION

ORIGINAL SIGNATURE ON FILE

WATER TOWER RD. PH.3
SE. 6TH ST. TO BATTLEFIELD BLVD.
BENTONVILLE, AR


Know what's below.
Call before you dig.

REVISIONS	
REV	DESCRIPTION

PAVEMENT MARKING AND SIGNAGE
PLAN- STA.
18+00 TO STA.
22+50

DESIGNED BY: ELA	DRAWN BY : WAS
DATE: 1/31/2022	REVISION: 30%
SCALE: 1" = 20'	JOB NUMBER: 21-2147


PM-3

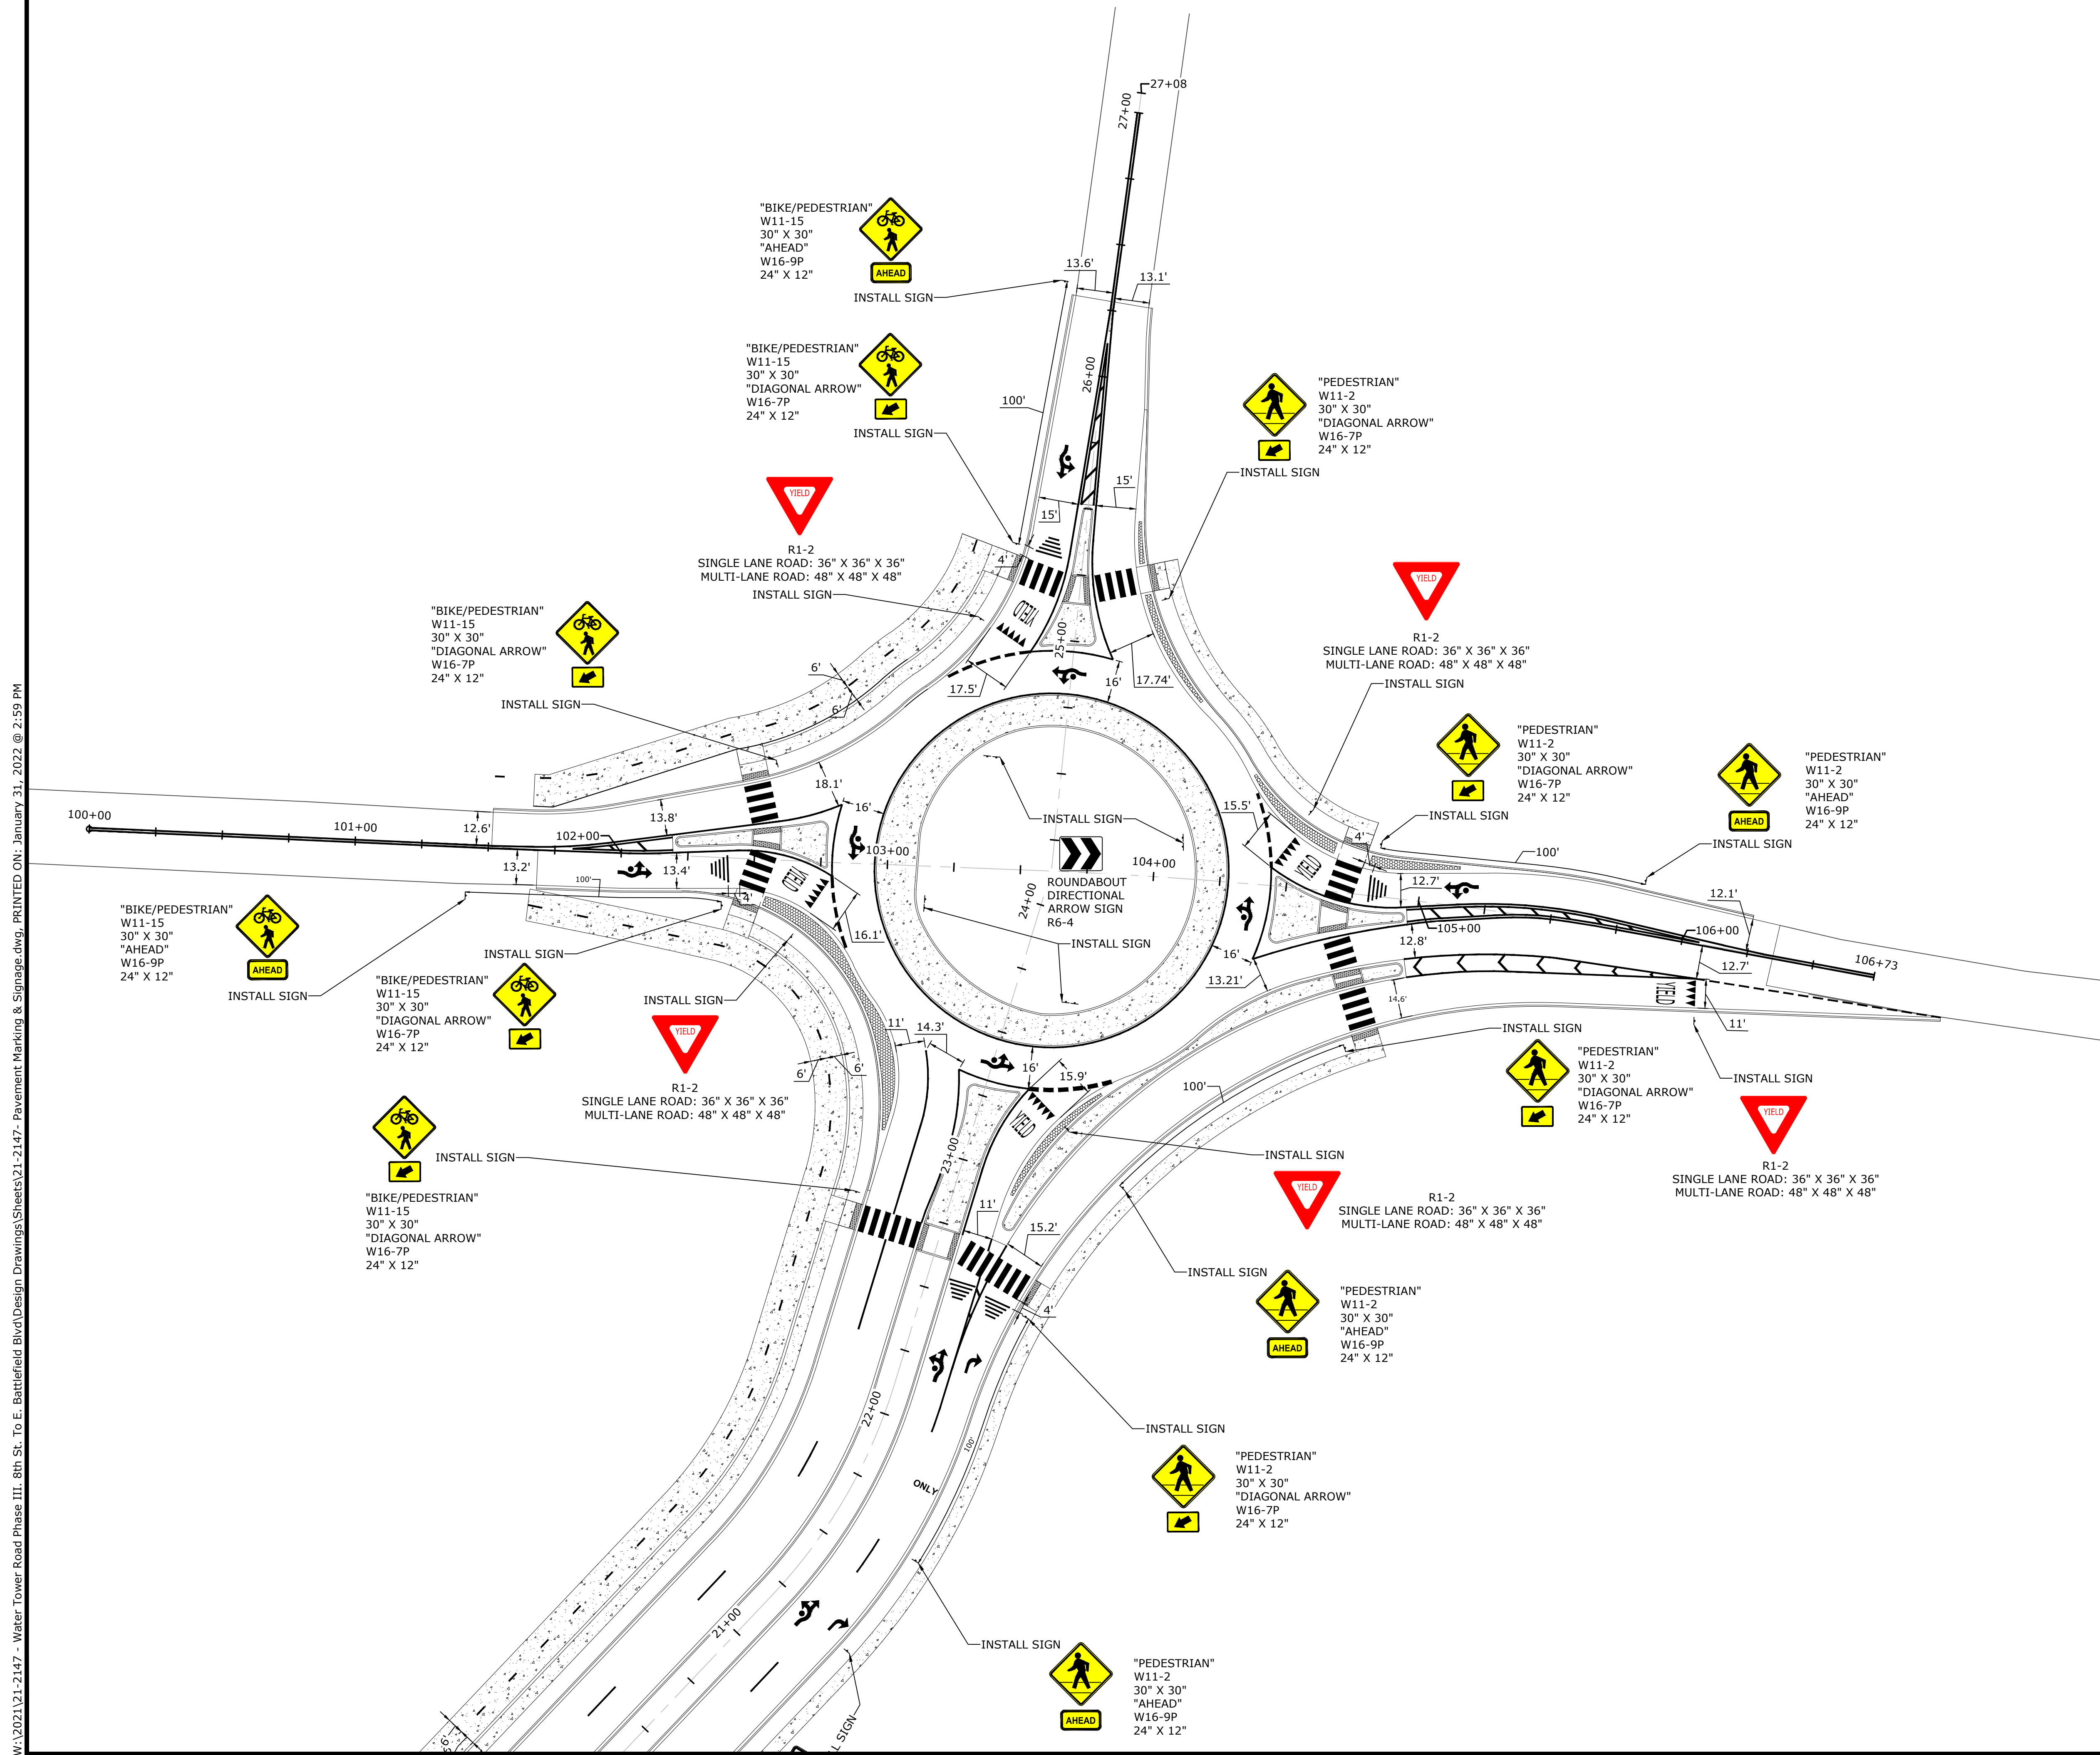

CURB AND GUTTER
PAVEMENT MARKING SYMBOL (AS INDICATED)
SOLID STRIPING
SKIP STRIPING

CROSSWALK STRIPING

PROPOSED CENTERLINE
YIELD LINE, WHITE THERMOPLASTIC
DASHED ENTRY STRIPING
DASHED EXIT STRIPING

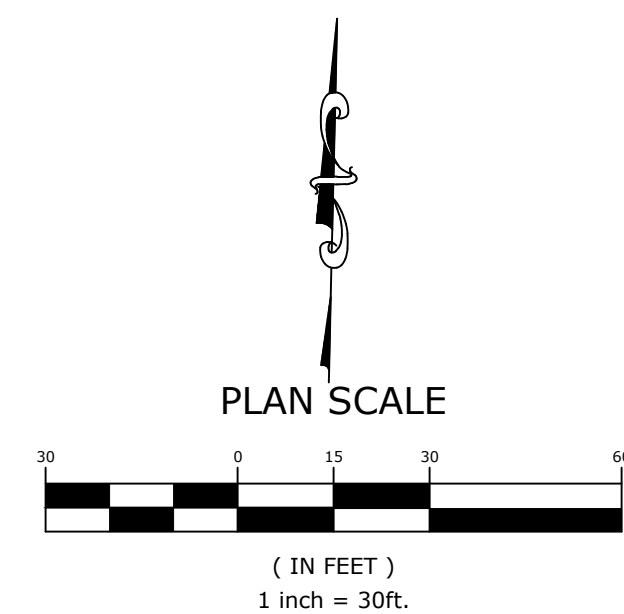

MCE **McCLELLAND**
CONSULTING
ENGINEERS, INC.
DESIGNED TO SERVE

1580 E. STEARNS ST.
FAYETTEVILLE, ARKANSAS 72703
(479) 443-2377
[HTTP://WWW.MCE.US.COM](http://www.mce.us.com)

PRELIMINARY
NOT FOR
CONSTRUCTION

ORIGINAL SIGNATURE ON FILE

WATER TOWER RD. PH.3
SE. 6TH ST. TO BATTLEFIELD BLVD.
BENTONVILLE, AR



[illegible]

PAVEMENT MARKING AND SIGNAGE PLAN- ROUNDBOUT

DESIGNED BY: ELA	DRAWN BY : WAS
DATE: 1/31/2022	REVISION: 30%
SCALE: 1"=30'	JOB NUMBER: 21-2147

PM-4

W:\2021\21-2147 - Water Tower Road Phase III. 8th St. To E. Battelfield Blvd\Design Drawings\Sheets\21-2147- Pavement Marking & Signage.dwg, PRINTED ON: January 31, 2022 @ 2:59 PM

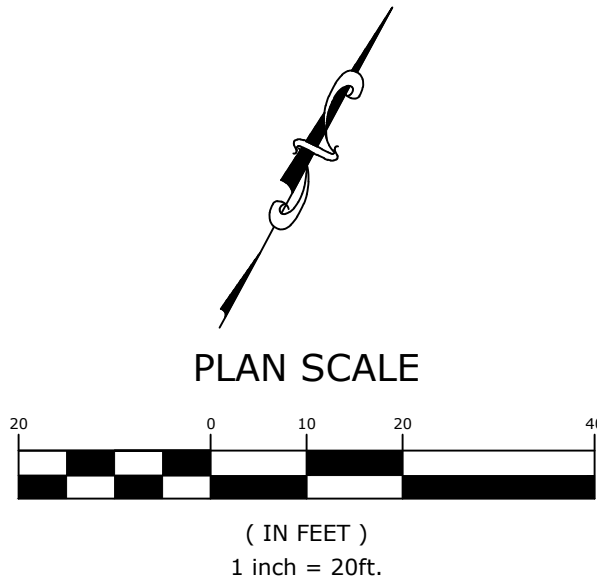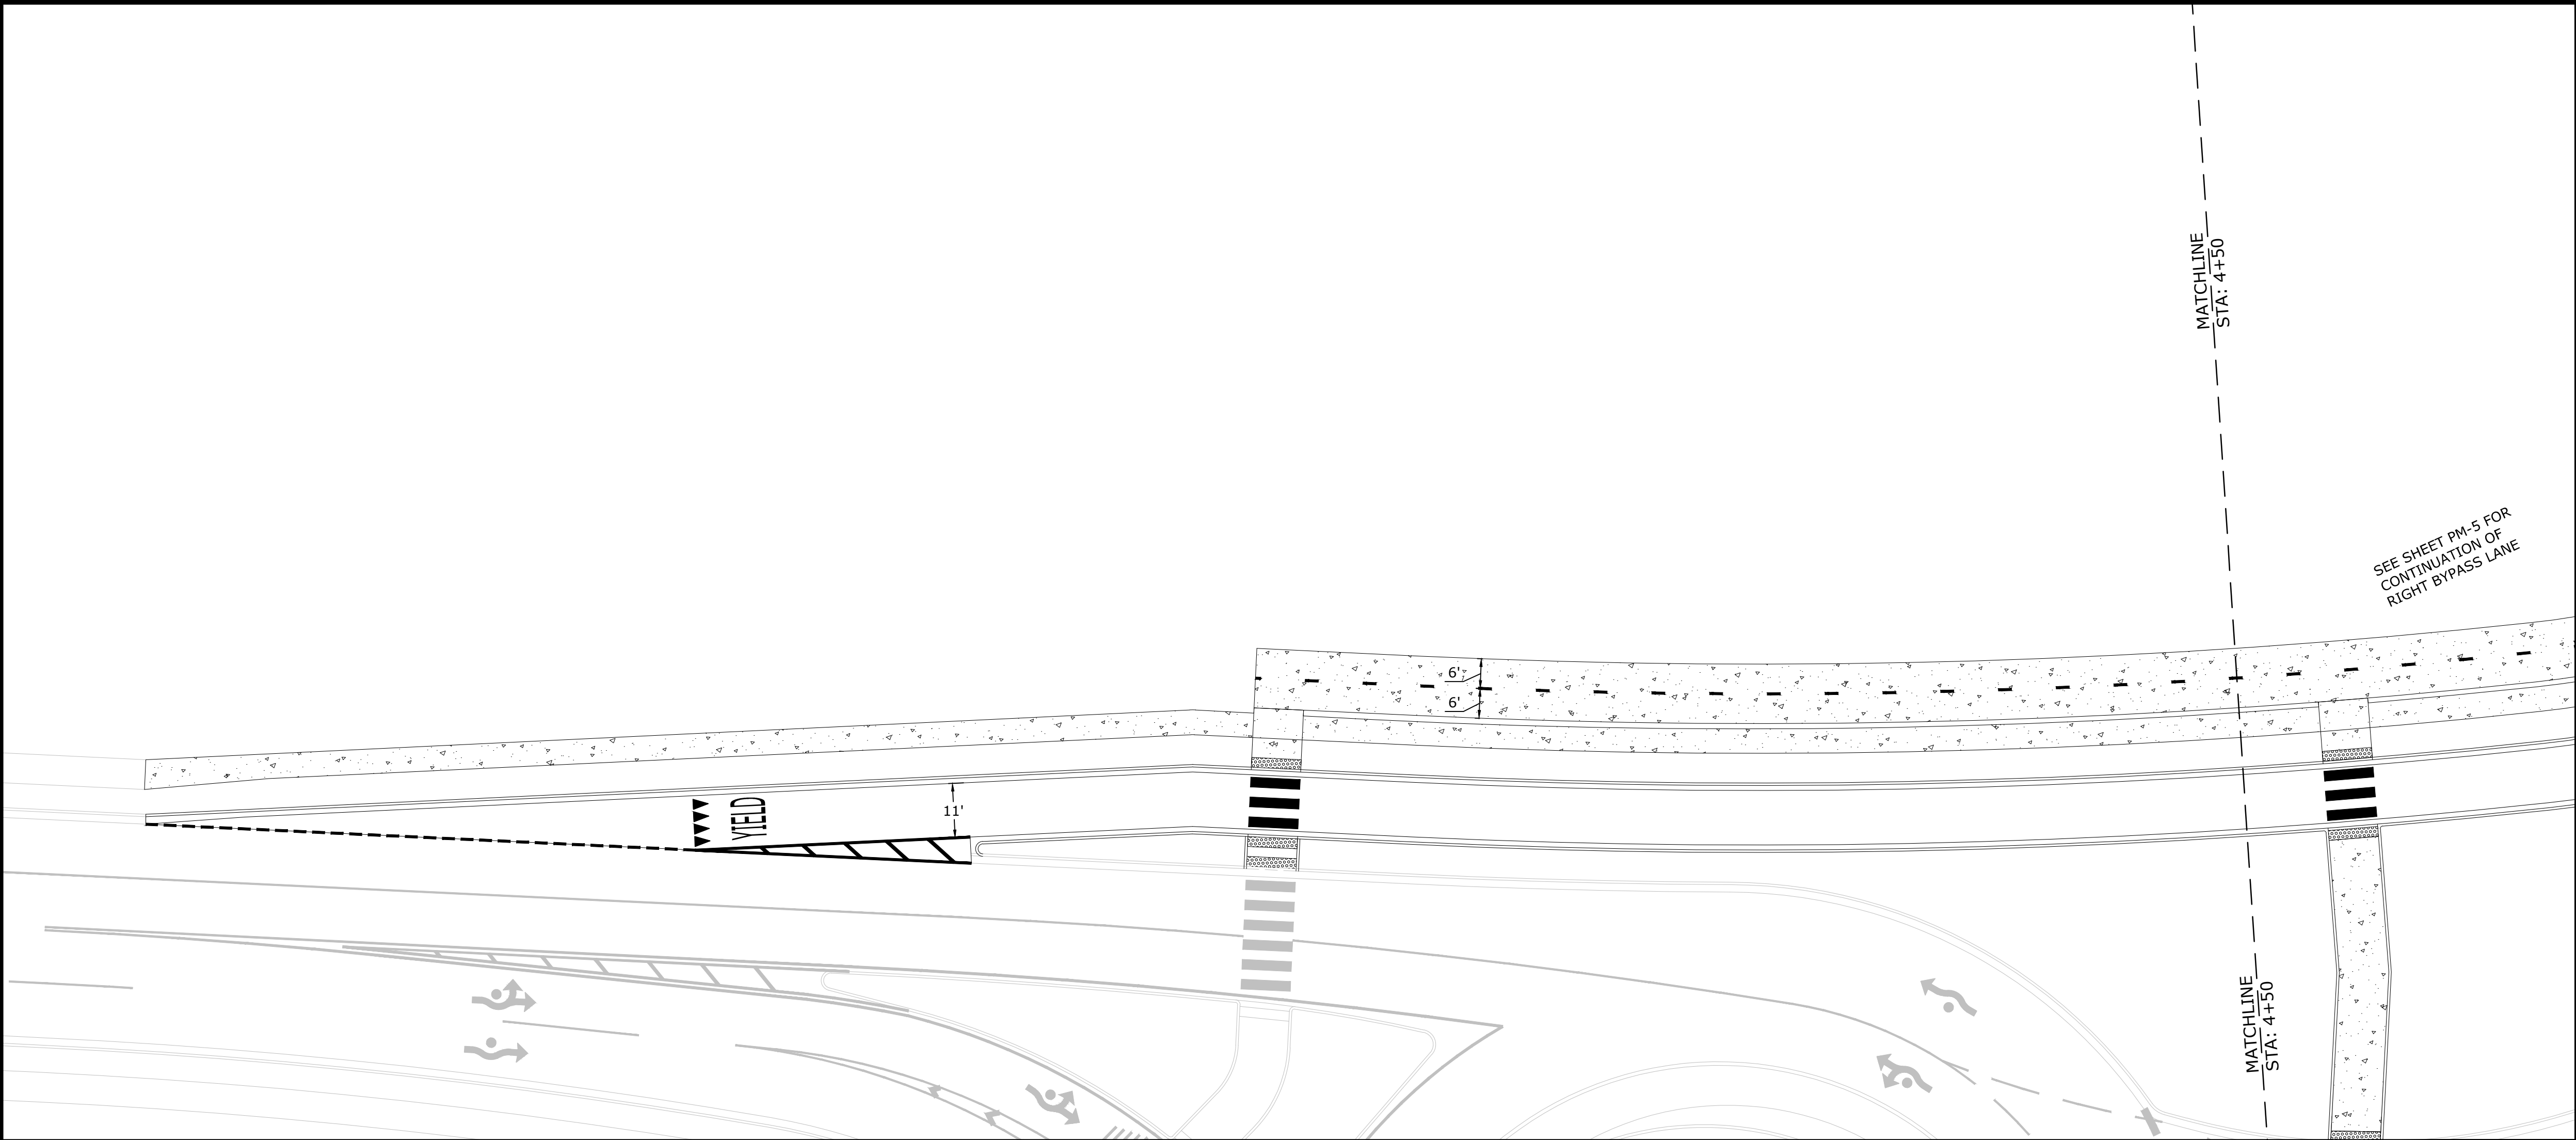

PROPOSED LEGEND	
	CURB AND GUTTER
	PAVEMENT MARKING SYMBOL (AS INDICATED)
	SOLID STRIPING
	SKIP STRIPING
	CROSSWALK STRIPING
	PROPOSED CENTERLINE
	YIELD LINE, WHITE THERMOPLASTIC
	DASHED ENTRY STRIPING
	DASHED EXIT STRIPING

MCE McClelland Consulting Engineers, Inc.
1580 E. STEARNS ST.
FAYETTEVILLE, ARKANSAS 72703
(479) 443-2377
HTTP://WWW.MCE.US.COM

PRELIMINARY
NOT FOR
CONSTRUCTION

ORIGINAL SIGNATURE ON FILE

WATER TOWER RD. PH.3
SE. 6TH ST. TO BATTLEFIELD BLVD.
BENTONVILLE, AR

811
Know what's below.
Call before you dig.

REVISIONS		DESCRIPTION
REV	DATE	

PVMT.
MARKING AND
SIGNAGE
PLAN- SE. 8TH
ST.
CONNECTION


DESIGNED BY: ELA	DRAWN BY : WAS
DATE: 1/31/2022	REVISION: 30%
SCALE: 1" = 20'	JOB NUMBER: 21-2147

PM-5

W:\2021\21-2147 - Water Tower Road Phase III, 8th St. To E. Battlefield Blvd\Design Drawings\Civil\21-2147- Drainage.dwg, PRINTED ON: January 31, 2022 @ 3:09 PM

DRAINAGE AREA DETAILS				
AREA	ACREAGE	C	TC (MIN)	Q ₁₀ (CFS)
1	0.49	0.49	10	1.46
PH. 1 OUTFALL 1	0.73	0.75	5	4.02
2	0.28	0.20	15	0.29
PH. 1 OUTFALL 2	0.19	0.90	5	1.26
3	3.64	0.80	16	14.86
4	3.29	0.20	17	3.27
5	0.50	0.20	20	0.46
6	0.54	0.80	5	3.17
7	0.98	0.85	5	6.11
8	0.10	0.75	5	0.55

OUTFALL COMBINED FLOWS		
AREA	ACREAGE	Q ₁₀ (CFS)
OUTFALL 1	1.22	4.75
OUTFALL 2	0.47	1.35
OUTFALL 3	6.93	17.94
OUTFALL 4	1.04	3.29
OUTFALL 5	0.98	6.11
OUTFALL 6	0.10	0.55

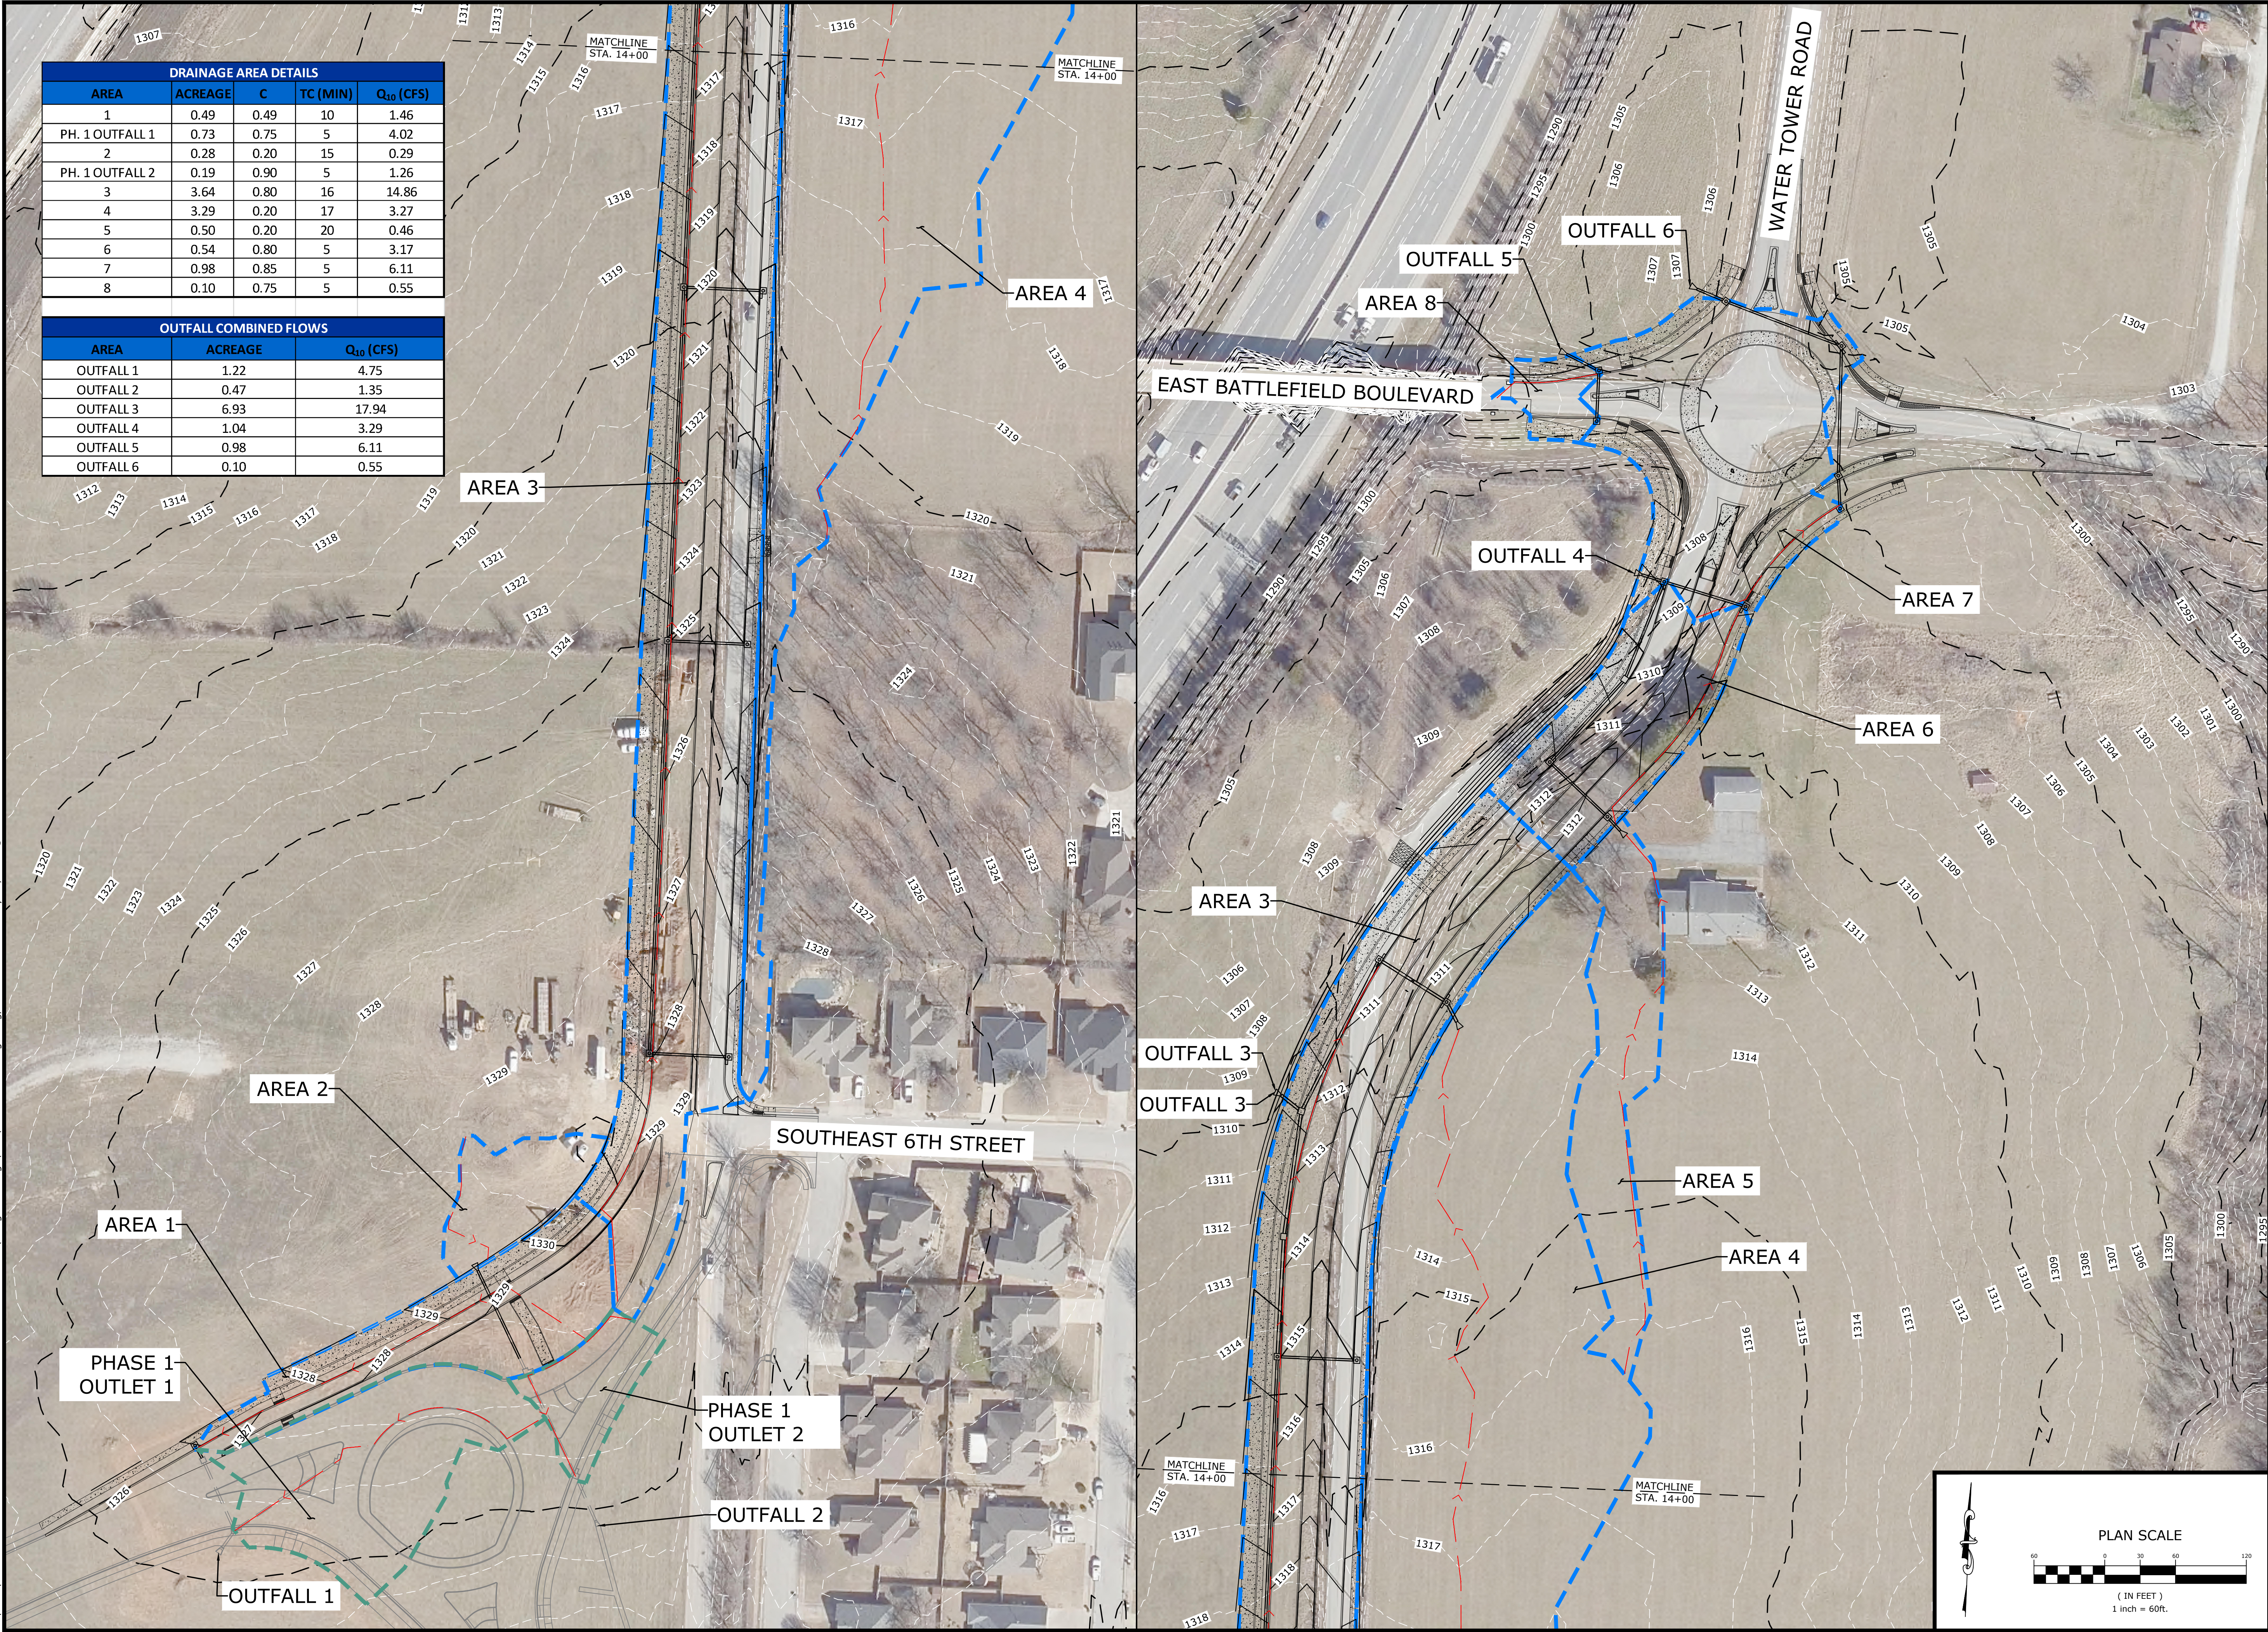

DESIGNED TO SERVE

MCE McClelland Consulting Engineers, Inc.

1580 E. STEARNS ST.
FAYETTEVILLE, ARKANSAS 72703
(479) 443-2377
HTTP://WWW.MCE.US.COM

PRELIMINARY
NOT FOR
CONSTRUCTION

ORIGINAL SIGNATURE ON FILE

WATER TOWER RD. PH.3
SE. 6TH ST. TO BATTLEFIELD BLVD
BENTONVILLE, AR

BENTONVILLE

ENGINEERING

Know what's below.
Call before you dig.

REV	DATE	DESCRIPTION

DESIGNED BY:
ELA

DATE:
1/31/2022

SCALE:
1"=60'

DRAWN BY:
WAS

REVISION:
30%

JOB NUMBER:
21-2147

DMP-1